



24 M.WIDE ROAD

24 M.WIDE ROAD

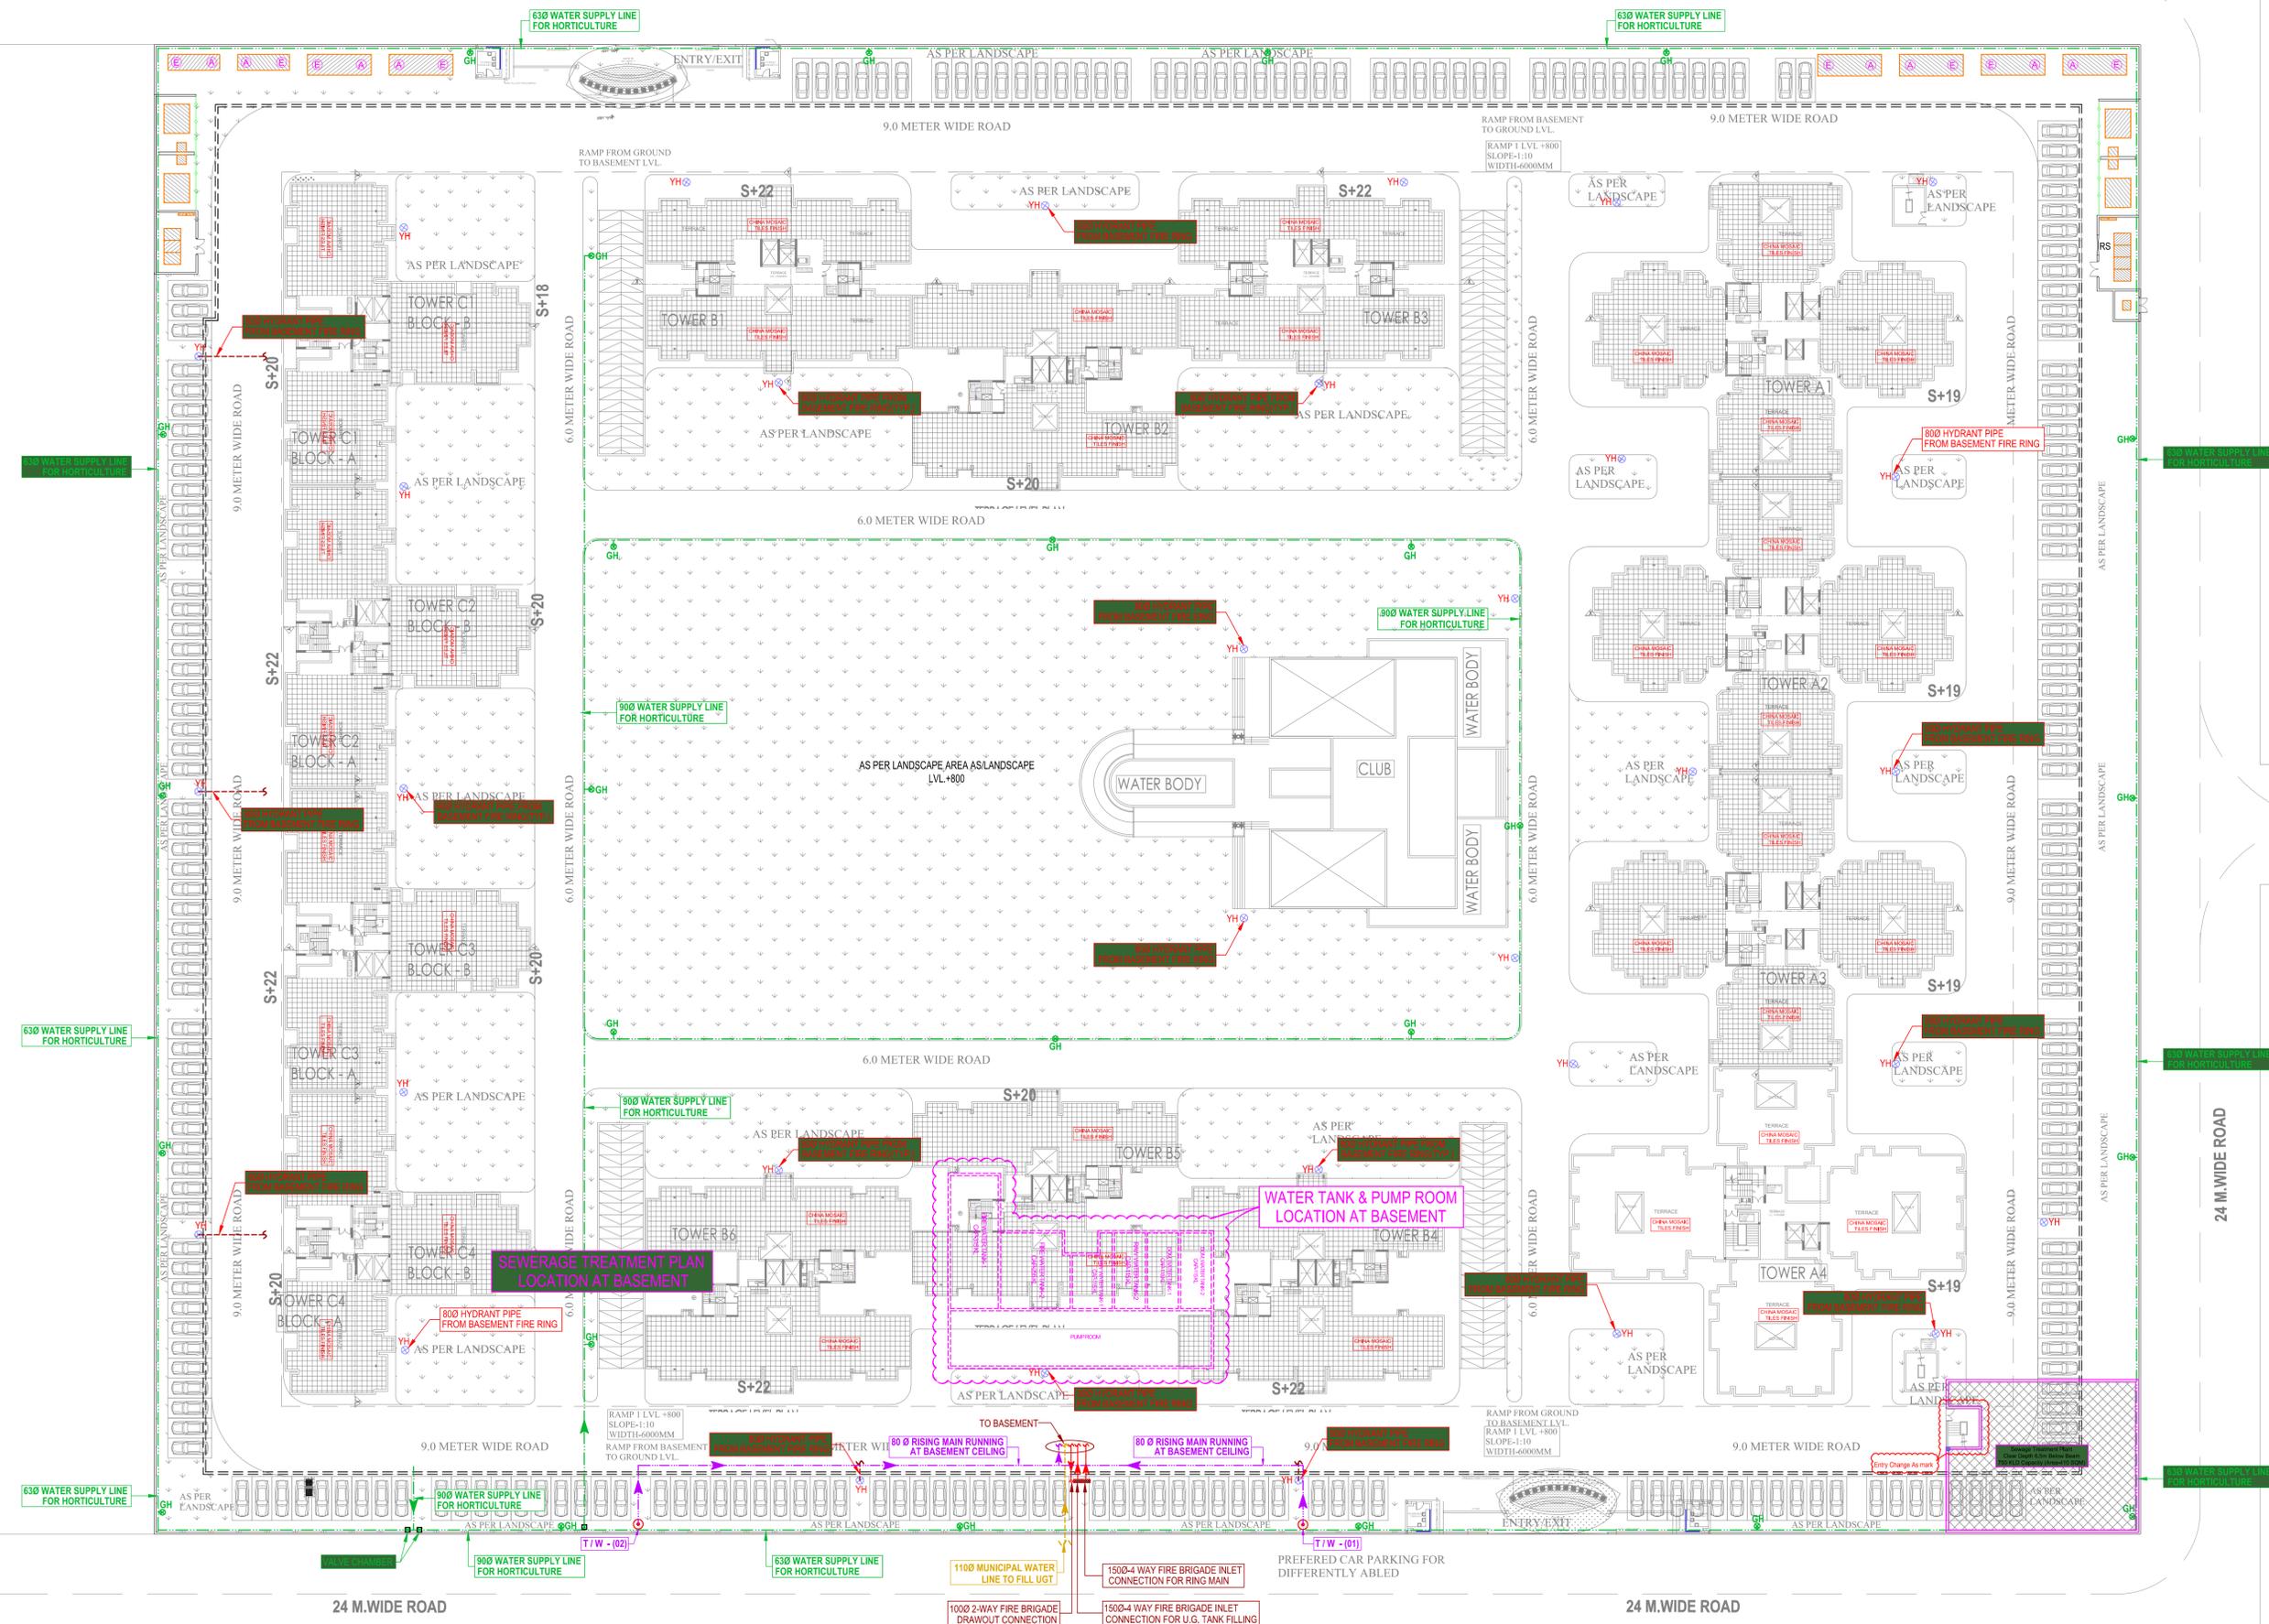

KEY PLAN

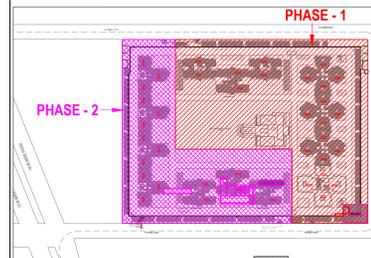

LEGEND :

S. No.	SYMBOL	DESCRIPTION
1.		PROPOSED TUBE WELL
2.		RISING MAIN LINE (FROM TW TO U.G.T.)
3.		MUNICIPAL WATER SUPPLY PIPE LINE.
4.		RECYCLED WATER SUPPLY LINE FOR HORTICULTURE
5.		GARDEN HYDRANT
6.		MASONRY CHAMBER FOR ISOLATING VALVE
7.		FIRE LINE
8.		FIRE BRIGADE CONNECTION
9.		BUTTERFLY VALVE
10.		NONRETURN VALVE (CHECK VALVE)
11.		ISOLATING VALVE WITH MASONRY CHAMBER
12.		YARD HYDRANT 63 M.M. DIA. SINGLE HEADED HYDRANT VALVE WITH 2 NOS. 15 M. LONG, 63 M.M. DIA. FIRE HOSE PIPE & 1 NO. BRANCH PIPE WITH NOZZLE
13.		BASEMENT RETAINING WALL
14.		PLOT LINE

rev. no.	date	revision
R3	22.10.2016	Arch. Plan Revised
R2	31.07.2015	Revised as per requirement
R1	22.07.2015	Revised as per requirement

project
MANHATTAN GROUP HOUSING AT LUCKNOW

title
SITE PLAN

subtitle
WATER SUPPLY LAYOUT

drawing released for
 APPROVAL SUBMISSION
 ADVANCE COPY CONSTRUCTION

drg. no. RM / PL - 02c drawn by Imran

scale 1 : 425 designed by Shakir Shabbir

date July 2015 checked by Anand Havelia

architects
dfi DESIGN FORUM INTERNATIONAL
K-47, KAILASH COLONY NEW DELHI-48
PHONE: 011-46556600 FAX: 46556601

services consultant
Consummate Engineering Services (P) Ltd.
Noida Office : B - 67, Sector - 67, Noida - 201 301
Tel : (0120) 6943500 (24 Lines)
Lko. Office : R 006, Rohtas Plumeria, Gomti Nagar, Lucknow
e mail : mail@cespln, website : www.cespln