


BCC COMMERCIAL KITCHEN PROJECT

| SEWAGE | |
|---------|--------------------------|
| SYMBOLS | DESCRIPTION |
| ⊕ | CLEAN OUT |
| ▬ | ACO HYGIENIC BOX CHANNEL |
| ■ | ACO HYGIENIC GULLY |
| → | 1000 UPVC WASTE PIPE |

|  | PROPERTY NAME | UNIT NUMBER | DRAWING TITLE | DATE | NOTE | PAGE NO |
|---|-----------------------|----------------|-----------------|-----------------|------|---------|
| | INDOOR SPORTS COMPLEX | 11594-ISC-1-01 | DRAINAGE LAYOUT | 5/12/2022 | | |
| | TENANT NAME | USAGE | SCALE | REVISION NUMBER | | |
| BCC | COMMERCIAL KITCHEN | 1:75 | 12 | | | |

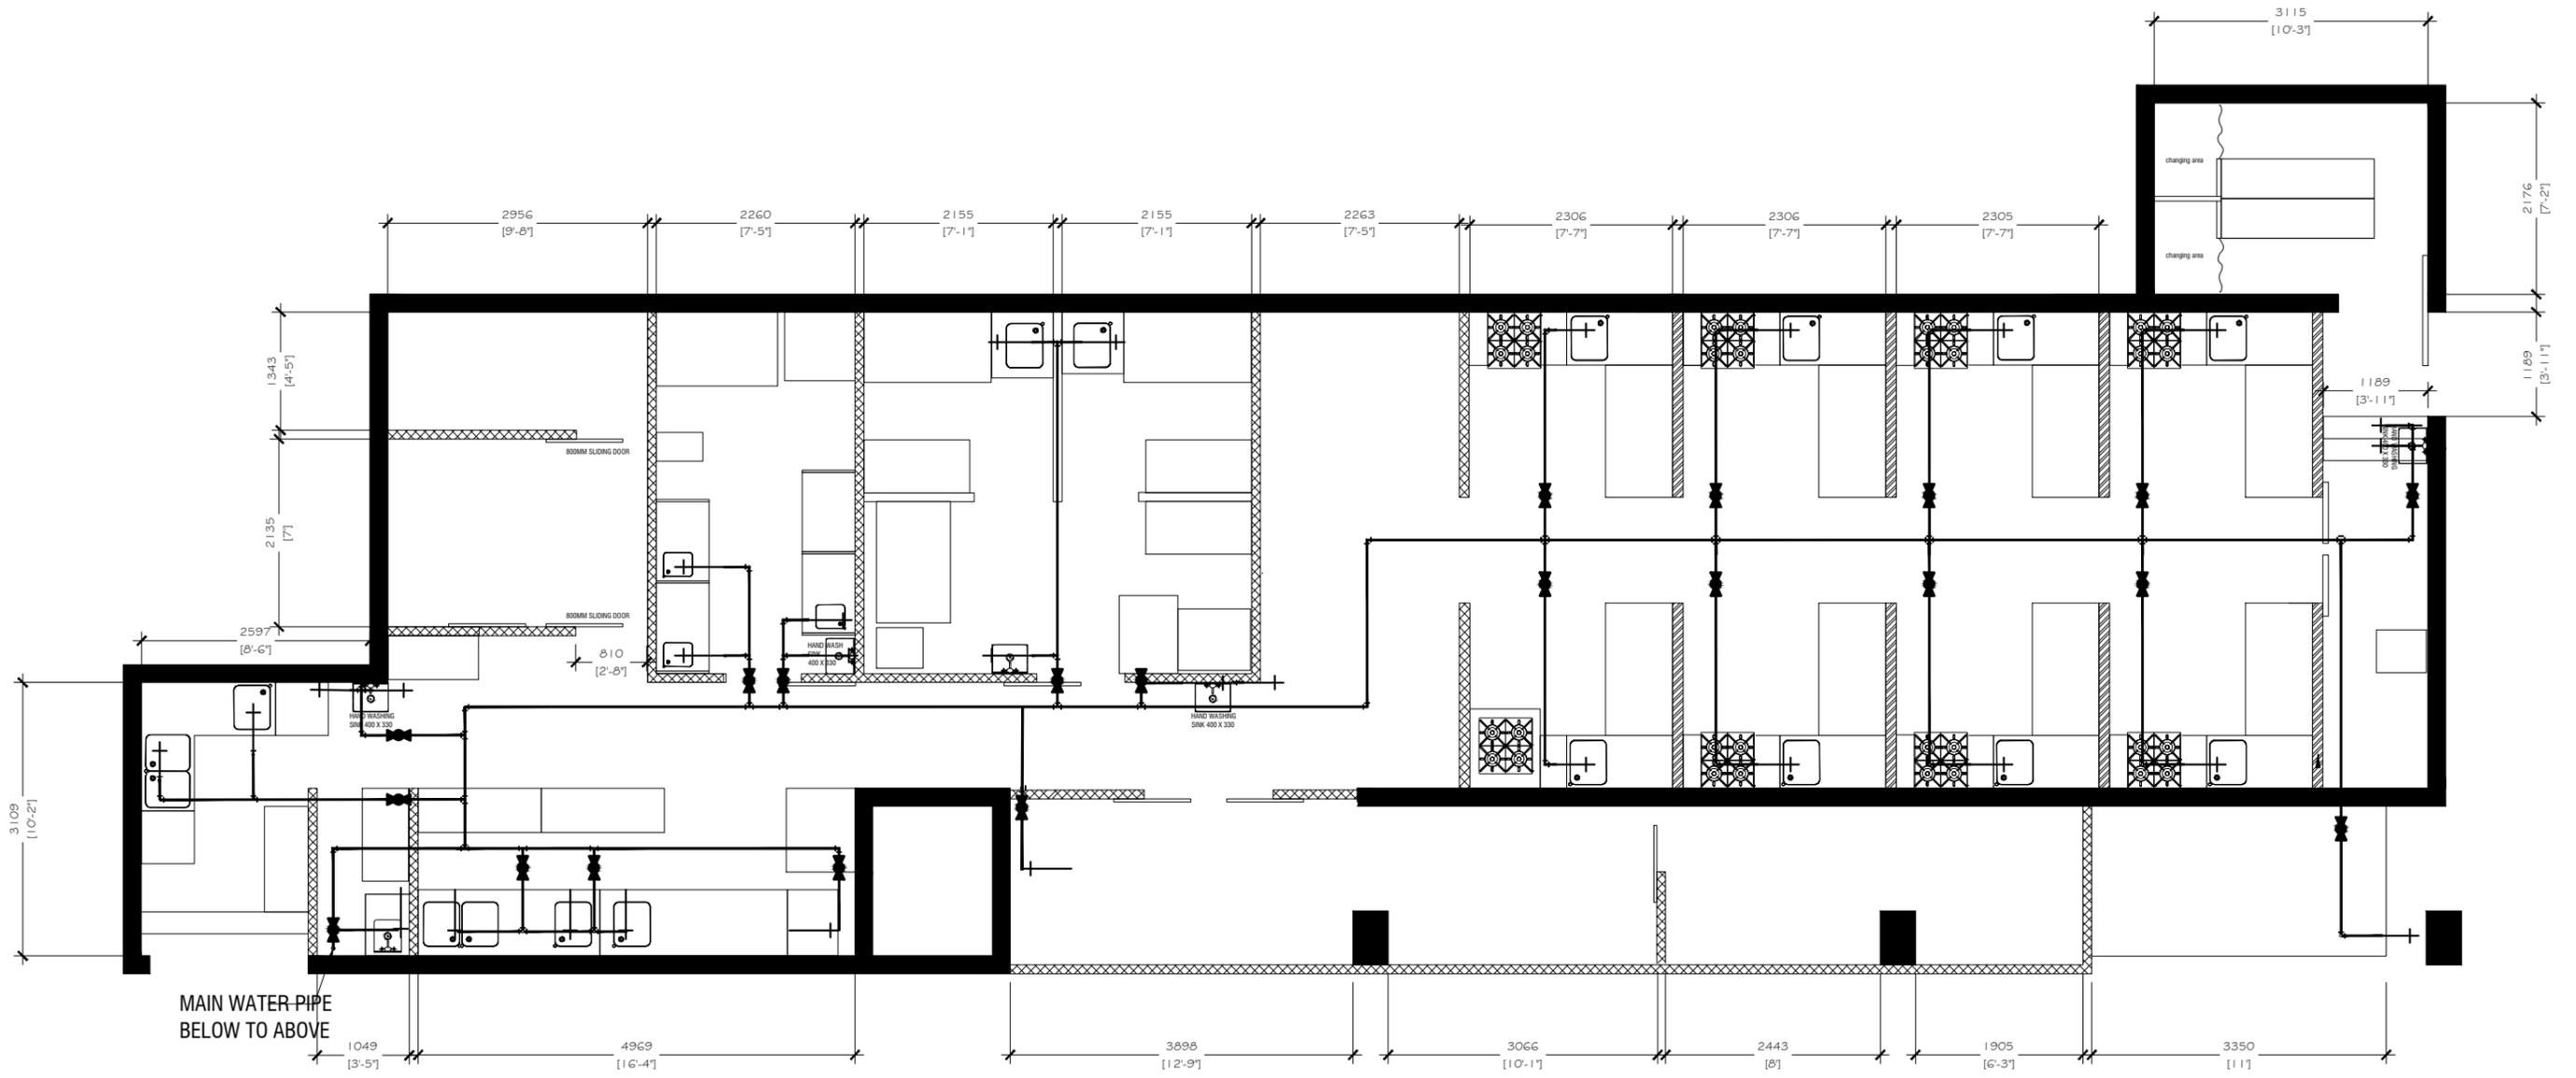

BCC COMMERCIAL KITCHEN PROJECT

| WATER SUPPLY | |
|--------------|------------------|
| SYMBOLS | DESCRIPTION |
| | TAP |
| | BALL VALVE |
| | FRESH WATER PIPE |

NOTE: HEATER TO BE ALLOCATED TO THE STORAGE TOP
 ALL SINKS EXCEPT THE SMALLEST SINKS TO HAVE BOTH HOT AND COLD
 BESIDE ALL SMALL SINKS IN THE COMMON AREAS, TO HAVE A
 RETRACTABLE HOSE REEL WITH SPRAY GUN

| | | | | | | |
|---|-----------------------|--------------------|-------------------|-----------------|---|----------------------|
|  | PROPERTY NAME | UNIT NUMBER | DRAWING TITLE | DATE | NOTE | PAGE NO 04 |
| | TENANT NAME | USAGE | SCALE | REVISION NUMBER | | |
| | INDOOR SPORTS COMPLEX | 11594-ISC-1-01 | WATER SUPPLY PLAN | 5/12/2022 | DO NOT SCALE ALL DIMENSIONS SHALL BE VERIFIED ON SITE BY THE CONTRACTOR. | |
| | BCC | COMMERCIAL KITCHEN | 1:75 | 12 | ANY DISCREPANCIES SHALL BE MADE KNOWN TO THE DESIGNER FOR DECISION BEFORE PROCEEDING WITH THE WORK. | |