


UPGRADING OF LH. KURENDHOO ISLAND WASTE MANAGEMENT CENTRE




PREPARED BY:

MALDIVES CLEAN ENVIRONMENT PROJECT
MINISTRY OF ENVIRONMENT AND ENERGY

2018

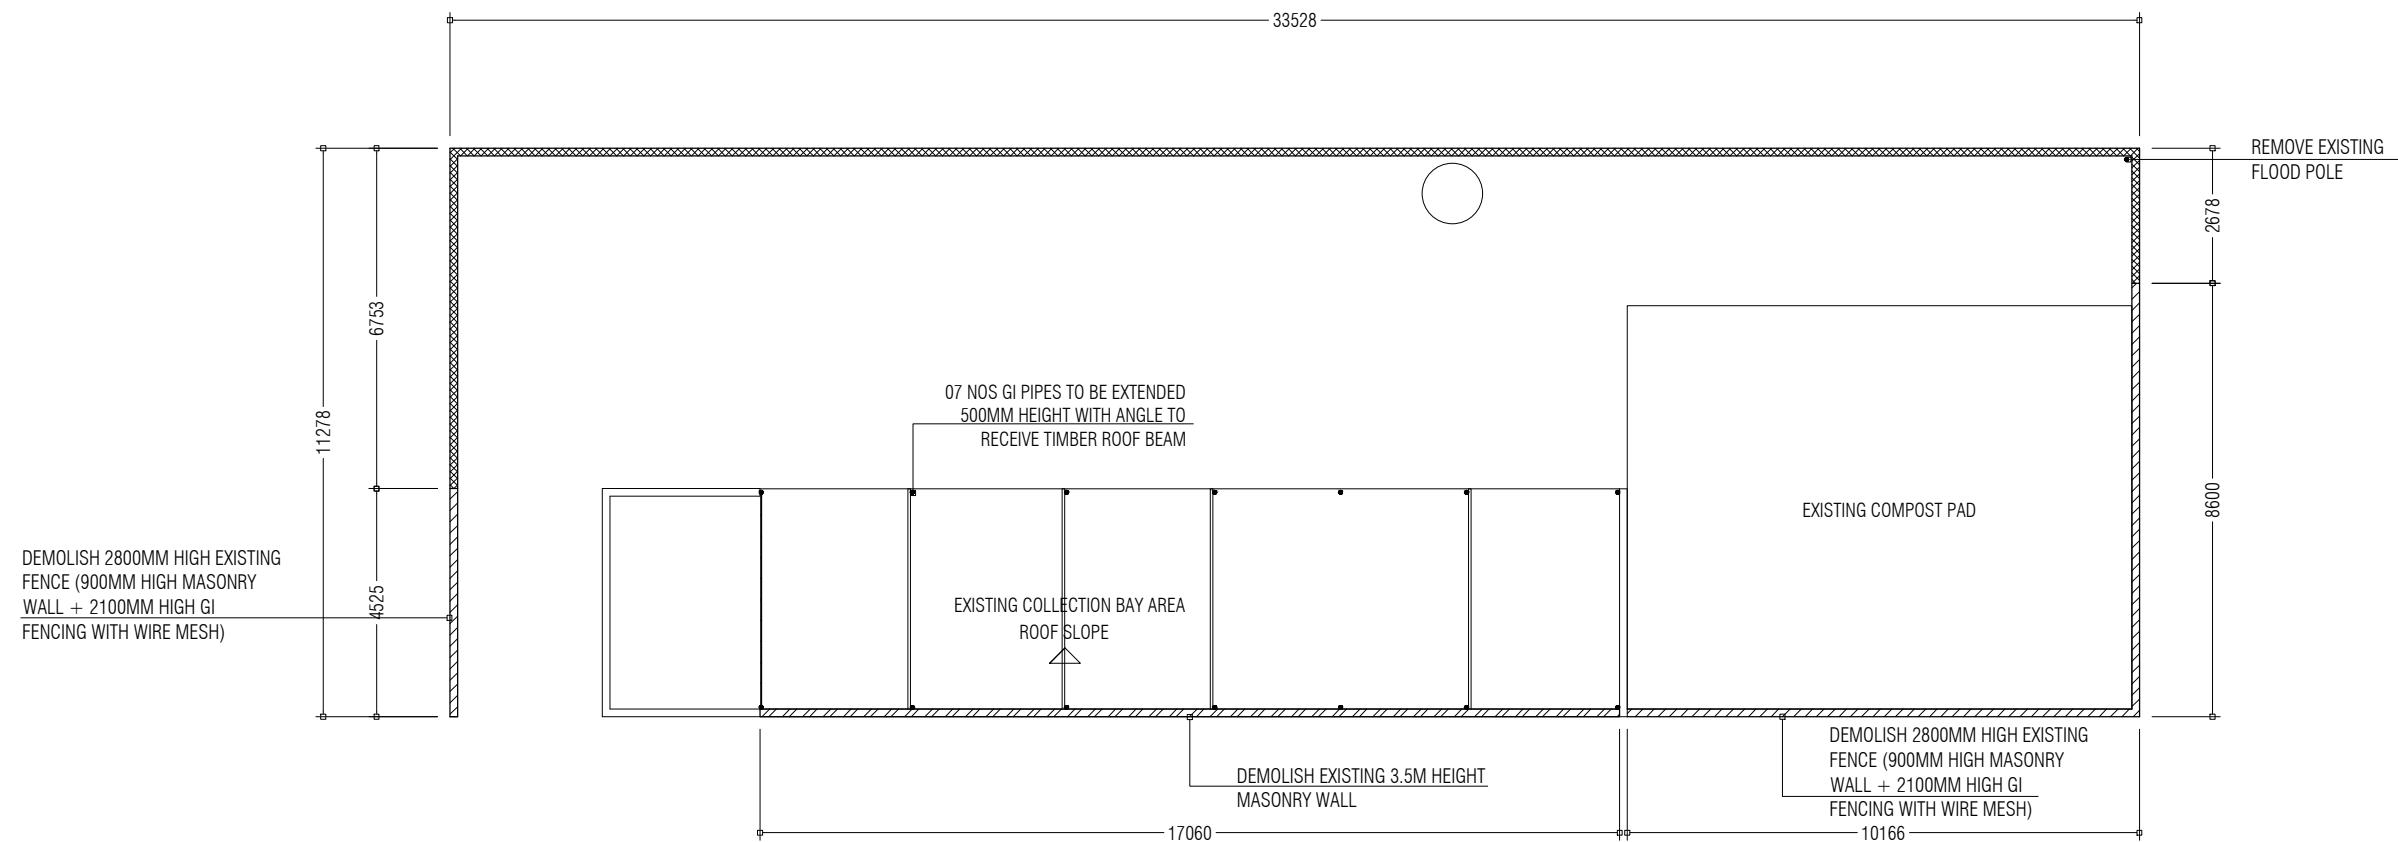


APPROVED BY	PROJECT	DESIGN BY	AMENDMENTS
 <p>MCEP MINISTRY OF ENVIRONMENT AND ENERGY GREEN BUILDING, HANDHUVAREE HIGUN, MAAFANNU, MALE' (20392), REPUBLIC OF MALDIVES, TEL: +960-3018431, +960-3018300, FAX: +960-328301</p>	UPGRADING OF WASTE MANAGEMENT CENTRE LH. KURENDHOO	AFRAZ	
	TITLE	STRUCTURE BY	
	DEMOLITION PLAN	AFRAZ	
	CLIENT DEPARTMENT	DRAWN BY	
	WMPC DEPARTMENT	AFRAZ	
	PAPER SIZE A3	SCALE 1:150	
	PAGE NO. 01	DWG NO. KUR A1-01	
		DATE 08.07.2018	

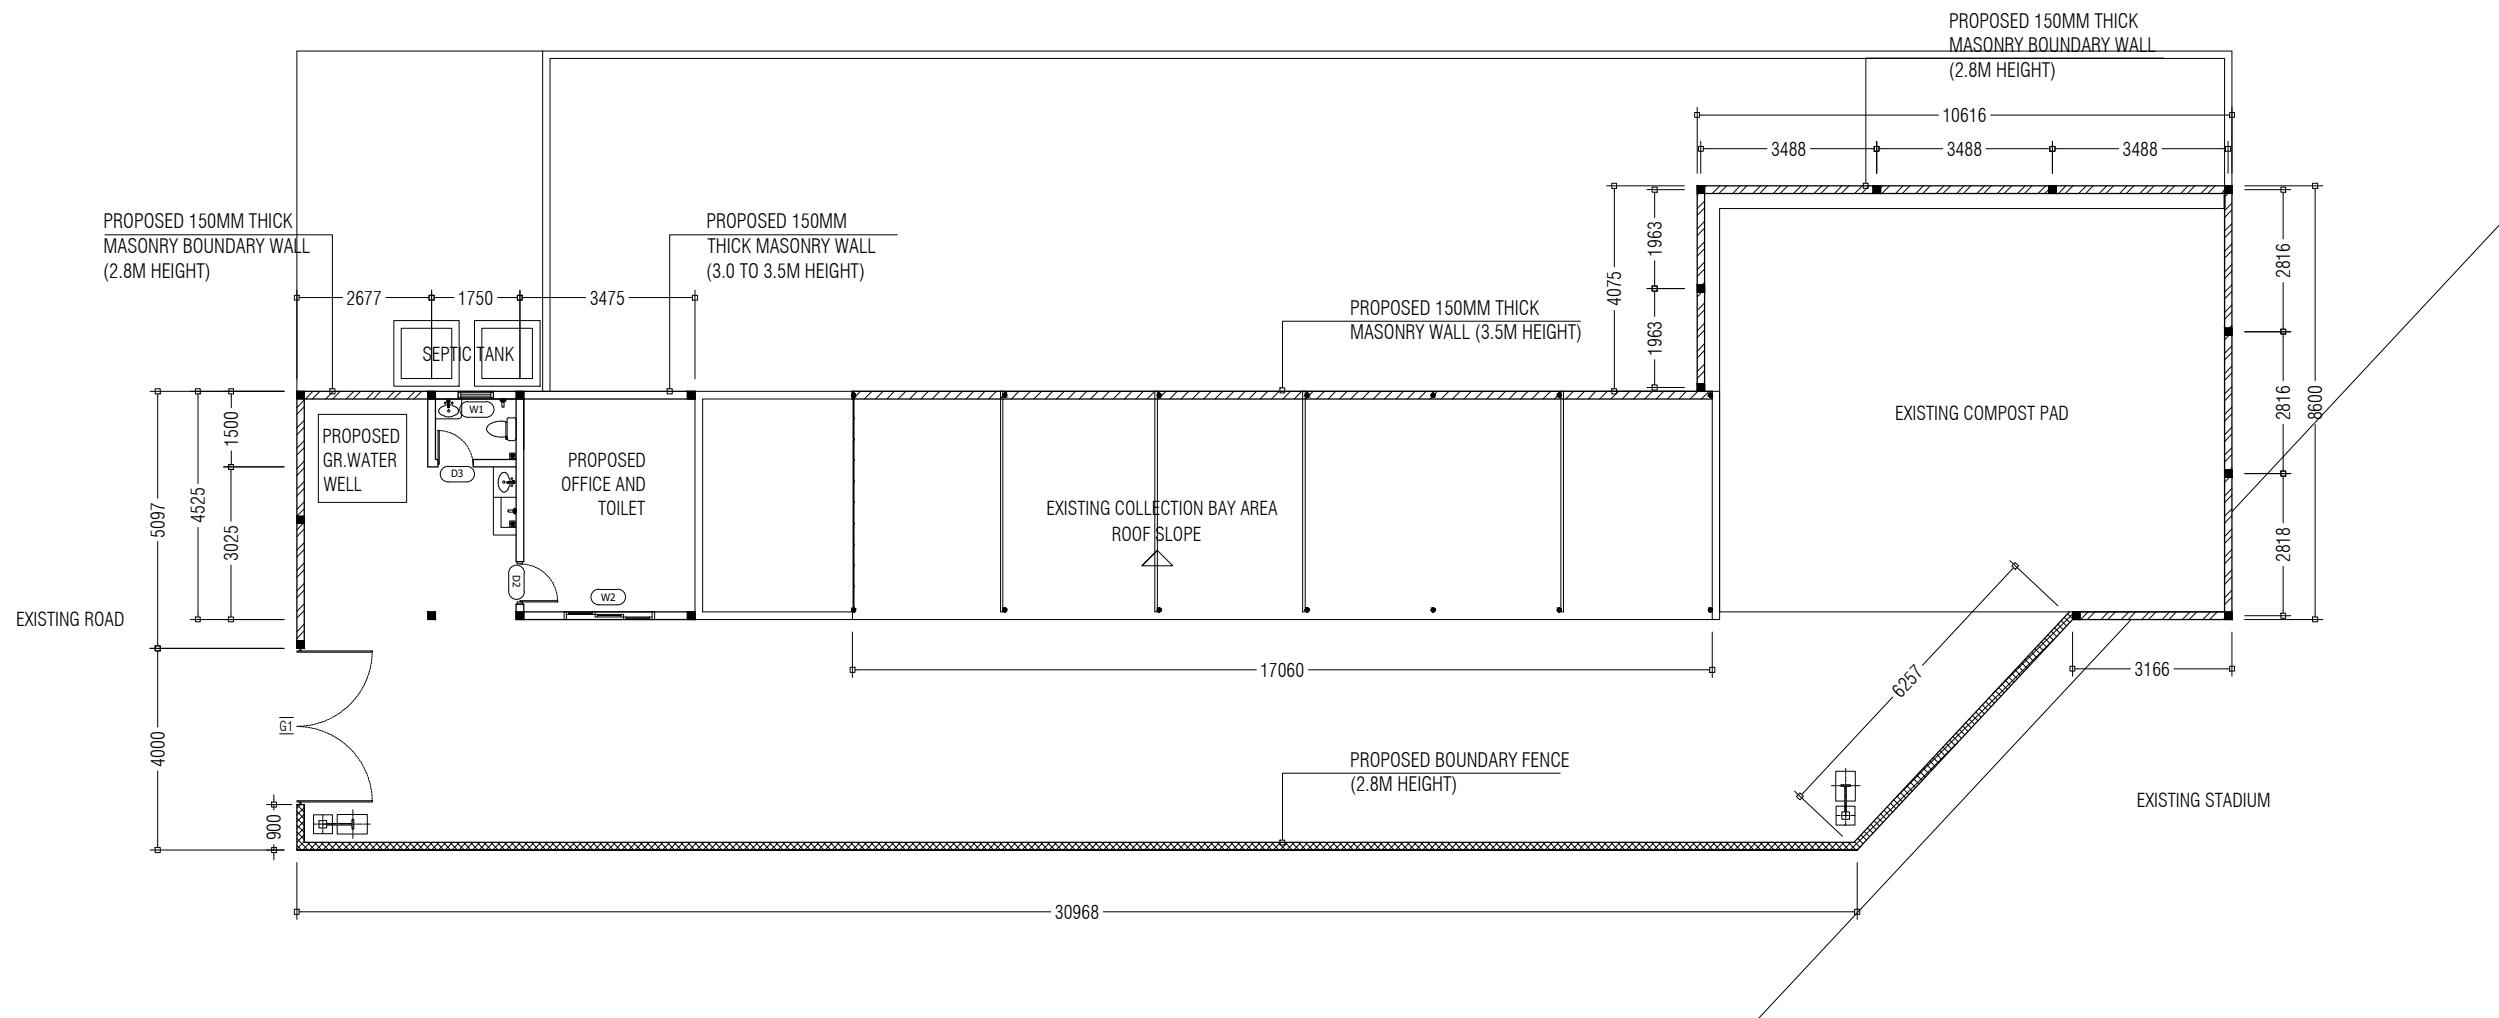

NOTE:

-  3500mm HEIGHT WALL [150mm HOLLOW BOCK]
-  2800mm HEIGHT PERIMETER WALL [150mm HOLLOW BOCK]
-  PERIMETER FENCE [150mm HOLLOW BOCK]


APPROVED BY	PROJECT	DESIGN BY	AMENDMENTS
 MCEP MINISTRY OF ENVIRONMENT AND ENERGY GREEN BUILDING, HANDHUVAREE HIGUN, MAAFANNU, MALE' (20392), REPUBLIC OF MALDIVES, TEL: +960-3018431, +960-3018300, FAX: +960-328301	UPGRADING OF WASTE MANAGEMENT CENTRE LH. KURENDHOO	AFRAZ	
	TITLE	STRUCTURE BY	
	DEVELOPMENT PLAN	AFRAZ	
	CLIENT DEPARTMENT	DRAWN BY	
	WMPC DEPARTMENT	AFRAZ	
	PAPER SIZE A3	SCALE 1:150	
	PAGE NO. 02	DWG NO. KUR A1-02	
		DATE 08.07.2018	

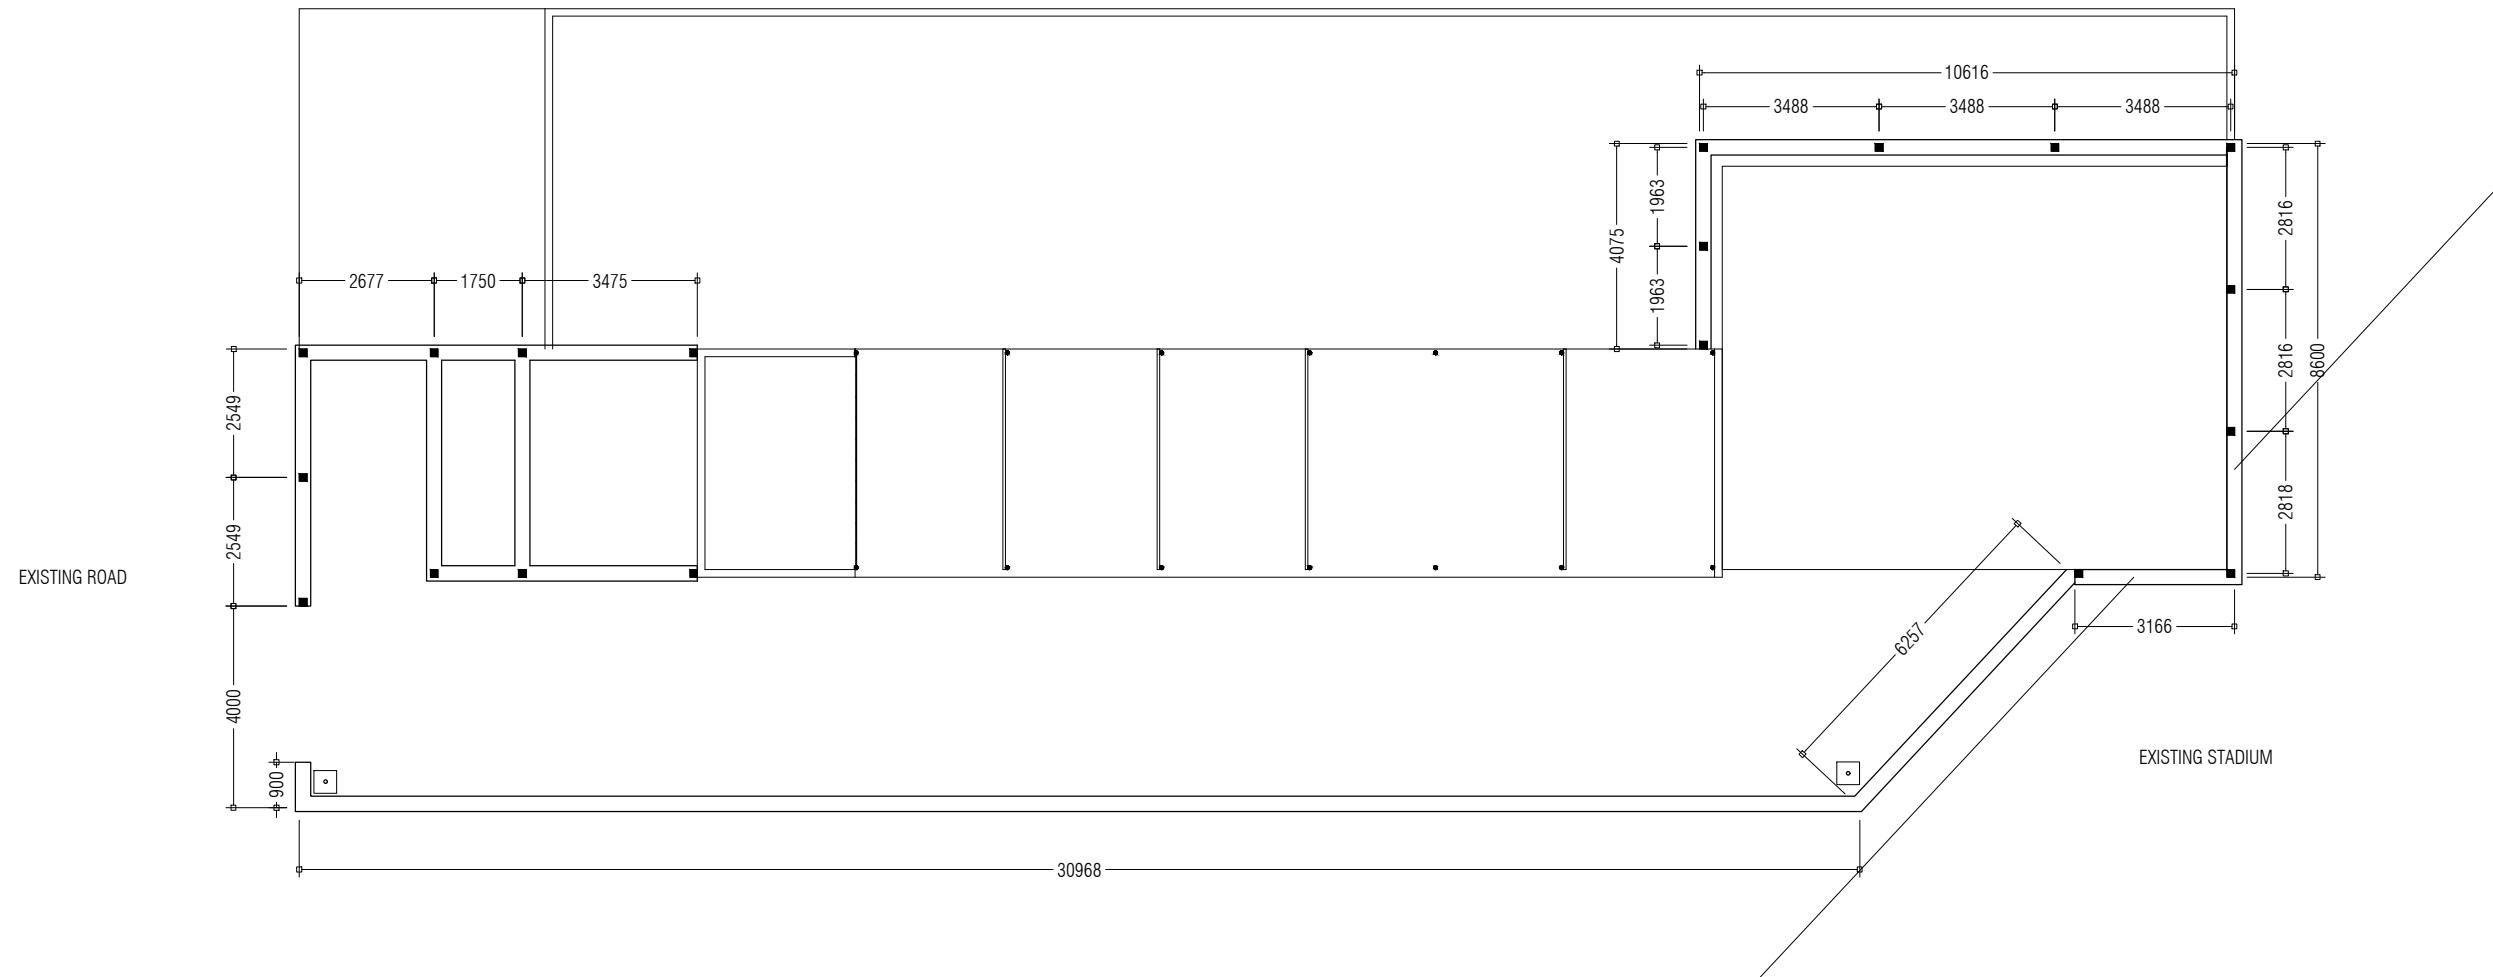


NOTE:

- FOUNDATION BEAMS [300mm width]
- COLUMN, C1 [150X150mm]
- LAMP POST FOOTING [450X450mm]







APPROVED BY	PROJECT	DESIGN BY	AMENDMENTS
 <p>MCEP MINISTRY OF ENVIRONMENT AND ENERGY GREEN BUILDING, HANDHUVAREE HIGUN, MAAFANNU, MALE' (20392), REPUBLIC OF MALDIVES, TEL: +960-3018431, +960-3018300, FAX: +960-328301</p>	UPGRADING OF WASTE MANAGEMENT CENTRE LH. KURENDHOO	AFRAZ	
	TITLE	STRUCTURE BY	
	FOUNDATION BEAM PLAN	AFRAZ	
	CLIENT DEPARTMENT	DRAWN BY	
	WMPC DEPARTMENT	AFRAZ	
	PAPER SIZE A3	SCALE 1:150	
	PAGE NO. 03	DWG NO. KUR A1-03	
		DATE 08.07.2018	

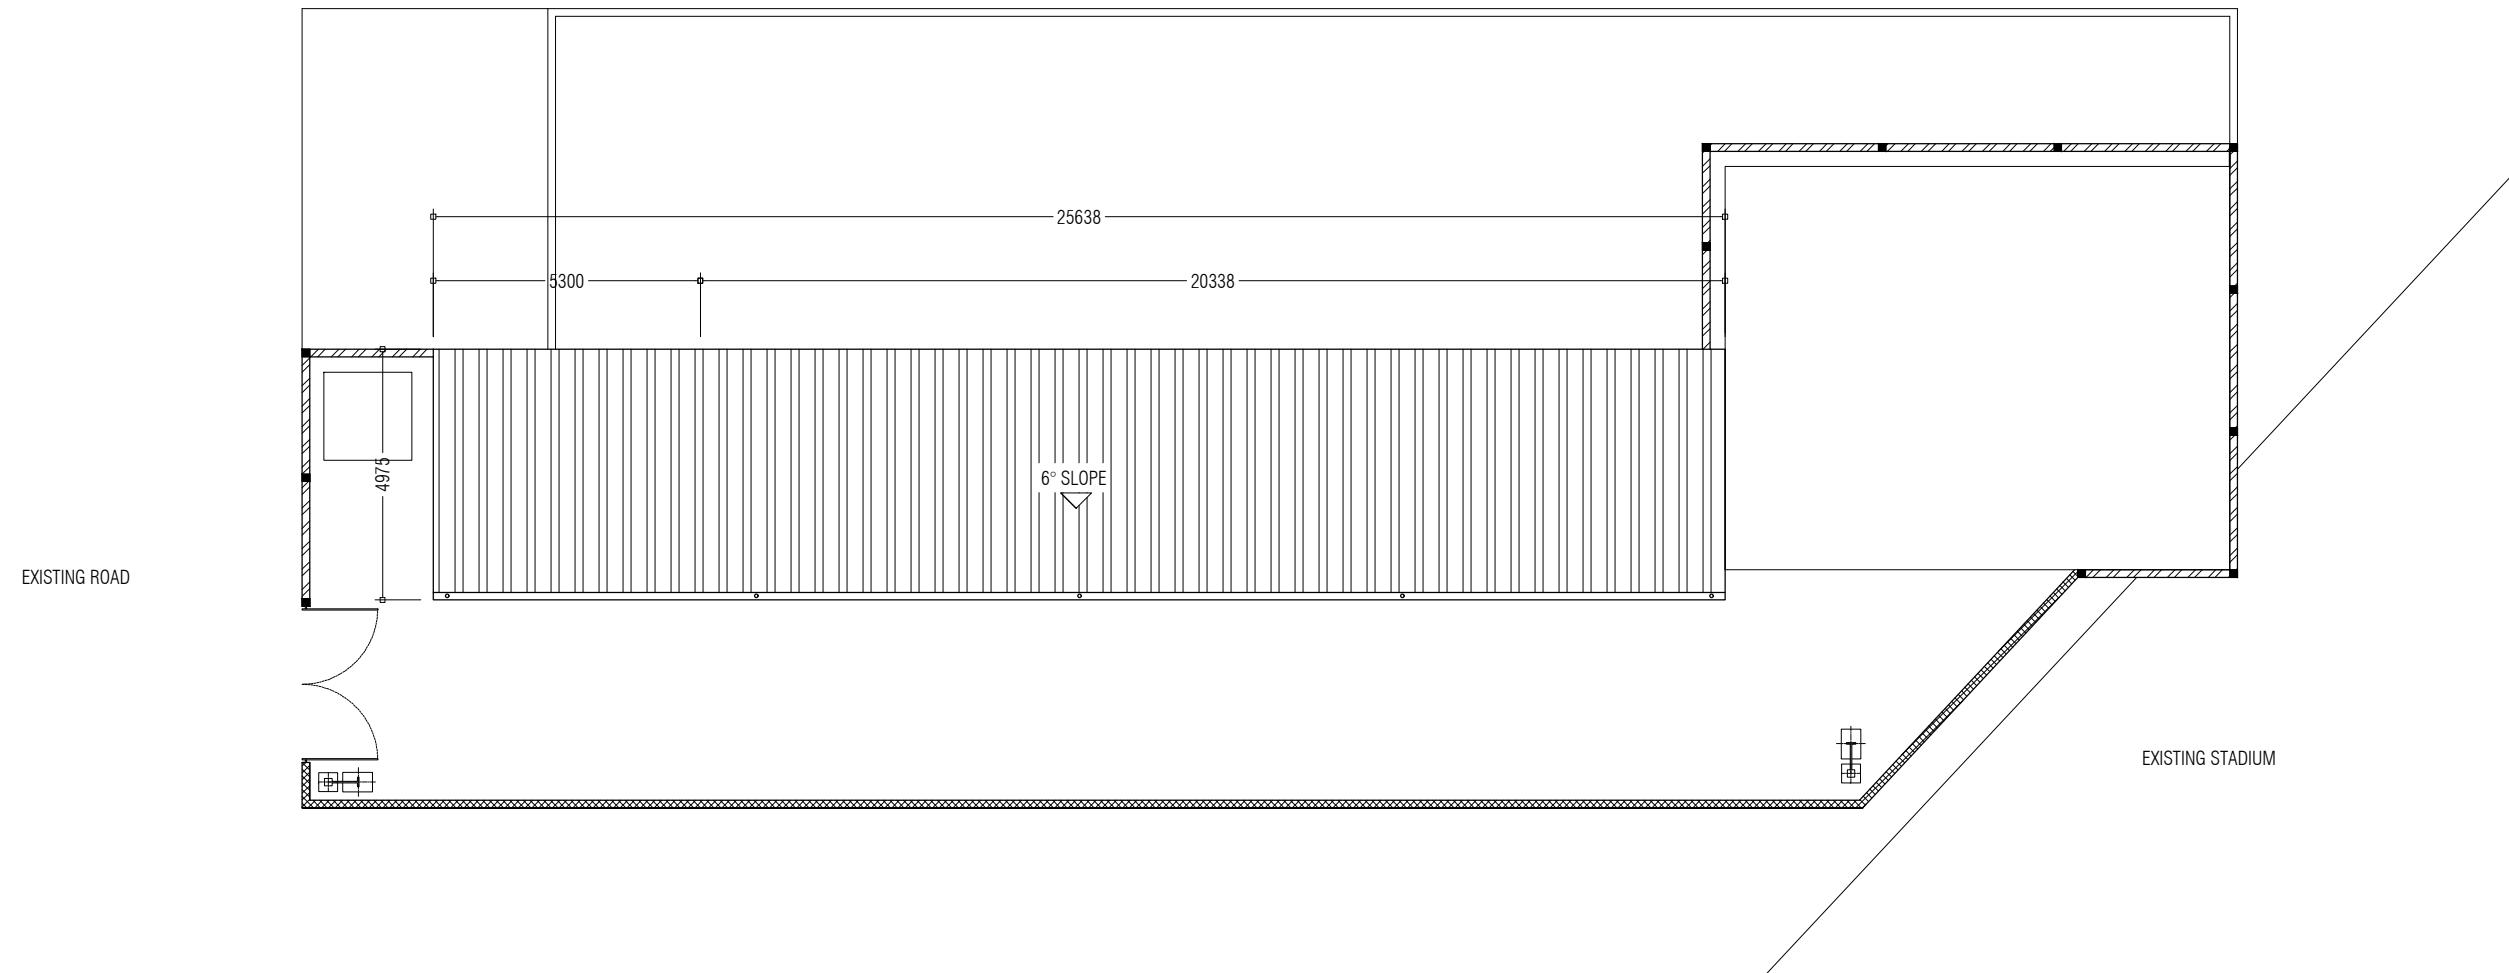



APPROVED BY	PROJECT	DESIGN BY	AMENDMENTS
 <p>MCEP MINISTRY OF ENVIRONMENT AND ENERGY GREEN BUILDING, HANDHUVAREE HIGUN, MAAFANNU, MALE' (20392), REPUBLIC OF MALDIVES, TEL: +960-3018431, +960-3018300, FAX: +960-328301</p>	UPGRADING OF WASTE MANAGEMENT CENTRE LH. KURENDHOO	AFRAZ	
	TITLE	STRUCTURE BY	
	ROOF PLAN	AFRAZ	
	CLIENT DEPARTMENT	DRAWN BY	
	WMPC DEPARTMENT	AFRAZ	
	PAPER SIZE A3	SCALE 1:150	
	PAGE NO. 04	DWG NO. KUR A1-04	
		DATE 08.07.2018	

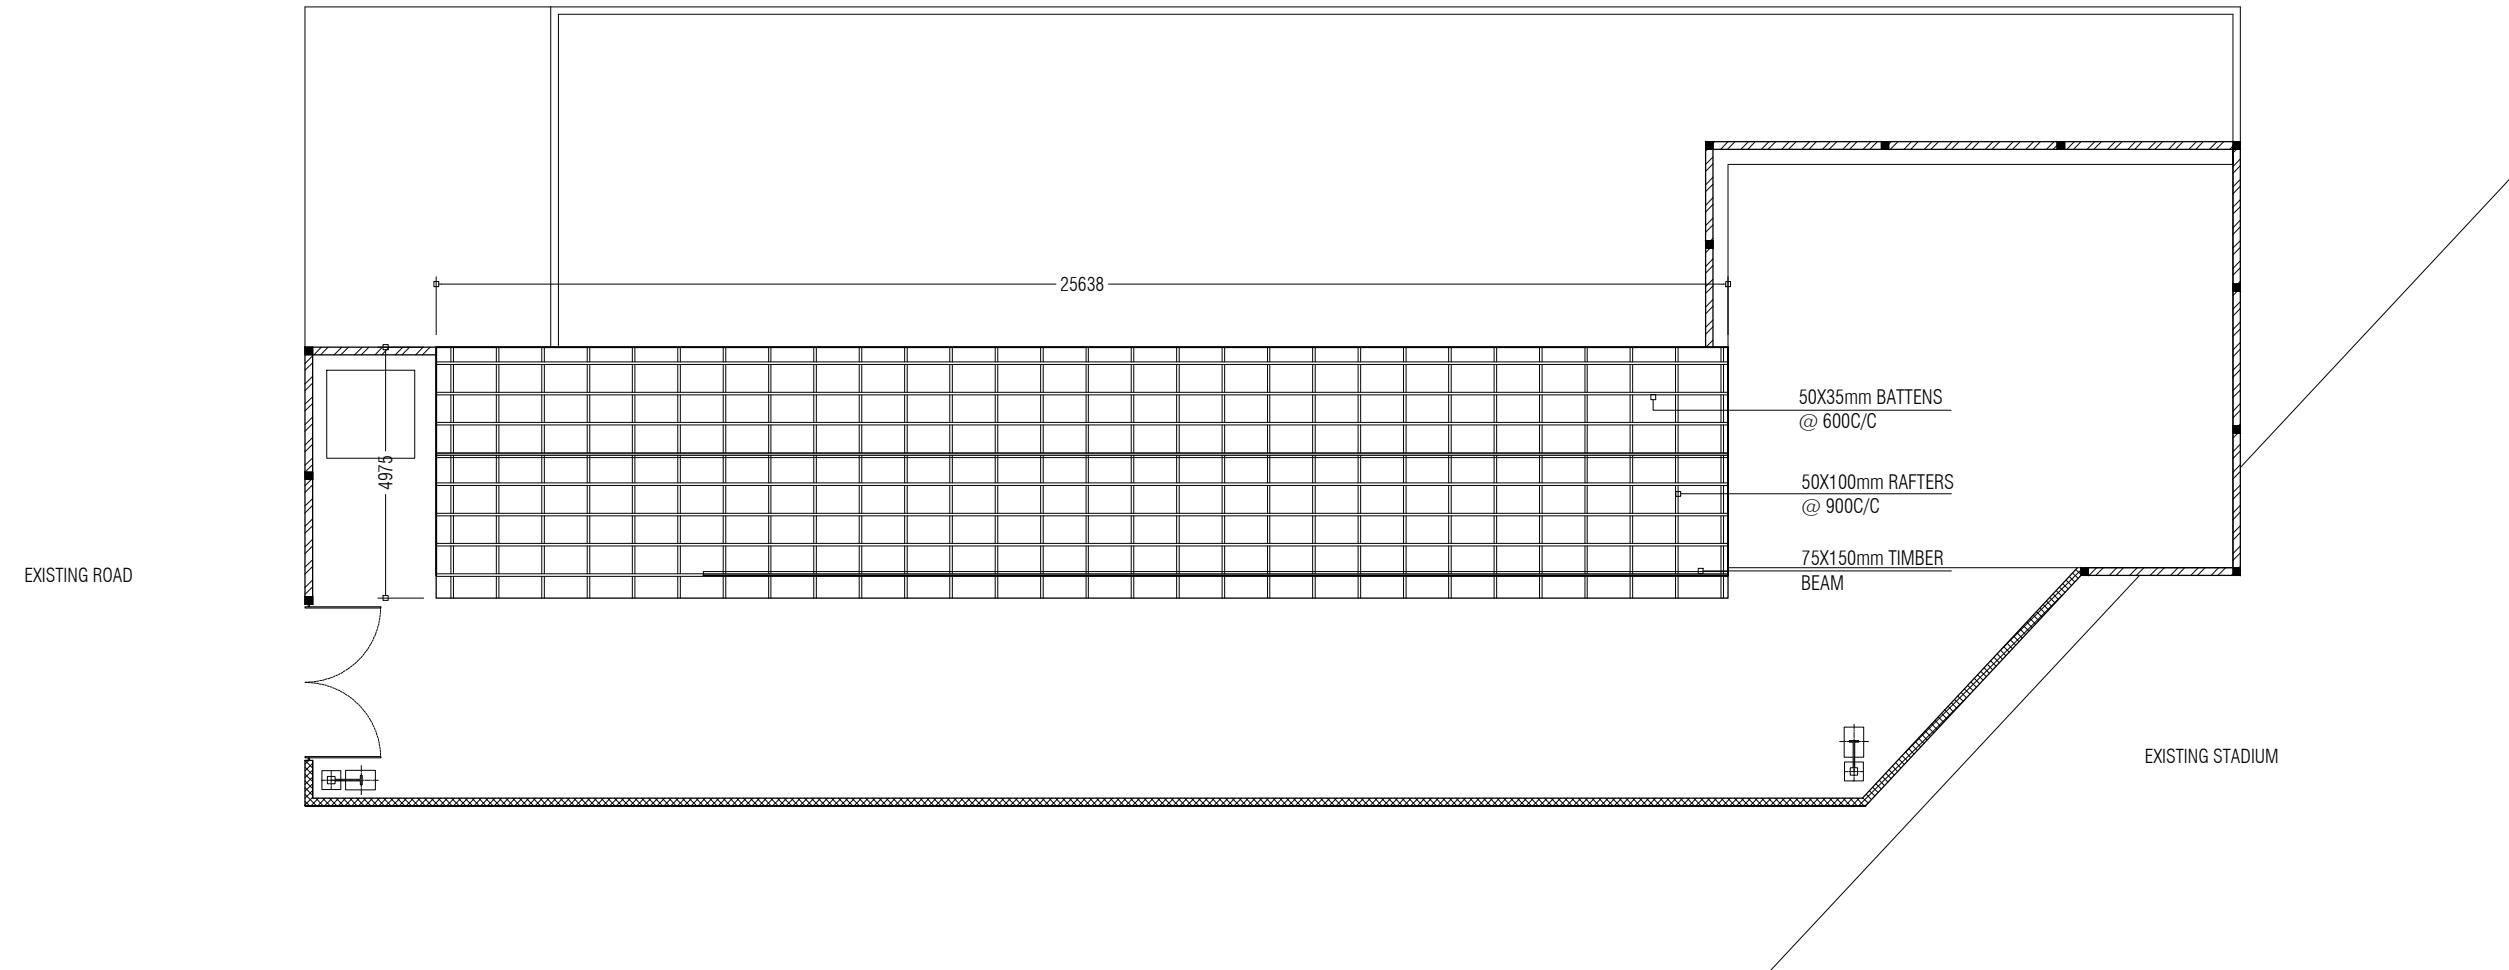

APPROVED BY	PROJECT	DESIGN BY	AMENDMENTS
 <p>MCEP MINISTRY OF ENVIRONMENT AND ENERGY GREEN BUILDING, HANDHUVAREE HIGUN, MAAFANNU, MALE' (20392), REPUBLIC OF MALDIVES, TEL: +960-3018431, +960-3018300, FAX: +960-328301</p>	UPGRADING OF WASTE MANAGEMENT CENTRE LH. KURENDHOO	AFRAZ	
	TITLE	STRUCTURE BY	
	ROOF STRUCTURE PLAN	AFRAZ	
	CLIENT DEPARTMENT	DRAWN BY	
	WMPC DEPARTMENT	AFRAZ	
	PAPER SIZE A3	SCALE 1:150	
	PAGE NO. 05	DWG NO. KUR A1-05	
		DATE 08.07.2018	

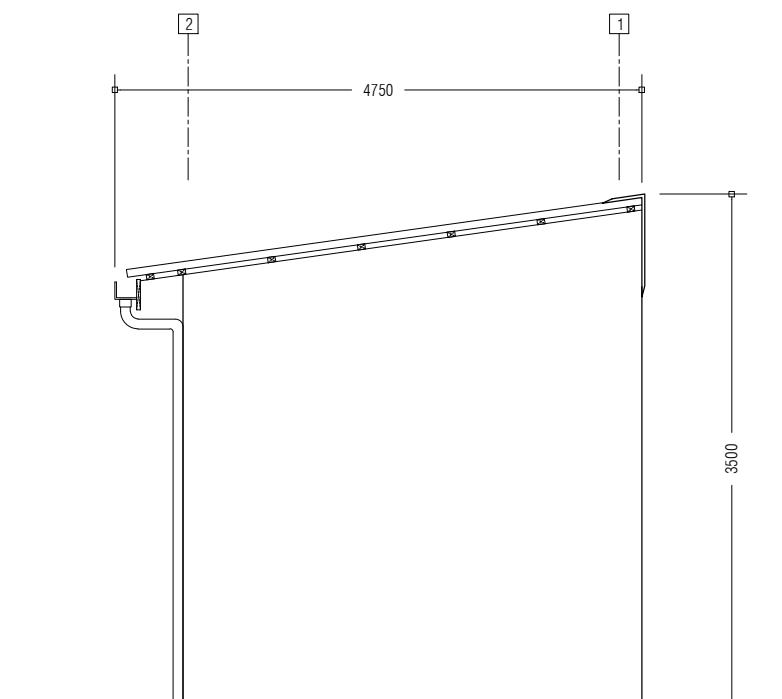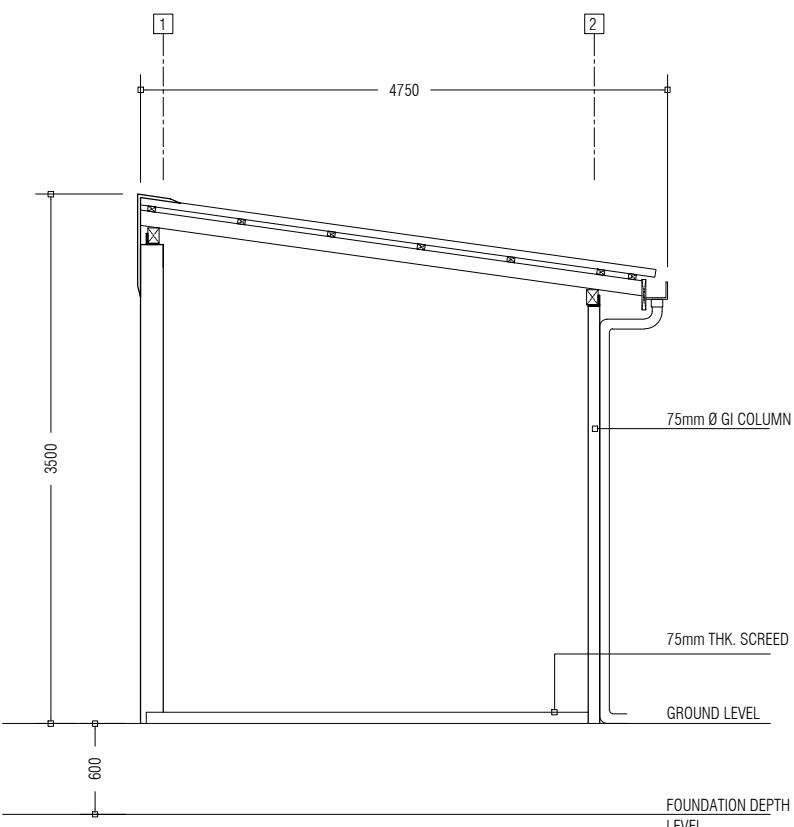
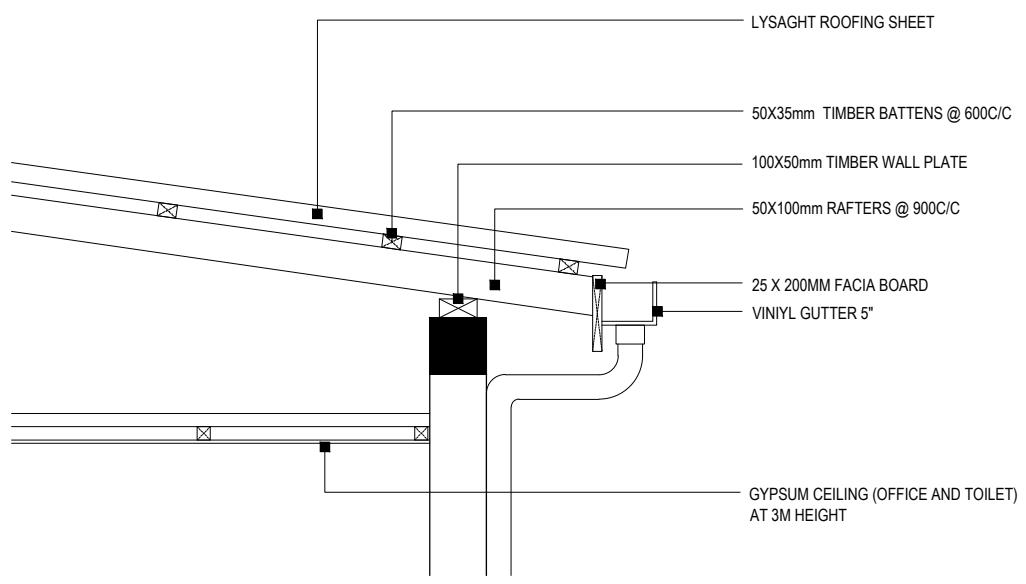
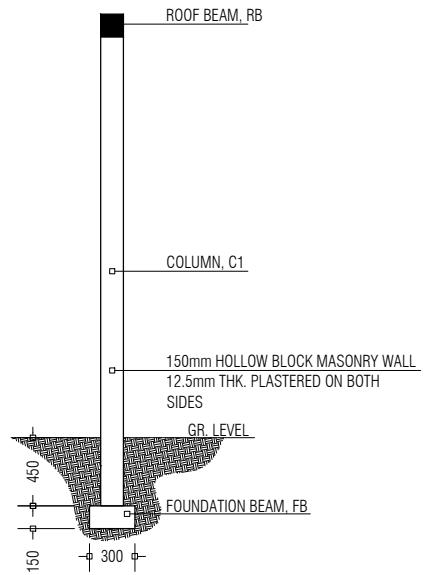
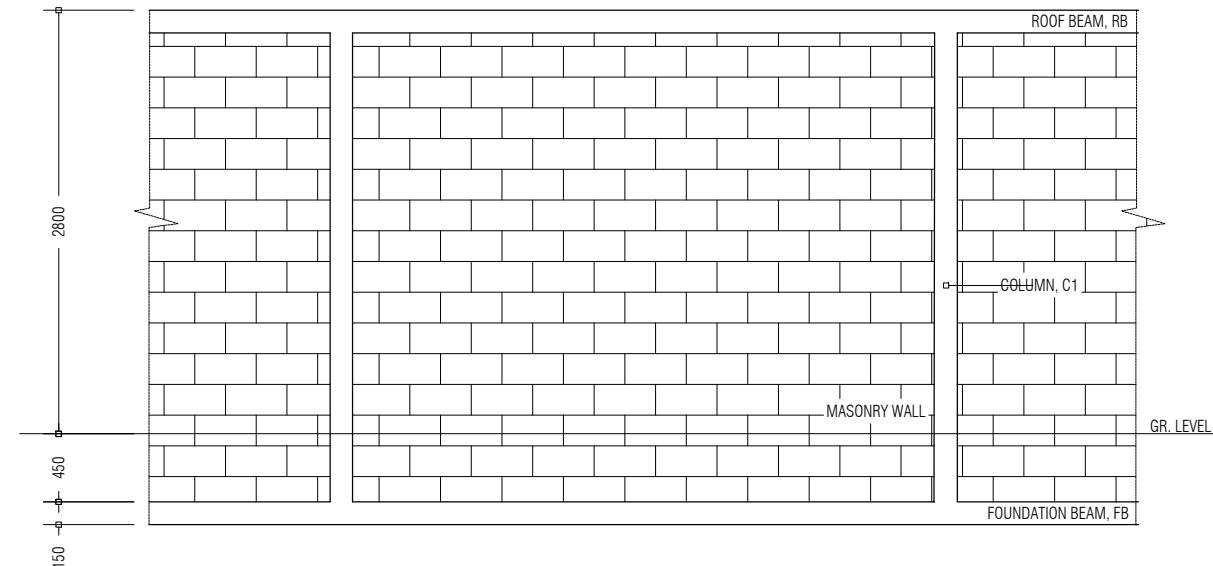
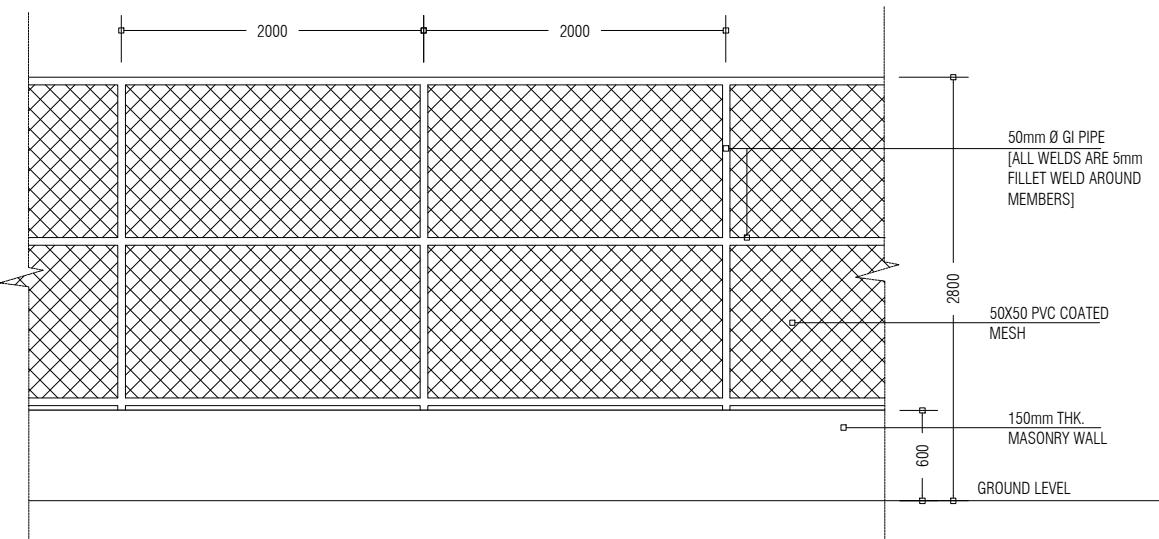


APPROVED BY	PROJECT	DESIGN BY	AMENDMENTS
 <p>MCEP MINISTRY OF ENVIRONMENT AND ENERGY GREEN BUILDING, HANDHUVAREE HIGUN, MAAFANNU, MALE' (20392), REPUBLIC OF MALDIVES, TEL: +960-3018431, +960-3018300, FAX: +960-328301</p>	UPGRADING OF WASTE MANAGEMENT CENTRE LH. KURENDHO	AFRAZ	
	TITLE	STRUCTURE BY	
	SECTIONS, ELEVATIONS, DETAILS	AFRAZ	
	CLIENT DEPARTMENT	DRAWN BY	
	WMPC DEPARTMENT	AFRAZ	
	PAPER SIZE A3	SCALE 1:50, 1:20	
	PAGE NO. 06	DWG NO. KUR A1-06	
		DATE 08.07.2018	

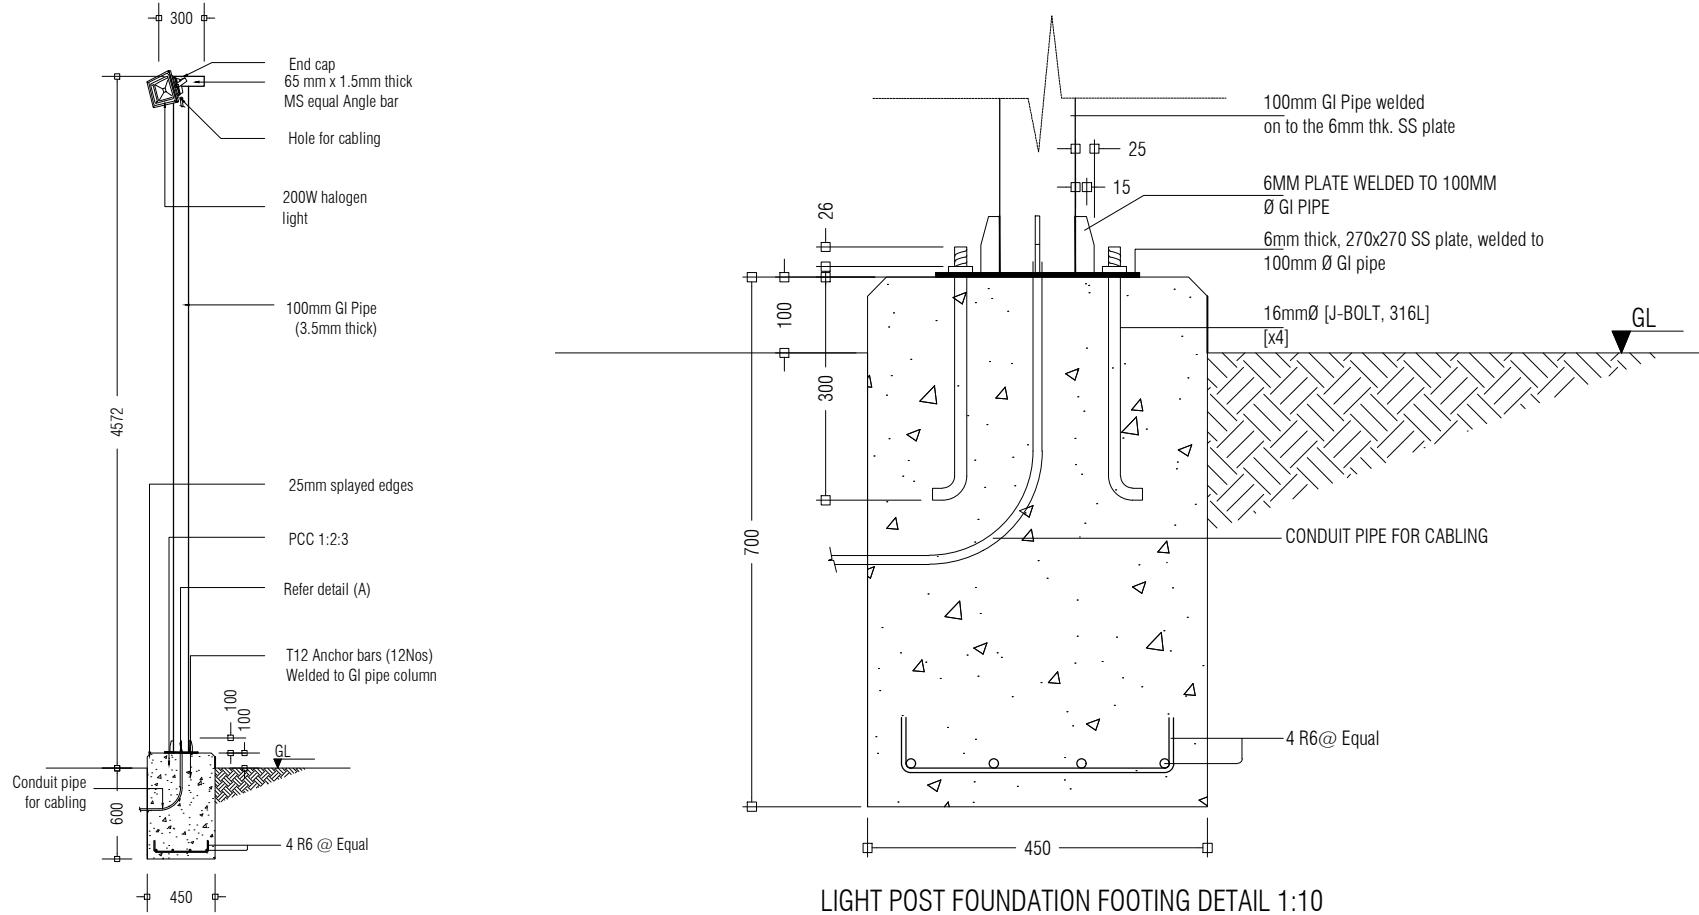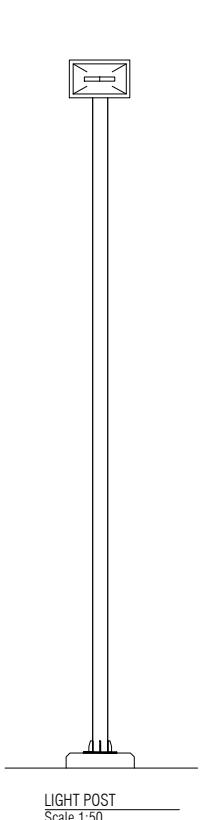

Note:


- * Concrete cover: 50mm
- * GI pipe to be painted with 1 coat of sealer
- & 2 coats of finishing paint. (Sigma, maroon colour)

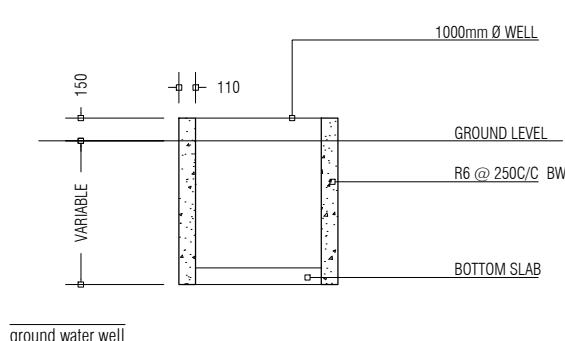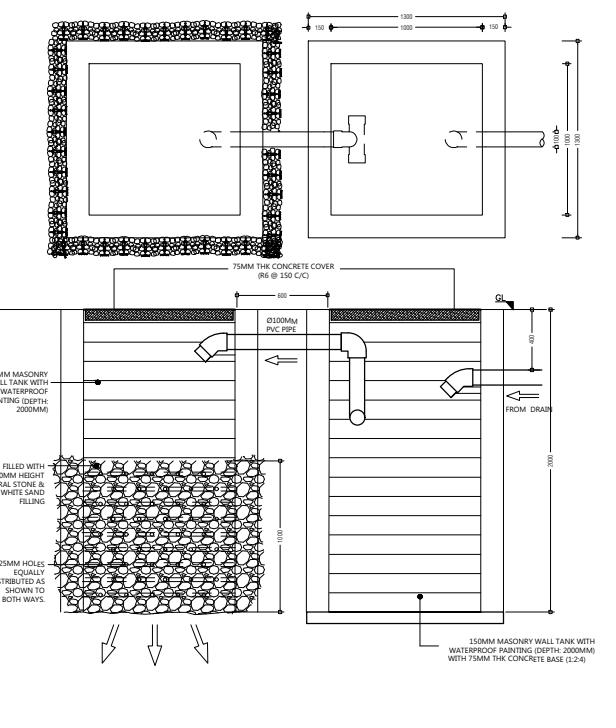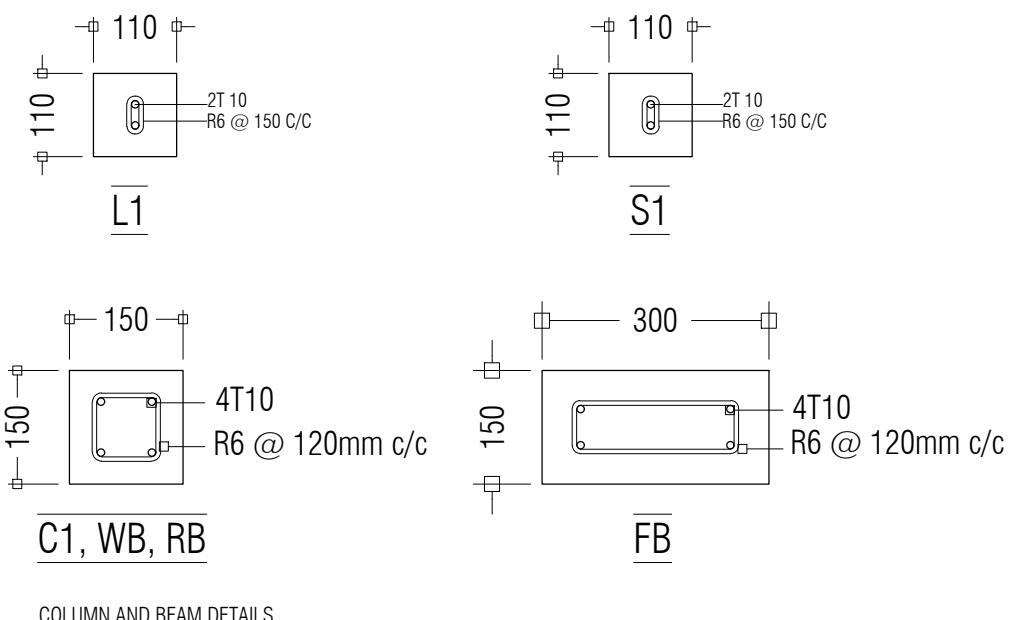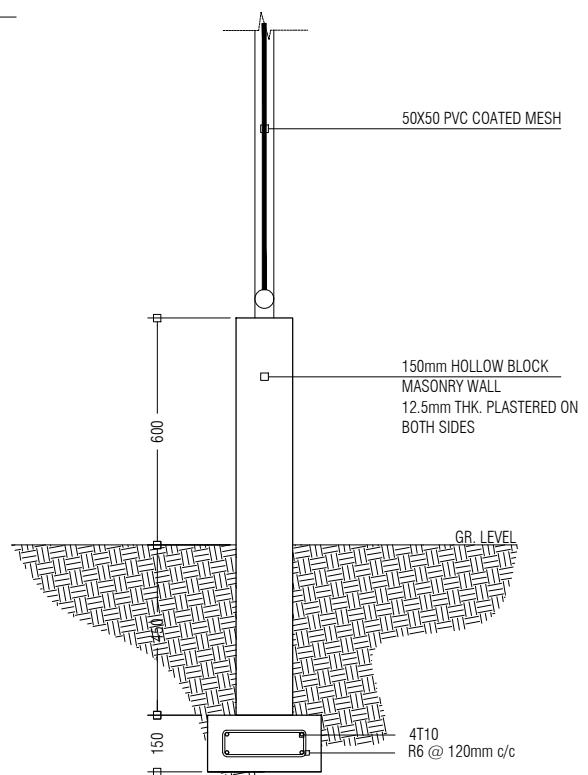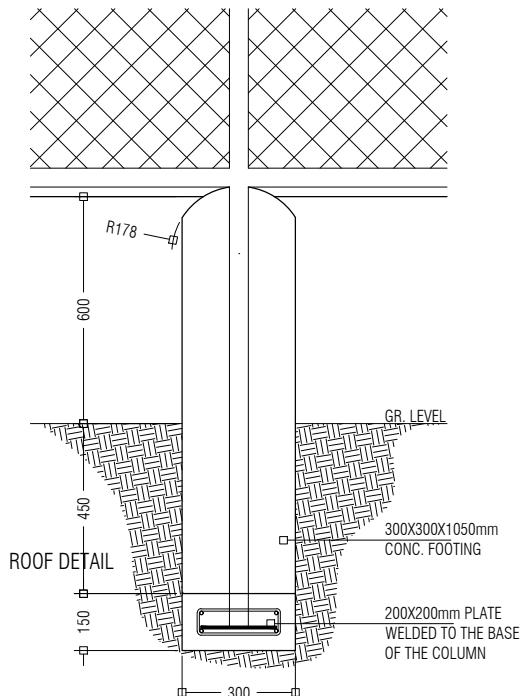

APPROVED BY	PROJECT	DESIGN BY	AMENDMENTS
	UPGRADING OF WASTE MANAGEMENT CENTRE LH. KURENDHO	AFRAZ	
	TITLE	STRUCTURE BY	
	DETAILS	AFRAZ	
	CLIENT DEPARTMENT	DRAWN BY	
	WMPC DEPARTMENT	AFRAZ	
	PAPER SIZE A3	SCALE 1:50, 1:10, 1:20	
	PAGE NO. 07	DWG NO. KUR A1-07	
		DATE 08.07.2018	



MCEP
MINISTRY OF ENVIRONMENT AND ENERGY
GREEN BUILDING, HANDHUVAREE HIGUN,
MAAFANNU, MALE' (20392), REPUBLIC OF MALDIVES,
TEL: +960-3018431, +960-3018300, FAX: +960-328301

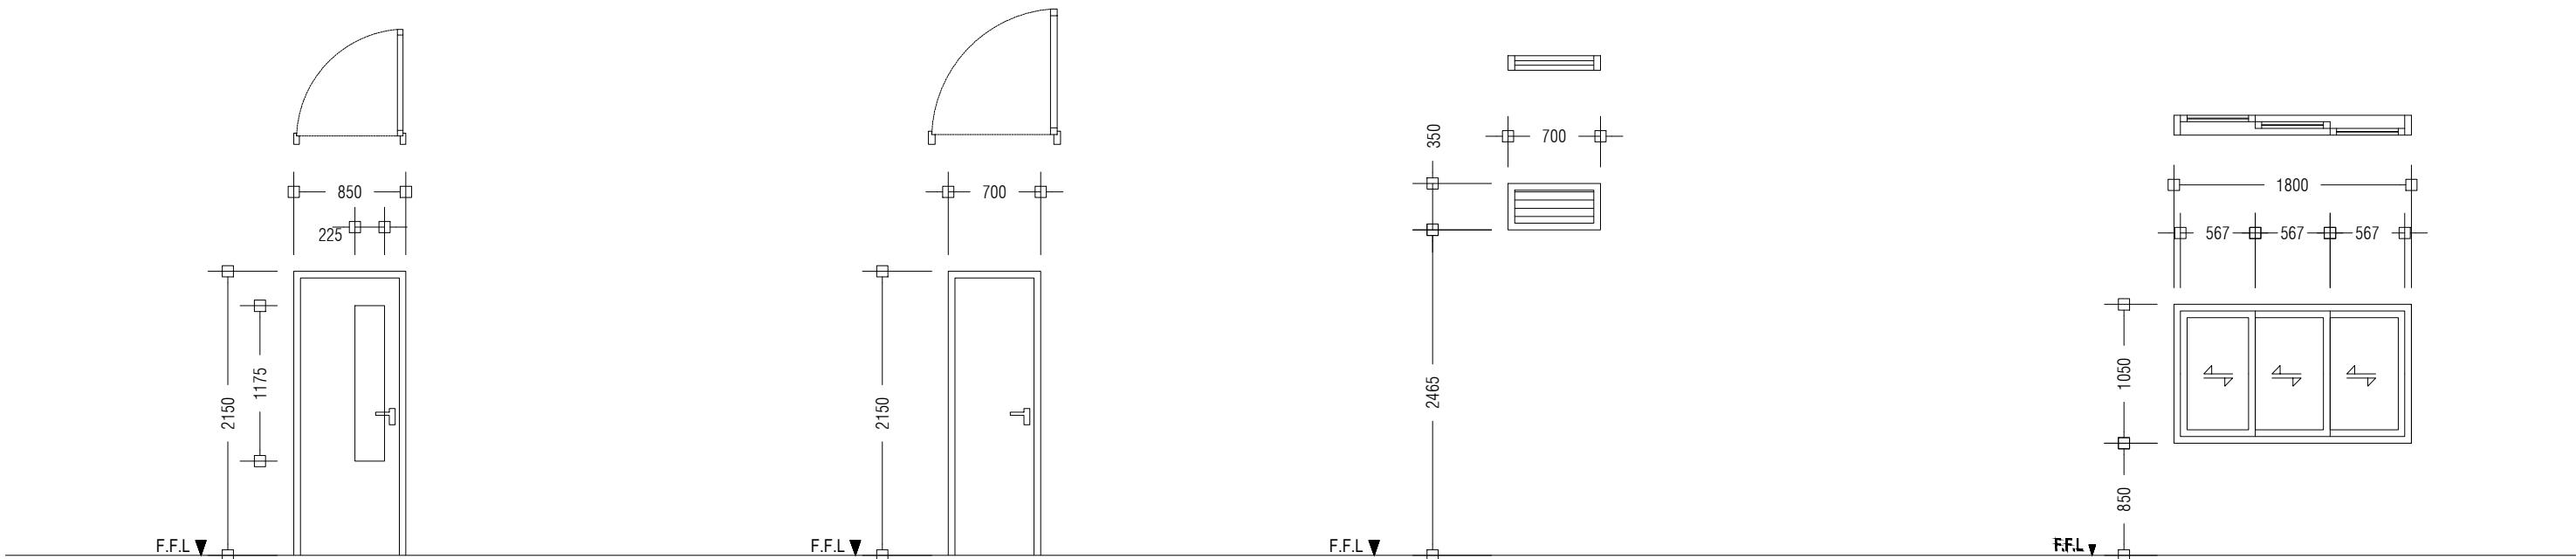

(D2)	SWING TYPE DOOR
REMARKS	ALUMINUM DOOR WITH CLEAR GLASS PANEL 01 DOOR KNOB WITH LOCK SET 04 HINGES DOOR STOPPER, FINISHED WITH WHITE COATED PAINT
LOCATION	GROUND FLOOR
QUANTITY	NO.S 01
OPEN AREA	1.83 m ²

(D3)	SWING TYPE DOOR
REMARKS	ALUMINUM DOOR WITH DOOR KNOB AND 1 LOCK SET
LOCATION	GROUND FLOOR
QUANTITY	NO.S 01
OPEN AREA	1.51m ²

(W1)	ALUNIUM LOUVER WINDOW
REMARKS	ALUMINUM FRAMED, ALUMINUM LOUVERED, FINISHED WITH WHITE COATED PAINT
LOCATION	GROUND FLOOR
QUANTITY	NO.S 1
OPEN AREA	0.15 m ²

(W2)	ALUMINIUM SLIDING WINDOW
REMARKS	ALUMINUM FRAMED, TINTED BLACK GLASS, FINISHED WITH TIMBER POWDER COATED PAINT
LOCATION	GROUND FLOOR
QUANTITY	NO.S 01
OPEN AREA	1.89 m ²

APPROVED BY	PROJECT	DESIGN BY	AMENDMENTS
MCEP MINISTRY OF ENVIRONMENT AND ENERGY GREEN BUILDING, HANDHUVAREE HIGUN, MAAFANNU, MALE' (20392), REPUBLIC OF MALDIVES, TEL: +960-3018431, +960-3018300, FAX: +960-328301	UPGRADING OF WASTE MANAGEMENT CENTRE LH. KURENDHOO	AFRAZ	
	TITLE	STRUCTURE BY	
	DOOR AND WINDOW SCHEDULE	AFRAZ	
	CLIENT DEPARTMENT	DRAWN BY	
	WMPC DEPARTMENT	AFRAZ	
	PAPER SIZE A3	SCALE 1:150	
	PAGE NO. 08	DWG NO. KUR A1-08	
		DATE 08.07.2018	

18W CEILING
MOUNT LIGHT
(WARM WHITE)




13AMP DOUBLE
SOCKET




3 PHASE, 15A
POWER POINTS
[1.5m ABOVE
GROUND]



CEILING FAN

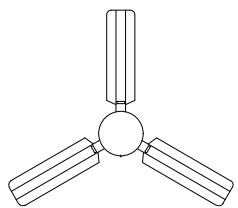

EMERGENCY
LIGHT WITH
POWER SOCKET

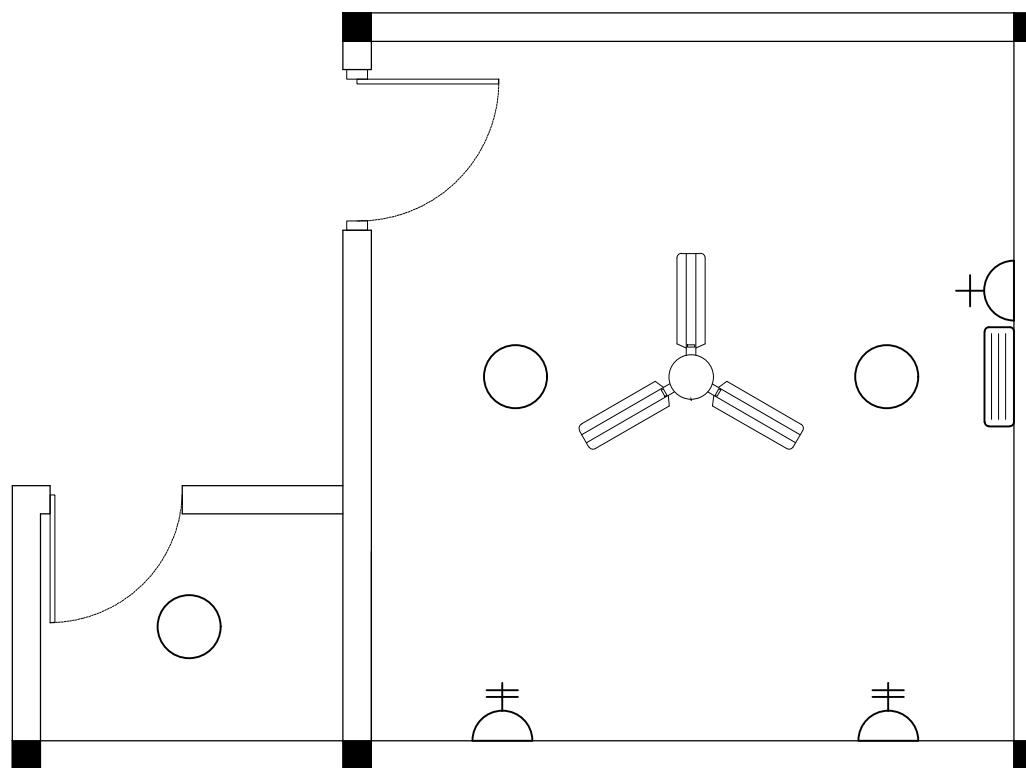

OFFICE/TOILET

APPROVED BY	PROJECT	DESIGN BY	AMENDMENTS
 MCEP MINISTRY OF ENVIRONMENT AND ENERGY GREEN BUILDING, HANDHUVAREE HIGUN, MAAFANNU, MALE' (20392), REPUBLIC OF MALDIVES, TEL: +960-3018431, +960-3018300, FAX: +960-328301	UPGRADING OF WASTE MANAGEMENT CENTRE LH. KURENDHOO	AFRAZ	
	TITLE	STRUCTURE BY	
	ELECTRICAL LAYOUT	AFRAZ	
	CLIENT DEPARTMENT	DRAWN BY	
	WMPC DEPARTMENT	AFRAZ	
	PAPER SIZE A3	SCALE 1:40	
	PAGE NO. 09	DWG NO. KUR A1-09	
		DATE 08.07.2018	