


CONSTRUCTION OF M.DHIGGARU
ISLAND WASTE AND RESOURCE MANAGEMENT CENTRE




PREPARED BY:
MINISTRY OF CLIMATE CHANGE, ENVIRONMENT AND ENERGY

FEBRUARY 2024

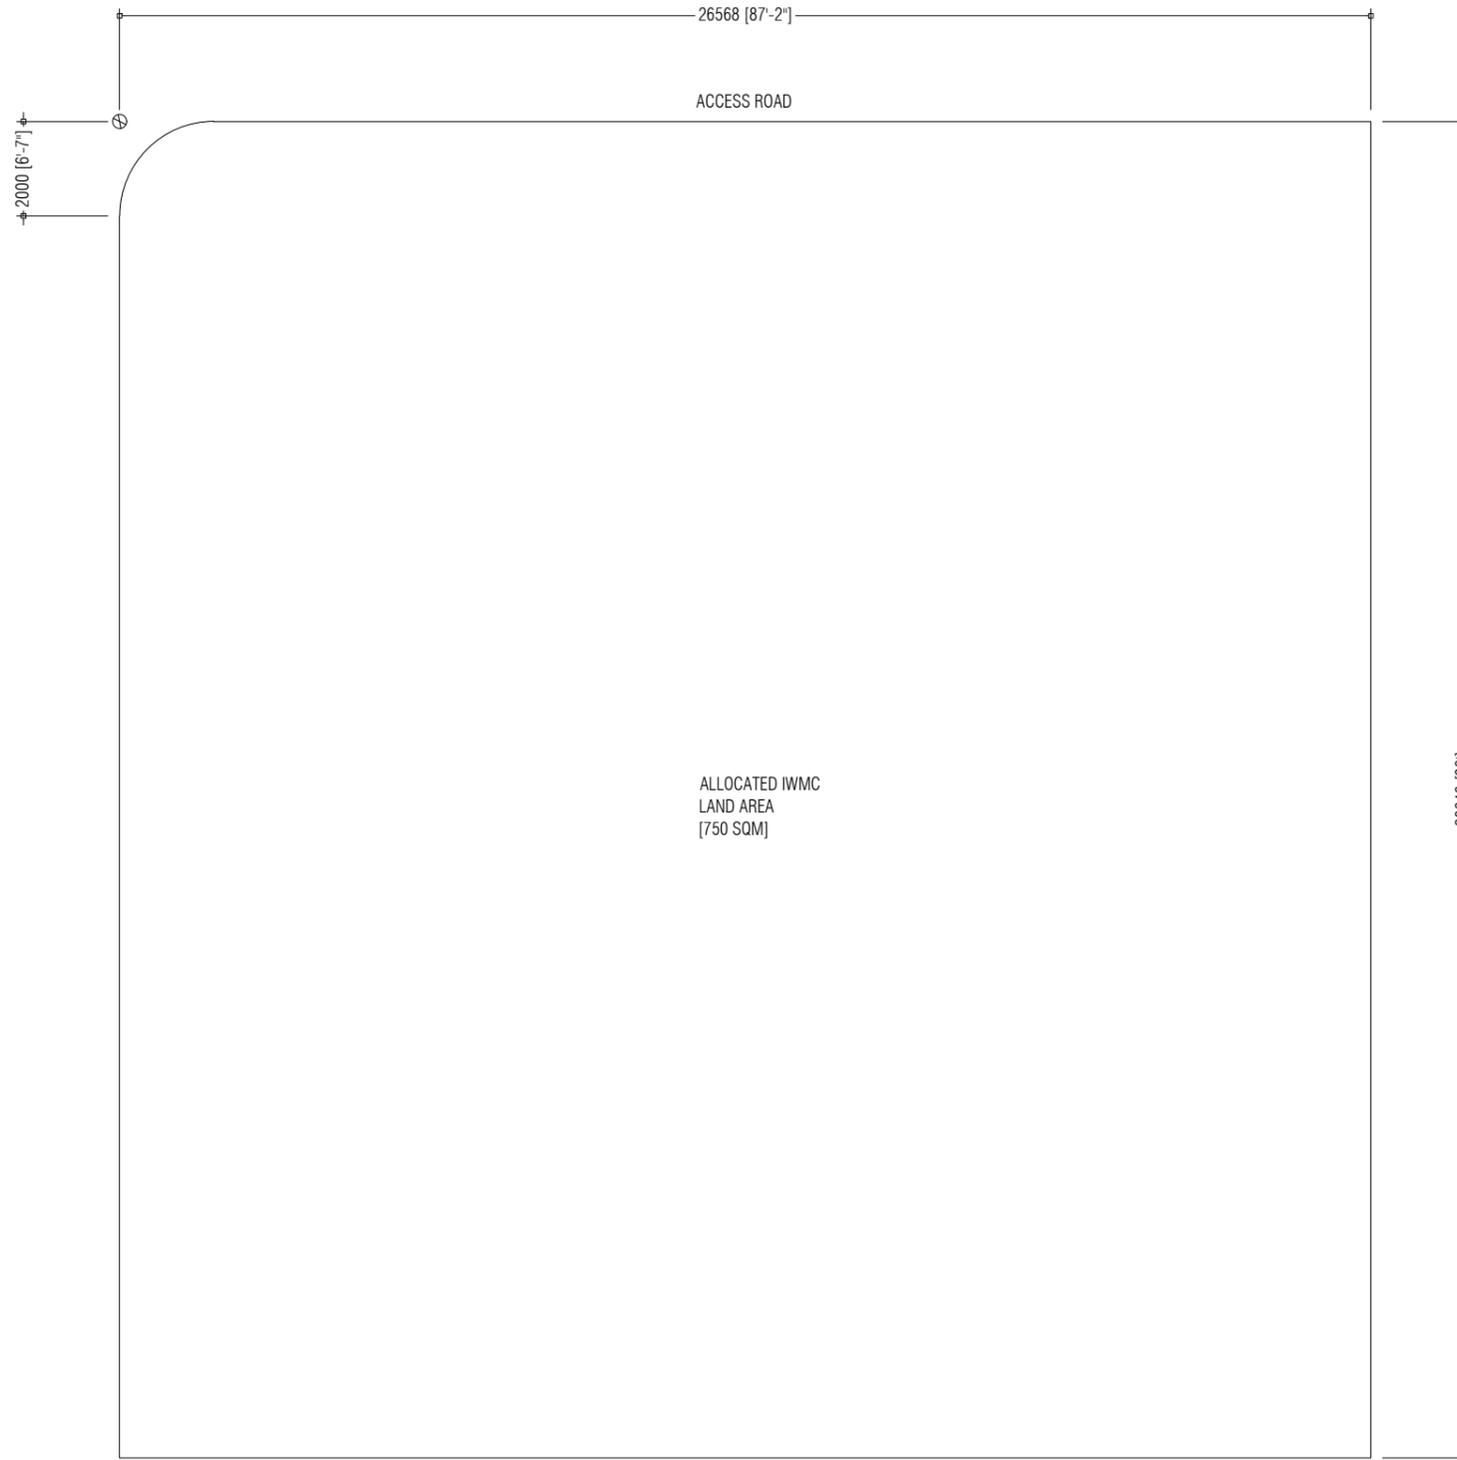


PREPARED BY	PROJECT	DESIGN BY	AMENDMENTS
 <p>MINISTRY OF CLIMATE CHANGE, ENVIRONMENT AND ENERGY GREEN BUILDING, HANDHUVAREE HIGUN, MAAFANNU, MALE' (20392), REPUBLIC OF MALDIVES, TEL: +960-3018431, +960-3018300, FAX: +960-328301</p>	CONSTRUCTION OF IWRMC M.DHIGGARU	MA	
	TITLE	STRUCTURE BY	
	LOCATION PLAN	MA	
	CLIENT DEPARTMENT	DRAWN BY	
	WMPC DEPARTMENT	MA	
	PAPER SIZE A3	SCALE	1:150
	PAGE NO. 01	DWG NO.	DHIG-A1-01
	DATE	05.02.2024	

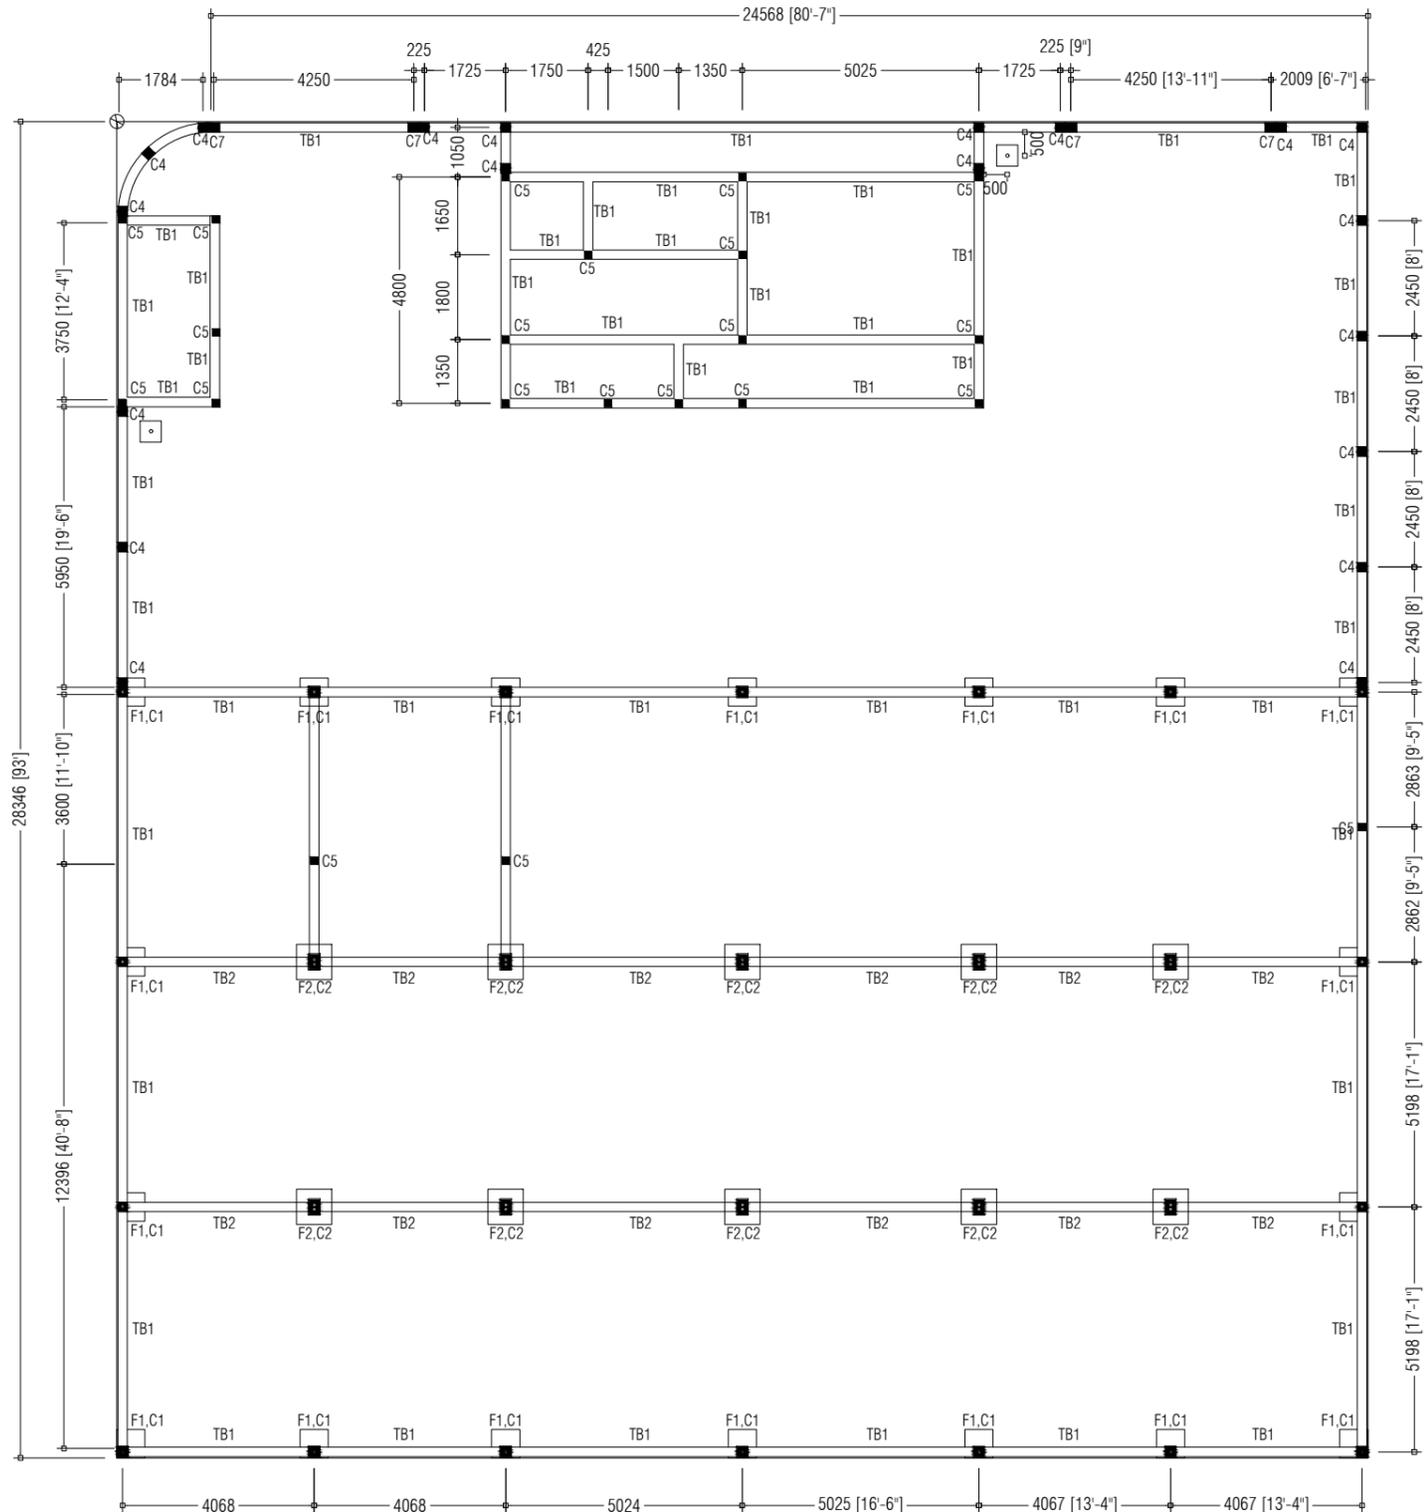

NOTE:
 TIE BEAMS
 LAMP POST FOOTING [450X450mm]

PREPARED BY	PROJECT	DESIGN BY	AMENDMENTS
 MINISTRY OF CLIMATE CHANGE, ENVIRONMENT AND ENERGY GREEN BUILDING, HANDHUVAREE HIGUN, MAAFANNU, MALE' (20392), REPUBLIC OF MALDIVES, TEL: +960-3018431, +960-3018300, FAX: +960-328301	CONSTRUCTION OF IWRMC M.DHIGGARU	MA	
	TITLE FOUNDATION PLAN	STRUCTURE BY MA	
	CLIENT DEPARTMENT WMPC DEPARTMENT	DRAWN BY MA	
	PAPER SIZE A3	SCALE 1:150	
	PAGE NO. 03	DWG NO. DHIG-A1-03	
		DATE 05.02.2024	

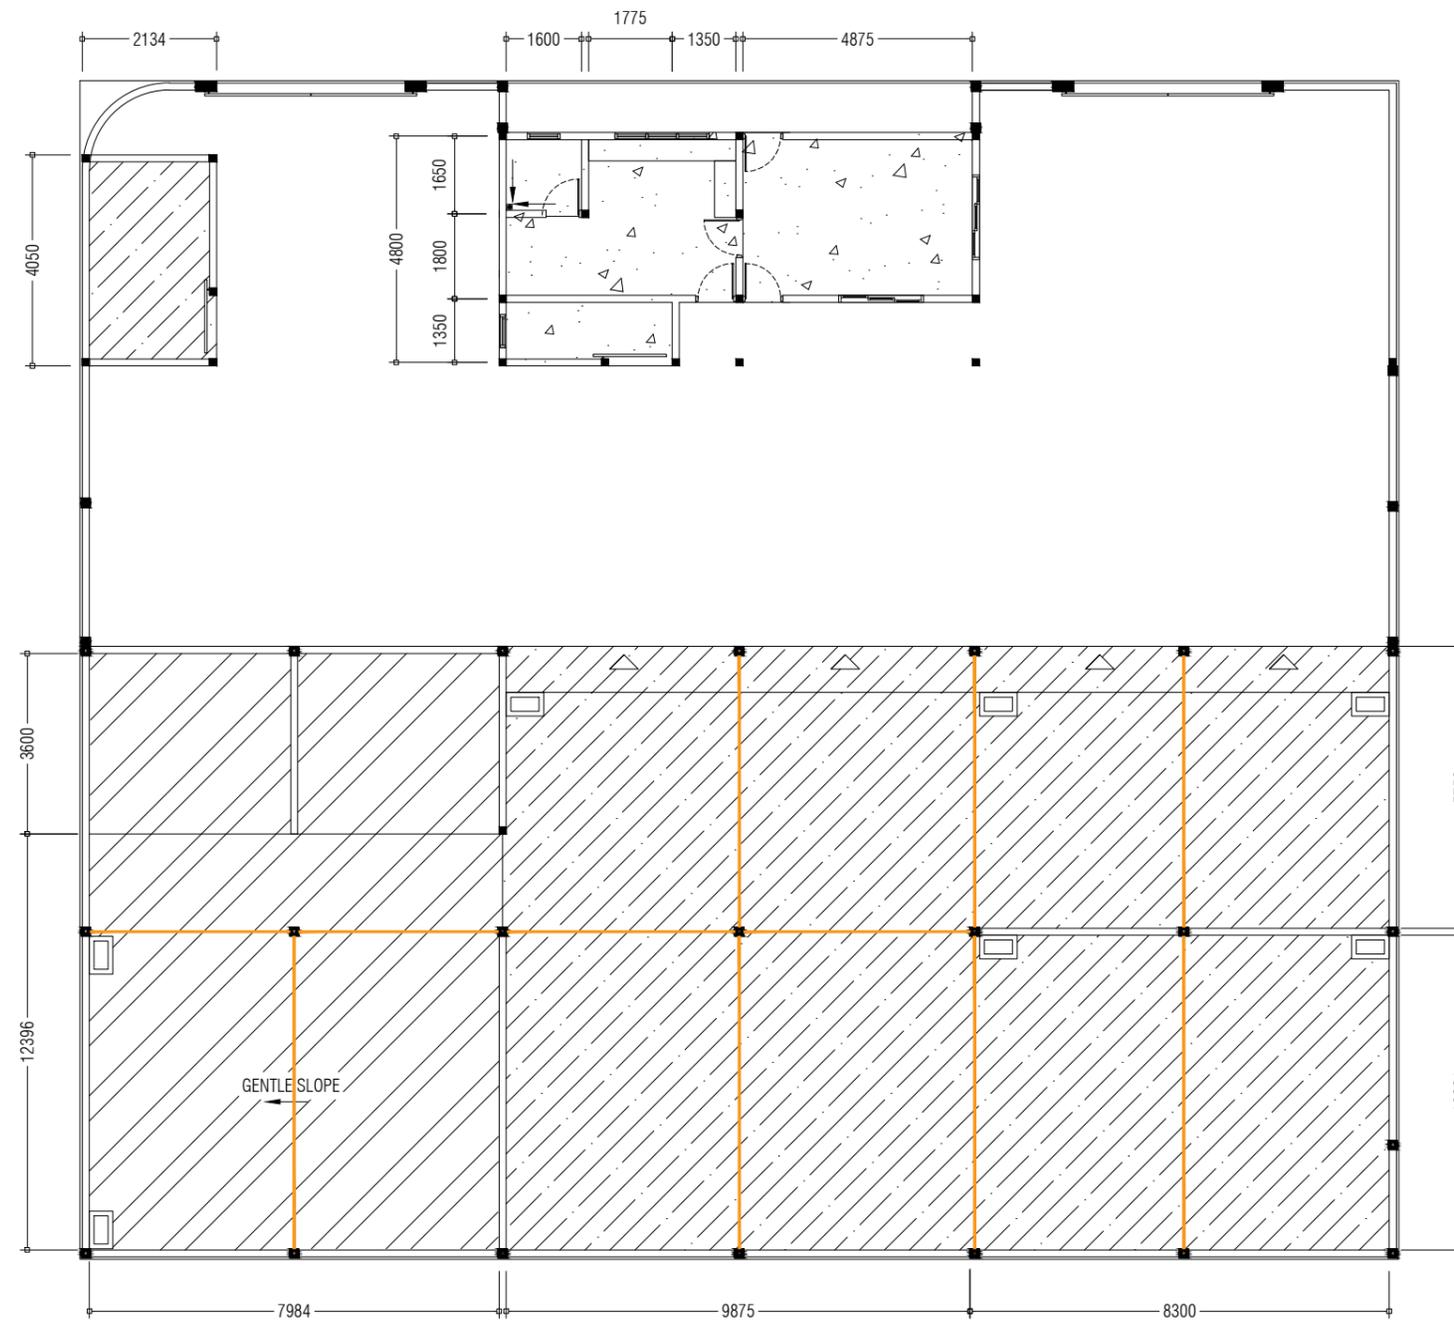

NOTE:

-  75mm FLOOR SLAB
-  100mm FLOOR SLAB
-  100mm FLOOR SLAB
-  EXPANSION JOINTS

PREPARED BY

PROJECT

DESIGN BY

AMENDMENTS

CONSTRUCTION OF IWRMC
M.DHIGGARU

MA

TITLE

STRUCTURE BY

FLOOR SLAB PLAN

MA

CLIENT DEPARTMENT

DRAWN BY

WMPC DEPARTMENT

MA

PAPER SIZE A3

SCALE

NTS

PAGE NO. 04

DWG NO.


DHIG-A1-04

DATE

05.02.2024



MINISTRY OF CLIMATE CHANGE, ENVIRONMENT AND ENERGY
GREEN BUILDING, HANDHUVAREE HIGUN,
MAAFANNU, MALE' (20392), REPUBLIC OF MALDIVES,
TEL: +960-3018431, +960-3018300, FAX: +960-328301

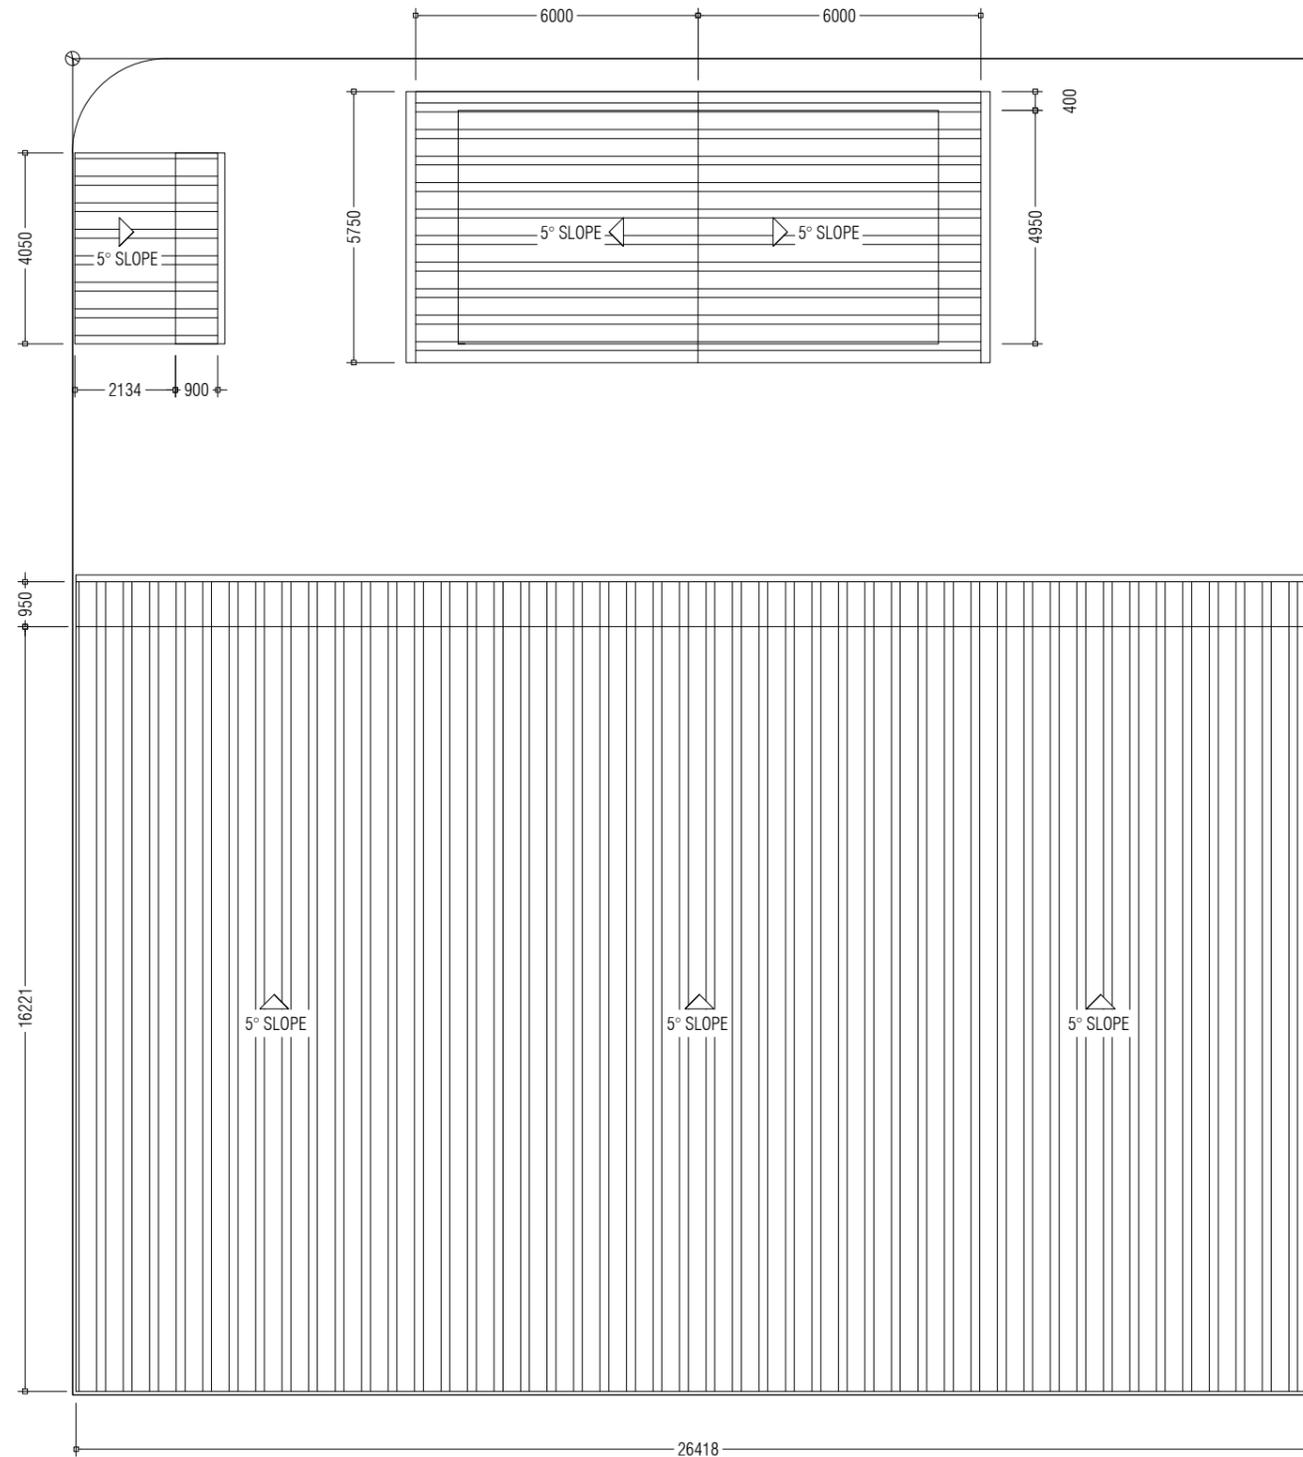

PREPARED BY

PROJECT
CONSTRUCTION OF IWRMC
M.DHIGGARU

DESIGN BY
MA

AMENDMENTS

TITLE
ROOF PLAN

STRUCTURE BY
MA

CLIENT DEPARTMENT
WMPC DEPARTMENT

DRAWN BY
MA

PAPER SIZE A3

SCALE NTS


PAGE NO. 05

DWG NO. DHIG-A1-05

DATE 05.02.2024



MINISTRY OF CLIMATE CHANGE, ENVIRONMENT AND ENERGY
GREEN BUILDING, HANDHUVAREE HIGUN,
MAAFANNU, MALÉ (20392), REPUBLIC OF MALDIVES,
TEL: +960-3018431, +960-3018300, FAX: +960-328301

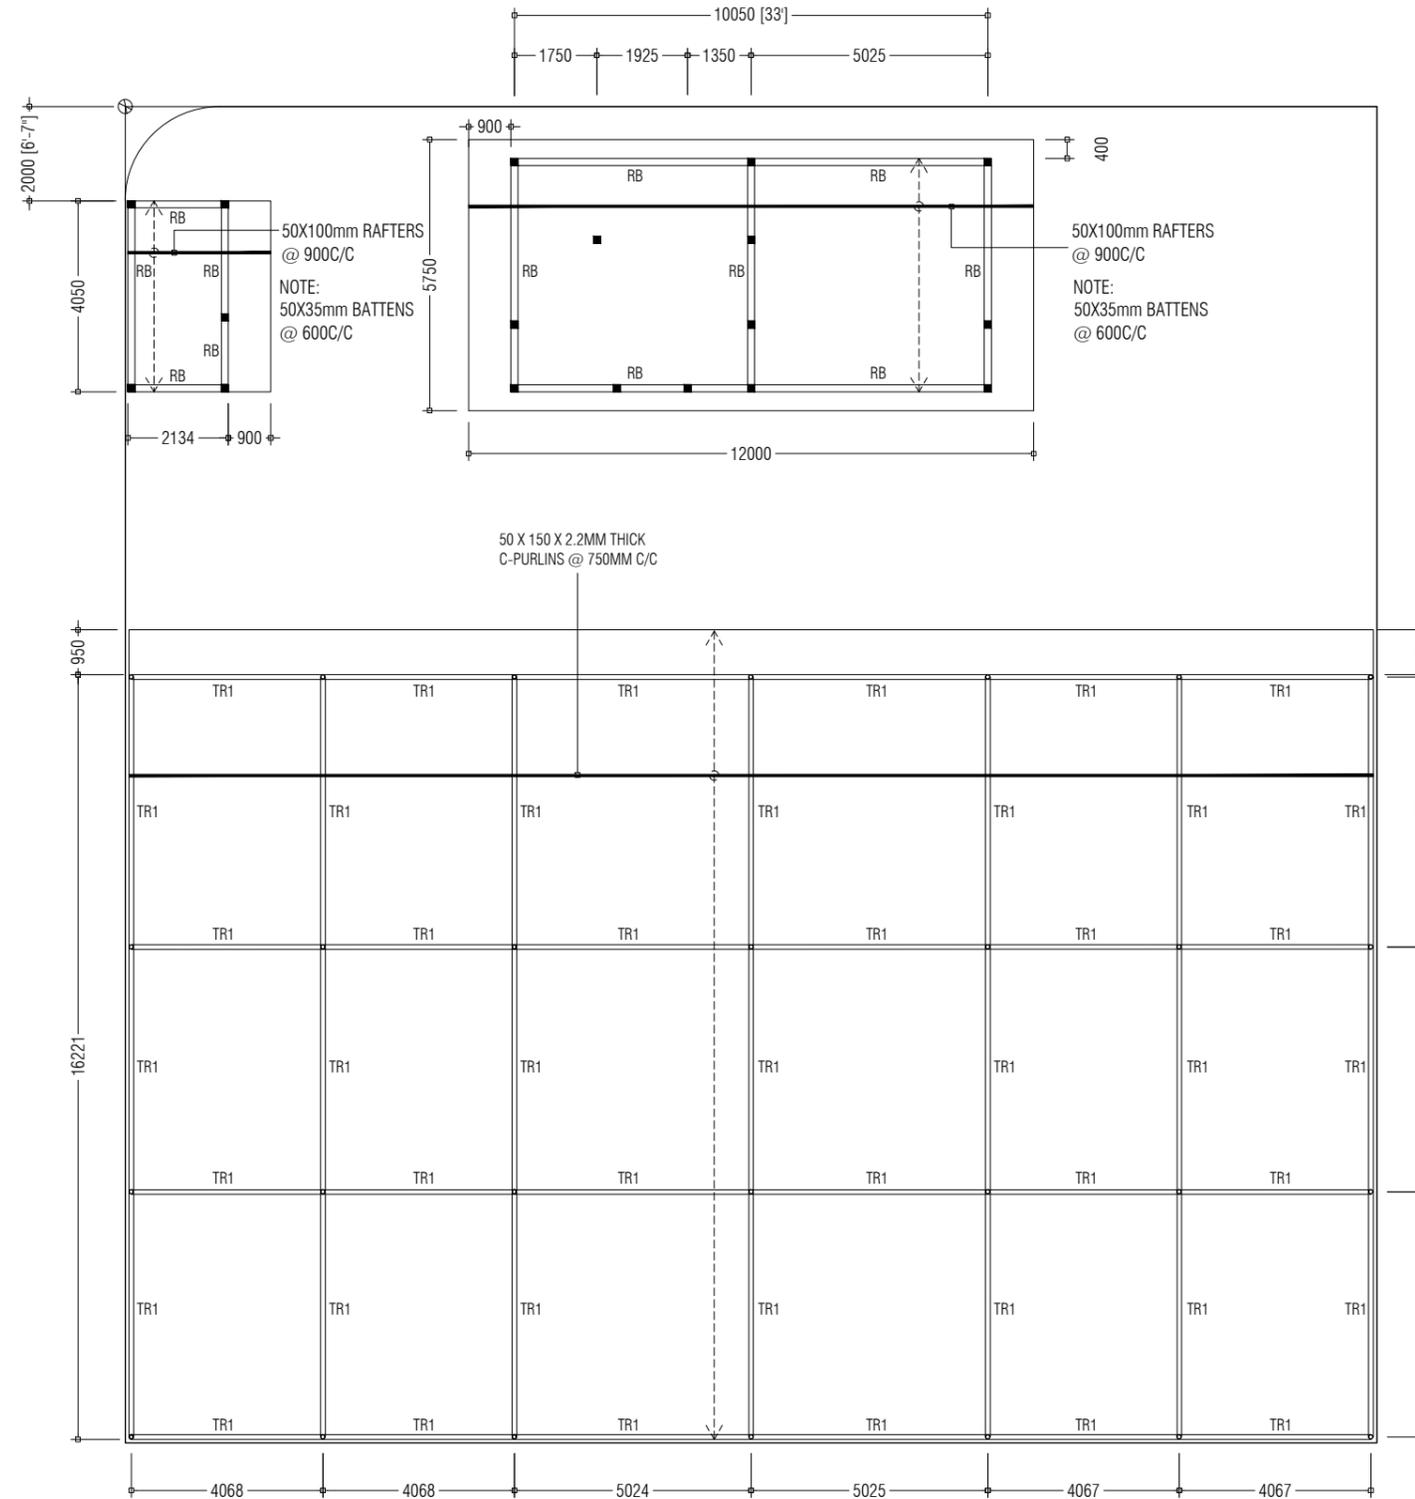

PREPARED BY

PROJECT

DESIGN BY

AMENDMENTS

CONSTRUCTION OF IWRMC
M.DHIGGARU

MA

TITLE

STRUCTURE BY

ROOF STRUCTURE PLAN

MA

CLIENT DEPARTMENT

DRAWN BY

WMPC DEPARTMENT

MA

PAPER SIZE

A3

SCALE

NTS

PAGE NO.

06

DWG NO.


DHIG-A1-06

DATE

05.02.2024



MINISTRY OF CLIMATE CHANGE, ENVIRONMENT AND ENERGY
GREEN BUILDING, HANDHUVAREE HIGUN,
MAAFANNU, MALE (20392), REPUBLIC OF MALDIVES,
TEL: +960-3018431, +960-3018300, FAX: +960-328301

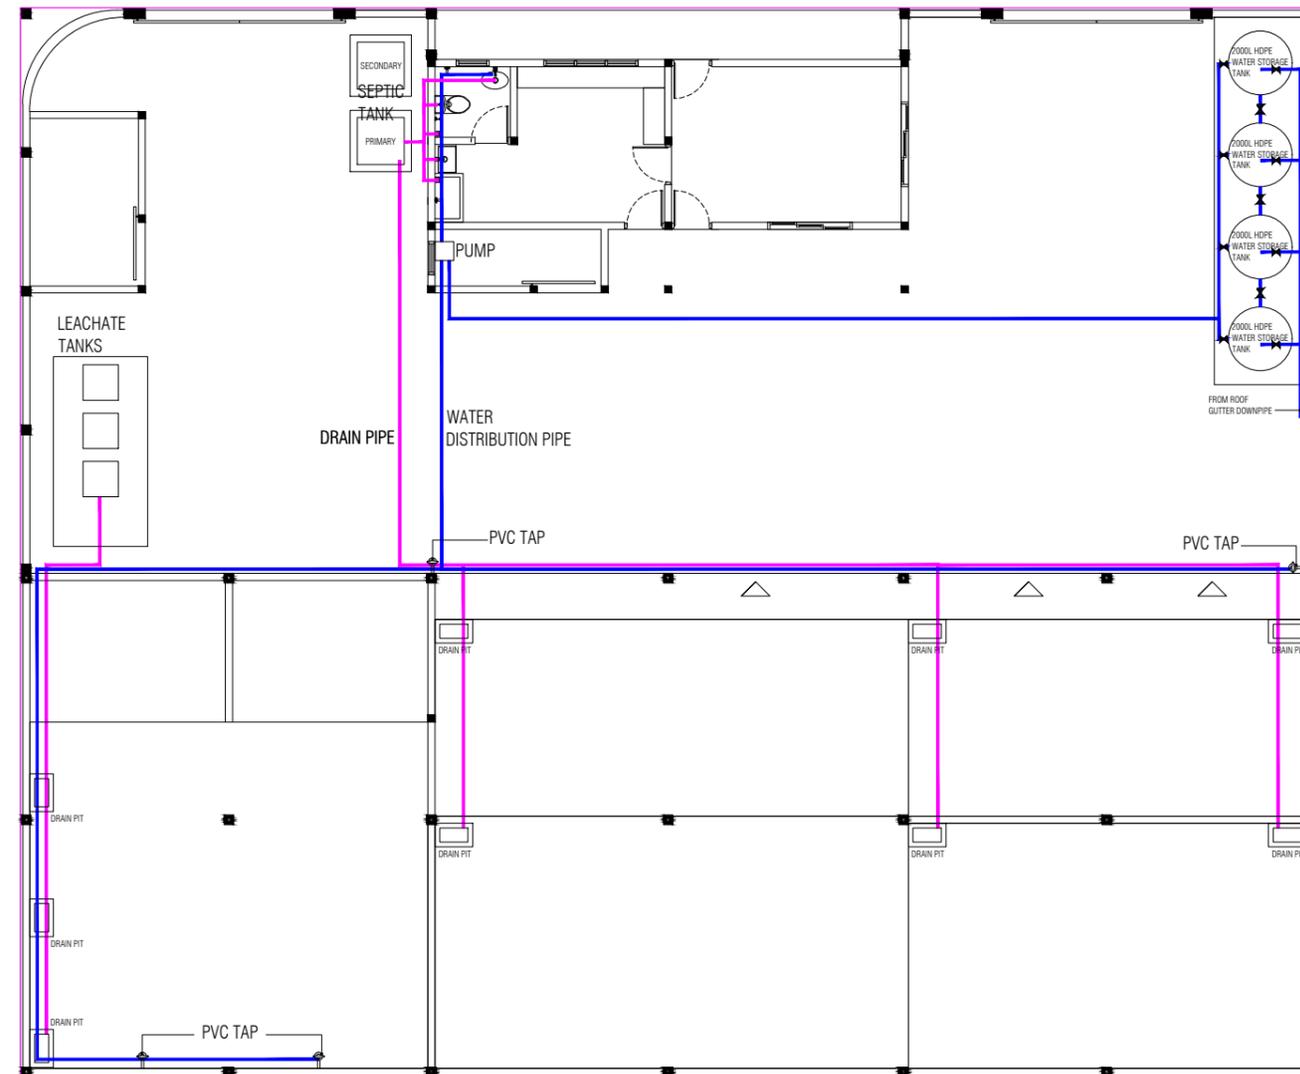

PREPARED BY

PROJECT
CONSTRUCTION OF IWRMC
M.DHIGGARU

DESIGN BY
MA

AMENDMENTS

AMENDMENTS

TITLE
PLUMBING PLAN

STRUCTURE BY
MA

CLIENT DEPARTMENT
WMPC DEPARTMENT

DRAWN BY
MA

PAPER SIZE A3

SCALE NTS


PAGE NO. 07


DWG NO. DHIG-A1-07

DATE 05.02.2024



 MINISTRY OF CLIMATE CHANGE, ENVIRONMENT AND ENERGY
GREEN BUILDING, HANDHUVAREE HIGUN,
MAAFANNU, MALE' (20392), REPUBLIC OF MALDIVES,
TEL: +960-3018431, +960-3018300, FAX: +960-328301

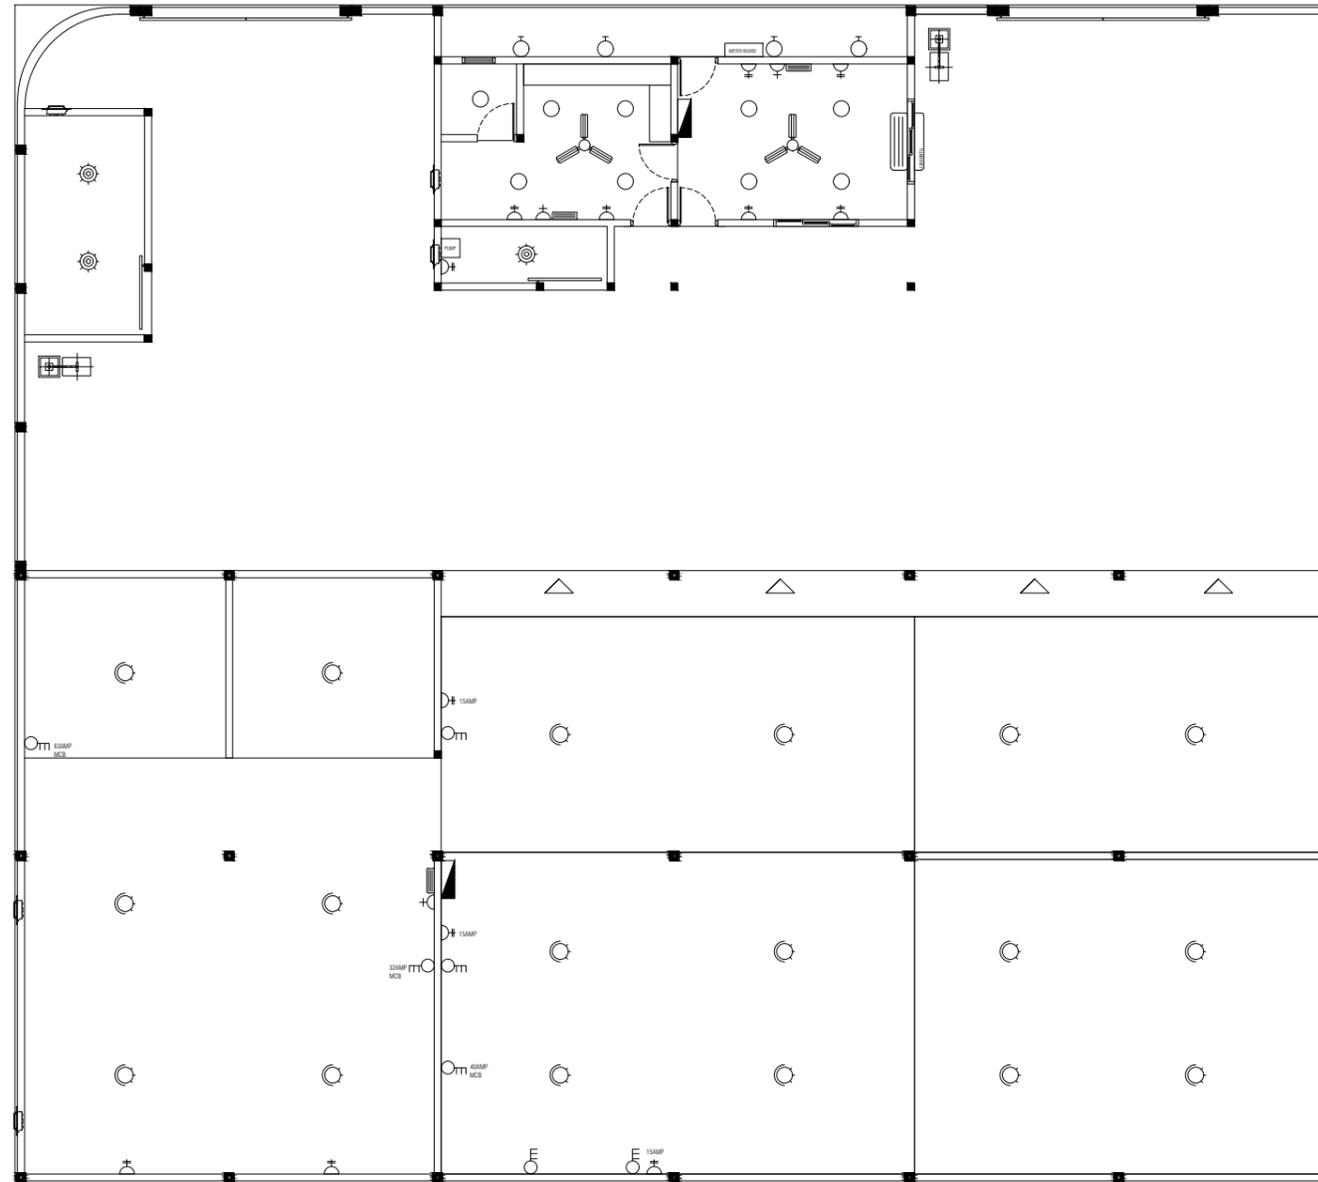

- METER BOARD (WEATHERPROOF) 
- DISTRIBUTION BOARDS 
- 20W LED LIGHT (DAY LIGHT) 
- 20W CEILING MOUNT LED LIGHT (WARM WHITE) 
- 20W WALL MOUNT EXTERIOR LED LIGHT (WARM WHITE) 
- 100W SWIVEL LED FLOOD LIGHT (DAY LIGHT) 
- 10W WALL MOUNT LED EMERGENCY LIGHT (DAY LIGHT) 
- 13AMP DOUBLE SOCKET 
- 15AMP DOUBLE SOCKET 
- 3 PHASE, POWER POINTS [1.5m ABOVE FL. LEVEL] [AS NOTED IN LAYOUT AND DETAILED IN BOO] 
- 3 PHASE, 32A SPIN SOCKETS [1.5m ABOVE FL. LEVEL] 
- CEILING FAN 56" 
- EXHAUST FAN 
- AC WITH OUTLET [12,000 BTU] 

PREPARED BY

PROJECT
CONSTRUCTION OF IWRMC
M.DHIGGARU

DESIGN BY
MA

AMENDMENTS

TITLE
ELECTRICAL PLAN

STRUCTURE BY
MA

CLIENT DEPARTMENT
WMPC DEPARTMENT

DRAWN BY
MA

PAPER SIZE A3

SCALE NTS


PAGE NO. 08

DWG NO. KOLH-A1-08


DATE 05.02.2024




MINISTRY OF CLIMATE CHANGE, ENVIRONMENT AND ENERGY
GREEN BUILDING, HANDHUVAREE HIGUN,
MAAFANNU, MALE' (20392), REPUBLIC OF MALDIVES,
TEL: +960-3018431, +960-3018300, FAX: +960-328301

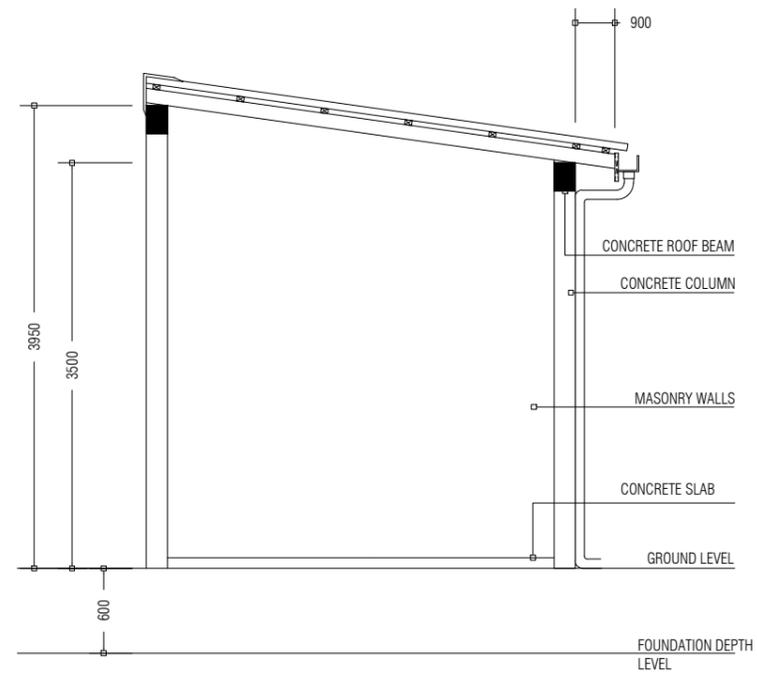

HAZARDOUS WASTE STORAGE BUILDING SECTION

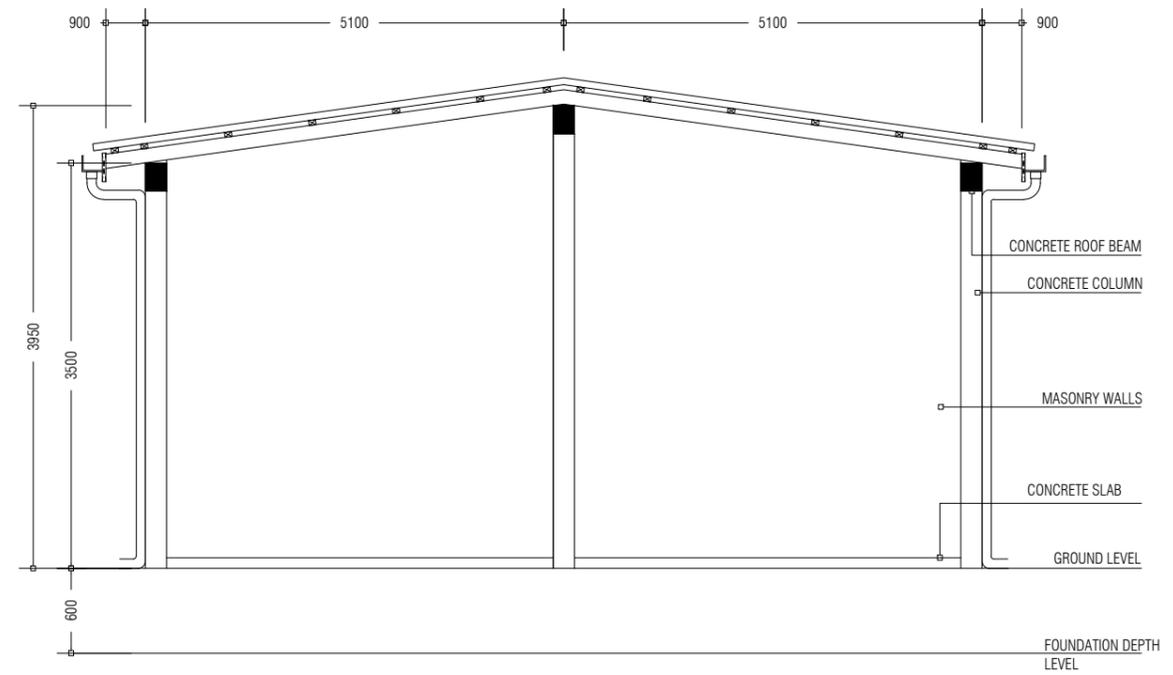

OFFICE / LOCKER BUILDING SECTION

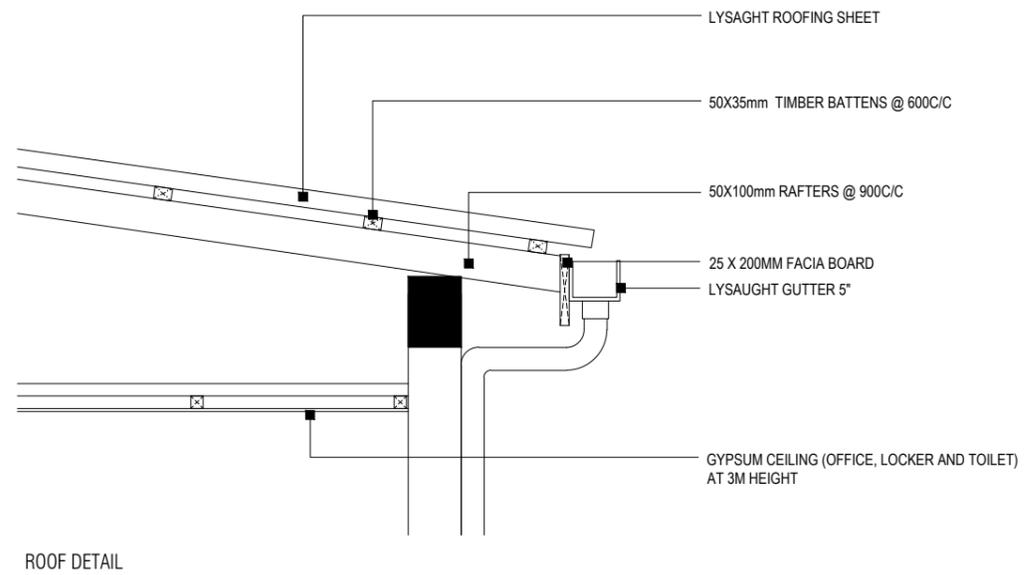

ROOF DETAIL

PREPARED BY

PROJECT
CONSTRUCTION OF IWRMC
M.DHIGGARU

DESIGN BY
MA

AMENDMENTS

TITLE
ELEVATIONS AND SECTIONS

STRUCTURE BY
MA

CLIENT DEPARTMENT
WMPC DEPARTMENT


DRAWN BY
MA

PAPER SIZE A3
PAGE NO. 09

SCALE NTS
DWG NO. DHIG-A2-09
DATE 05.02.2024




MINISTRY OF CLIMATE CHANGE, ENVIRONMENT AND ENERGY
GREEN BUILDING, HANDHUVAREE HIGUN,
MAAFANNU, MALÉ (20392), REPUBLIC OF MALDIVES,
TEL: +960-3018431, +960-3018300, FAX: +960-328301

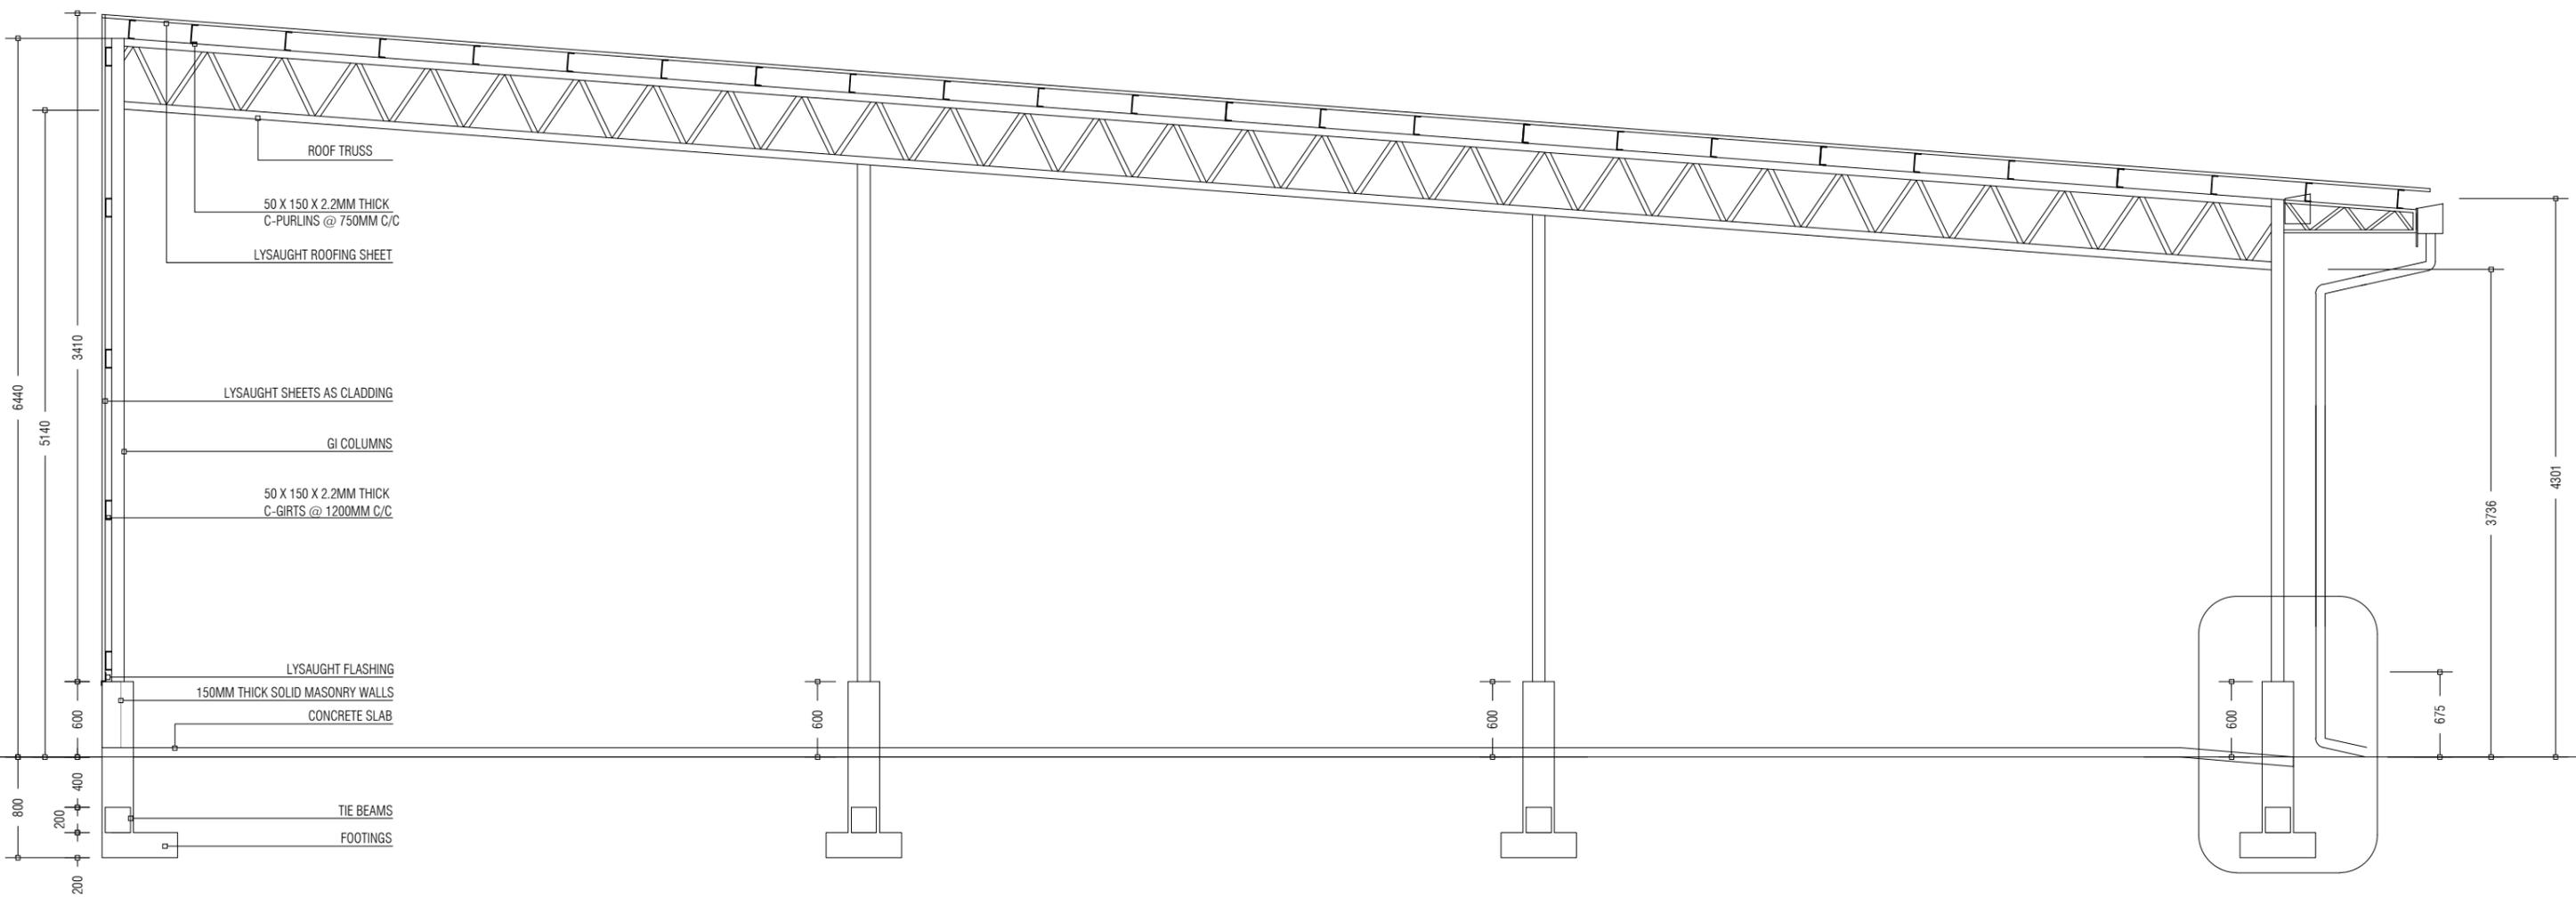


WASTE MANAGEMENT BAY SECTION


PREPARED BY	PROJECT	DESIGN BY	AMENDMENTS
	CONSTRUCTION OF IWRMC M.DHIGGARU	MA	
 MINISTRY OF CLIMATE CHANGE, ENVIRONMENT AND ENERGY GREEN BUILDING, HANDHUVAREE HIGUN, MAAFANNU, MALE' (20392), REPUBLIC OF MALDIVES, TEL: +960-3018431, +960-3018300, FAX: +960-328301	TITLE	STRUCTURE BY	
	ELEVATIONS AND SECTIONS	MA	
CLIENT DEPARTMENT	DRAWN BY		
WMPC DEPARTMENT	MA		
PAPER SIZE A3	SCALE	NTS	
PAGE NO. 10	DWG NO.	DHIG-A2-10	
	DATE	05.02.2024	

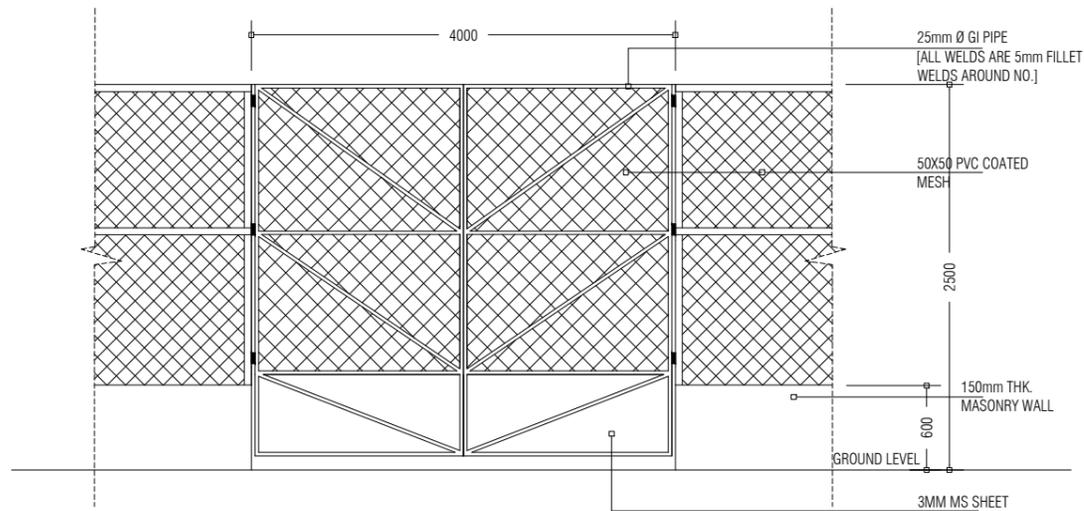

SWING GATE [NTS]

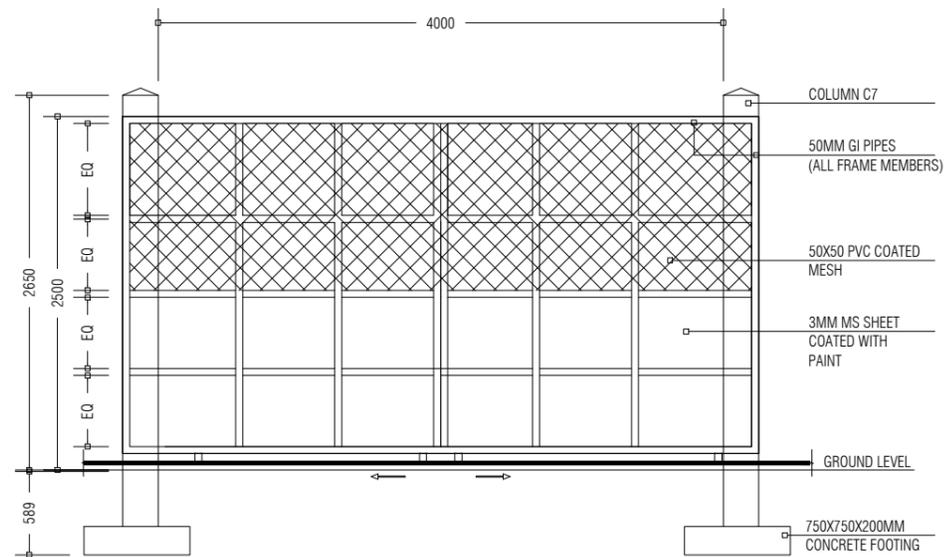


SLIDING GATE

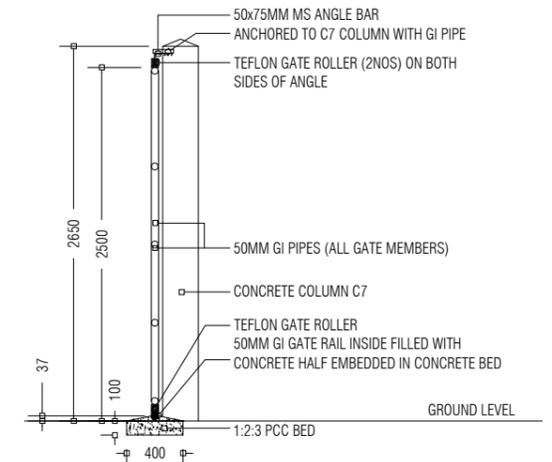


SLIDING GATE SECTIONAL DETAIL

NOTE: REQUIRED RAILING & LOCKING SYSTEM TO BE PROVIDED

NOTE:
ALL WELDS FOR THE
GI MEMBERS ARE
5mm FILLET WELDS

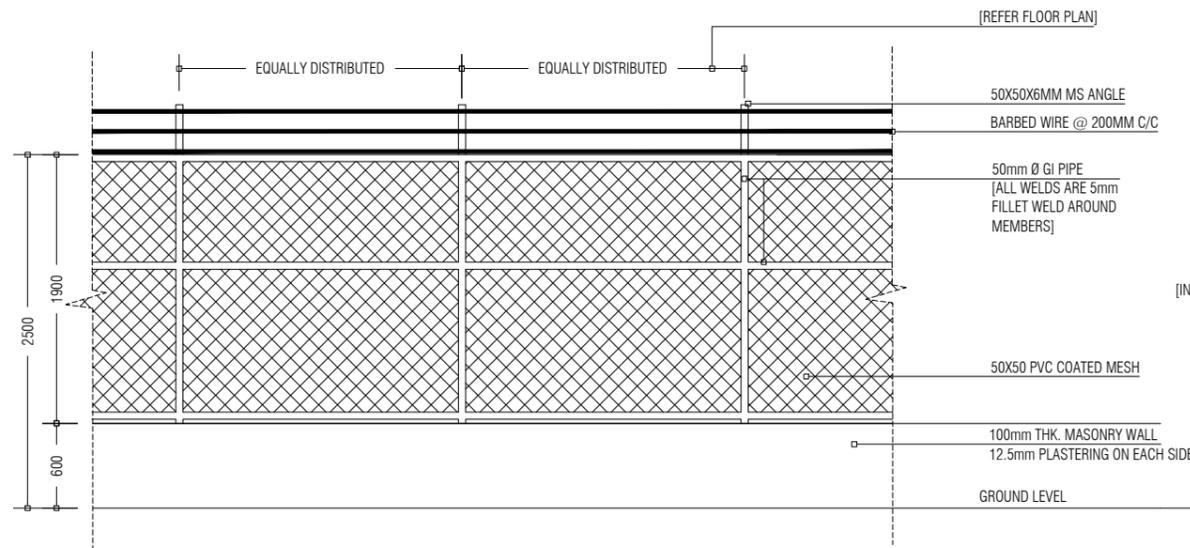

BOUNDARY FENCE ELEVATION

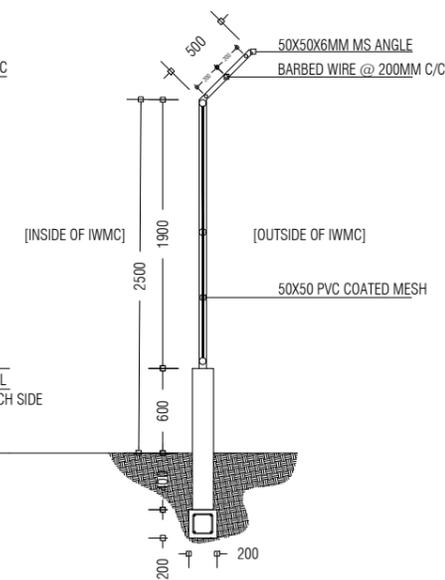

BOUNDARY FENCE SECTION

PREPARED BY

PROJECT

DESIGN BY

AMENDMENTS

CONSTRUCTION OF IWRMC
M.DHIGGARU

MA

SWING GATE ADDED

TITLE

STRUCTURE BY

ELEVATION AND SECTIONS: GATE DETAILS, FENCE DETAILS

MA

CLIENT DEPARTMENT

DRAWN BY

WMPC DEPARTMENT

MA

PAPER SIZE A3

SCALE

1:50

PAGE NO. 11

DWG NO.


DHIG-A2-11

DATE


19.03.2024



MINISTRY OF CLIMATE CHANGE, ENVIRONMENT AND ENERGY
GREEN BUILDING, HANDHUVAREE HIGUN,
MAAFANNU, MALE (20392), REPUBLIC OF MALDIVES,
TEL: +960-3018431, +960-3018300, FAX: +960-328301

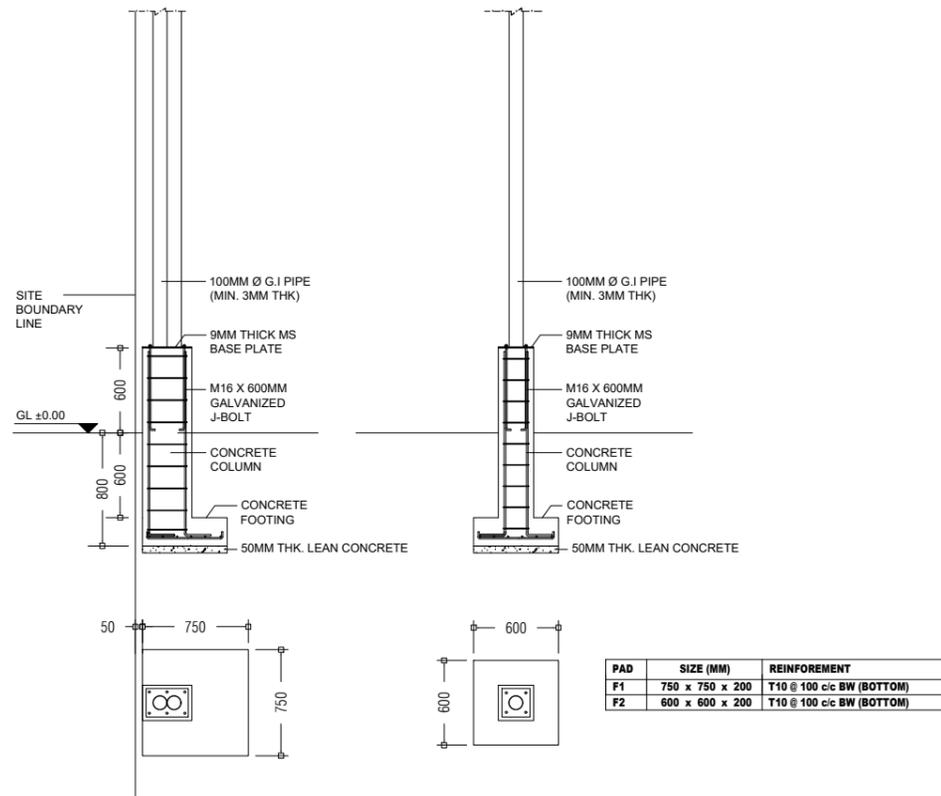


FOOTING DETAILS 1:50

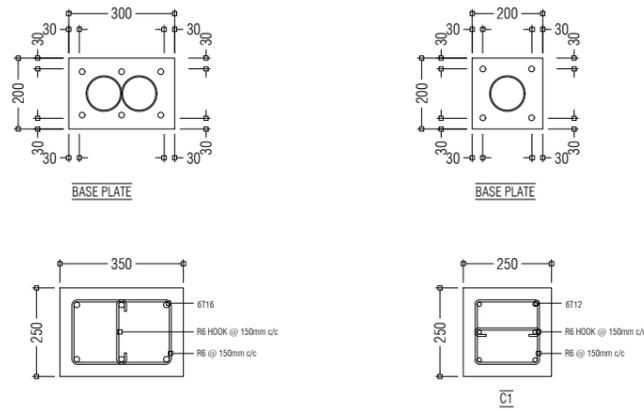


BASE PLATE AND COLUMN DETAILS 1:20


PREPARED BY	PROJECT	DESIGN BY	AMENDMENTS
	CONSTRUCTION OF IWRMC M.DHIGGARU	MA	
MINISTRY OF CLIMATE CHANGE, ENVIRONMENT AND ENERGY GREEN BUILDING, HANDHUVAREE HIGUN, MAAFANNU, MALE' (20392), REPUBLIC OF MALDIVES, TEL: +960-3018431, +960-3018300, FAX: +960-328301	TITLE	STRUCTURE BY	
	FOOTING DETAILS	MA	
	CLIENT DEPARTMENT	DRAWN BY	
	WMPC DEPARTMENT	MA	
PAPER SIZE	A3	SCALE	1:50, 1:20
PAGE NO.	12	DWG NO.	DHIG-D1-12
		DATE	05.02.2024

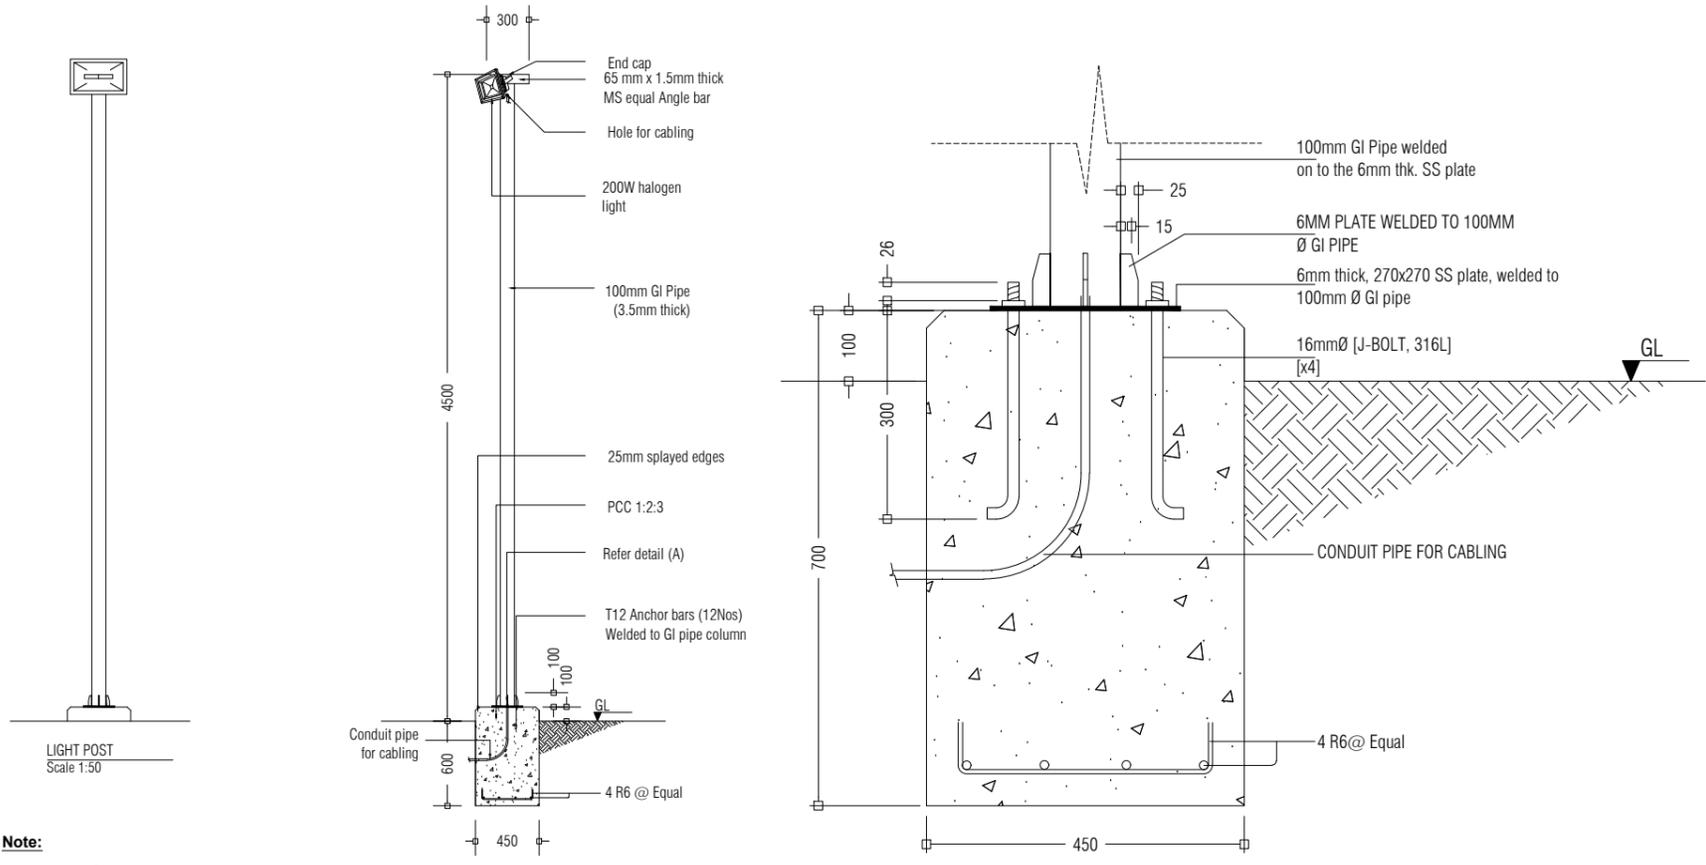


Note:
 * Concrete cover: 50mm
 * GI pipe to be painted with 1 coat of sealer & 2 coats of finishing paint. (Sigma or equivalent, maroon colour)

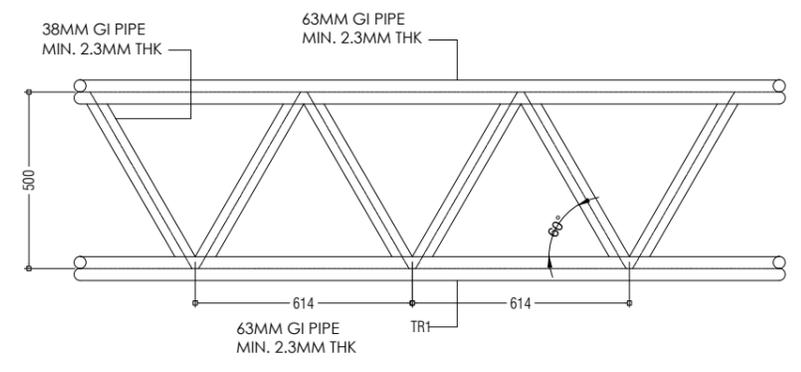


TRUSS DETAIL 1:20

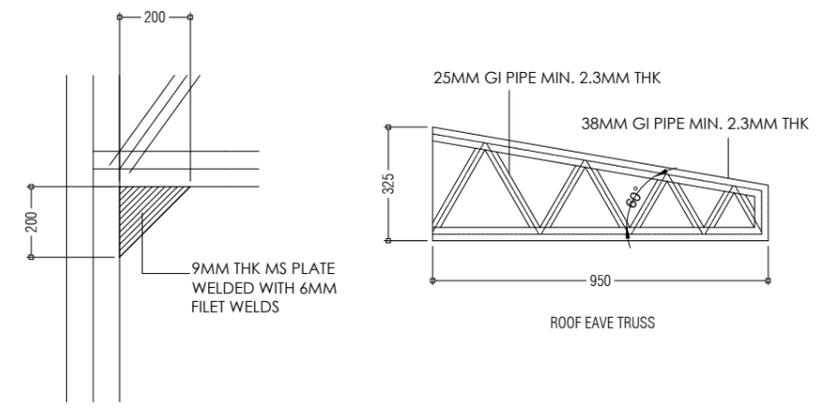


COLUMN AND TRUSS CONNECTION DETAIL 1:20

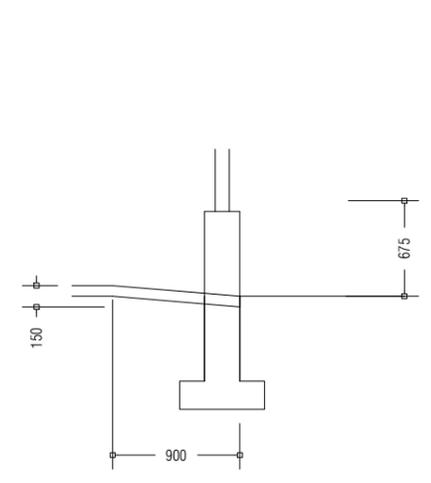



DETAIL A: RAMP DETAIL 1:50

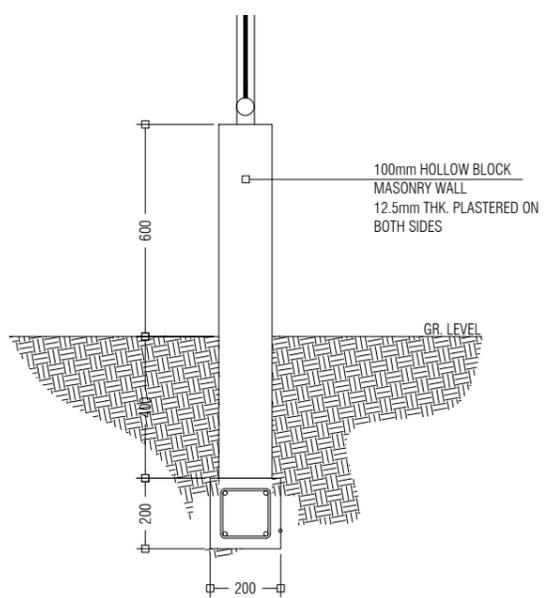

BOUNDARY FENCE SIDE SECTIONAL DETAIL 1:20

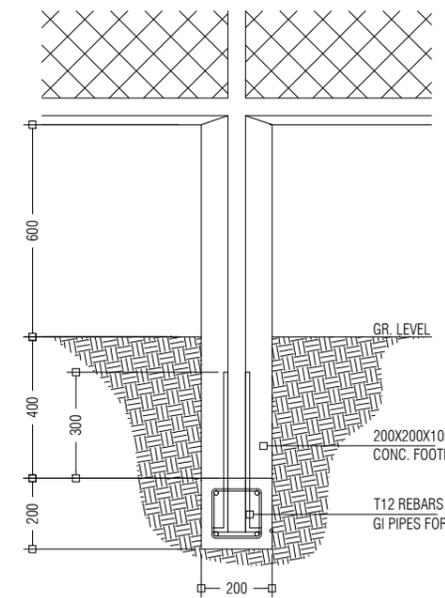

BOUNDARY FENCE FRONT SECTIONAL DETAIL 1:20

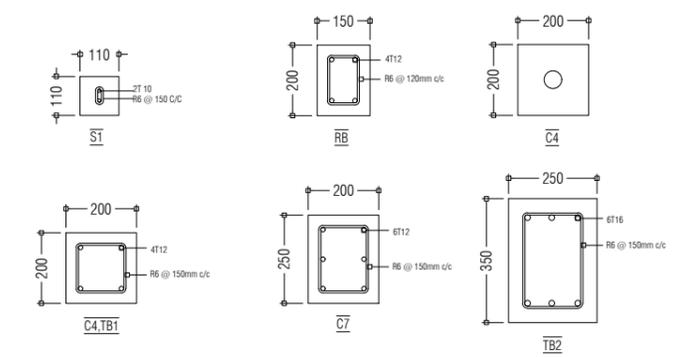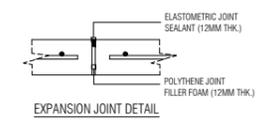


COLUMN, BEAM AND EXPANSION JOINT DETAILS 1:20

CONCRETE COVERS:
 BEAMS AND COLUMNS: 30mm
 75MM SLAB: 30mm
 100MM SLAB: 40mm
 150MM SLAB: 40mm

NOTE:
 1. RB/WB TO BE CAST ON TOP OF MASONRY WALLS
 2. MASONRY WALLS TO BE PLACED ON TB


PREPARED BY	PROJECT	DESIGN BY	AMENDMENTS
	CONSTRUCTION OF IWRMC M.DHIGGARU	MA	
	TITLE	STRUCTURE BY	
	STRUCTURAL DETAILS	MA	
	CLIENT DEPARTMENT	DRAWN BY	
	WMPC DEPARTMENT	MA	
PAPER SIZE	A3	SCALE	1:50, 1:20, 1:10
PAGE NO.	13	DWG NO.	DHIG-D1-13
		DATE	05.02.2024



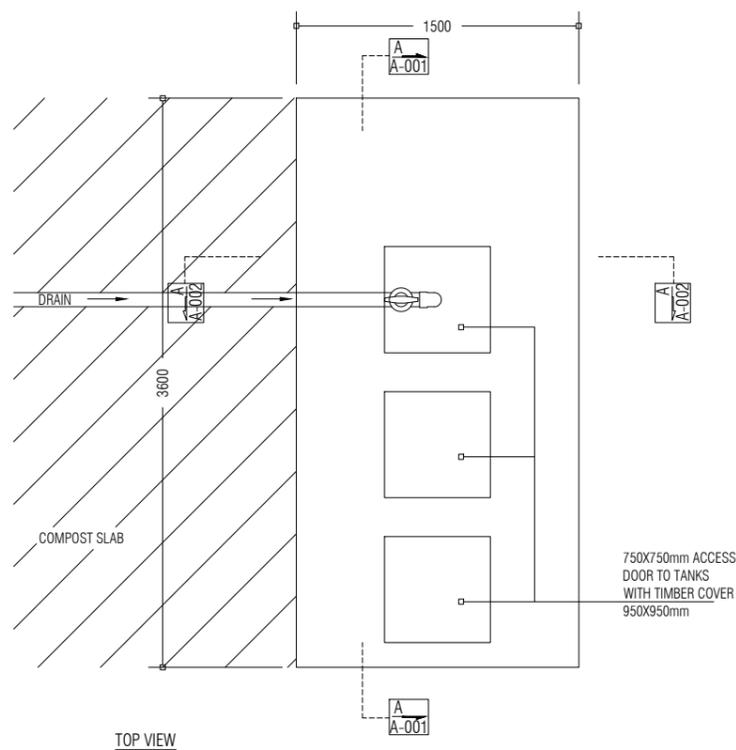


TOP VIEW


LEACHATE WELL (NTS)

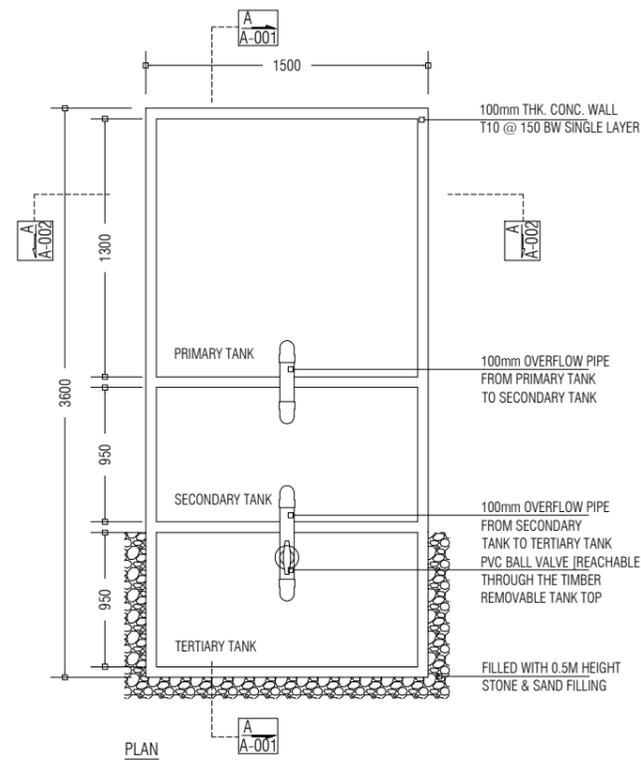


PLAN

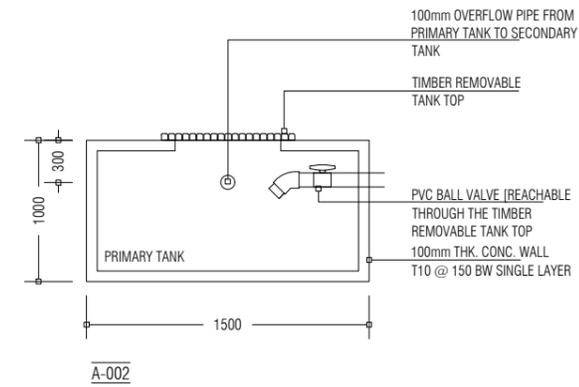


A-002

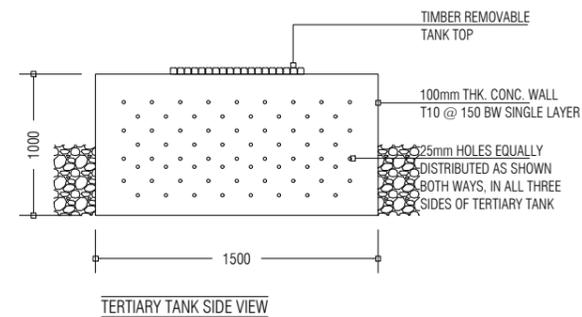


TERTIARY TANK SIDE VIEW

 


DRAIN PIT GRATE

 


DRAIN PIT: TOP VIEW

 


DRAIN PIT: SECTION VIEW

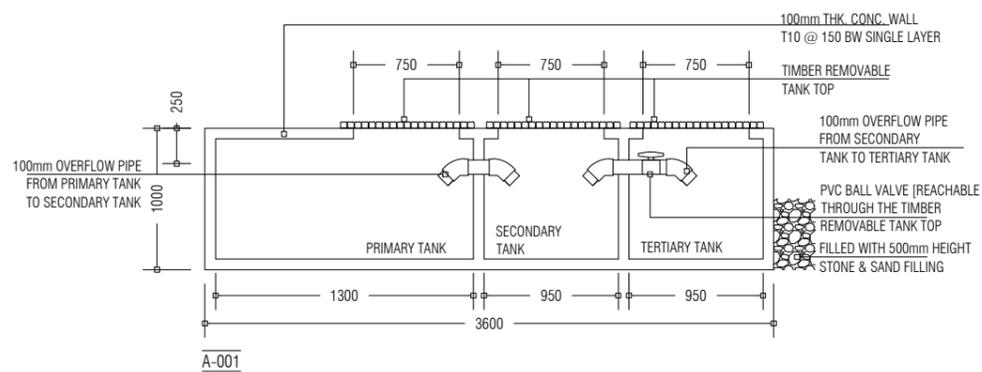


LEACHATE WELL (NTS)

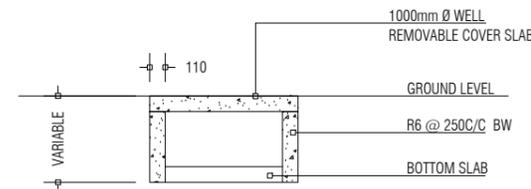


GROUND WATER WELL [1:50]

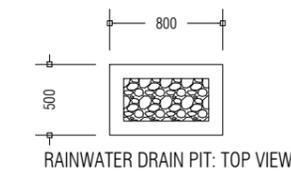

RAINWATER DRAIN PIT: TOP VIEW

 


RAINWATER DRAIN PIT: SIDE VIEW

 

RAINWATER DRAIN PIT: SECTION VIEW

PREPARED BY	PROJECT	DESIGN BY	AMENDMENTS
 <p>MINISTRY OF CLIMATE CHANGE, ENVIRONMENT AND ENERGY GREEN BUILDING, HANDHUVAREE HIGUN, MAAFANNU, MALÉ (20392), REPUBLIC OF MALDIVES, TEL: +960-3018431, +960-3018300, FAX: +960-328301</p>	M.DHIGGARU	MA	
	TITLE	STRUCTURE BY	
	LEACHATE WELL, GROUND WATER WELL, RAINWATER DRAIN PIT AND WASTE MANAGEMENT BUILDING DRAIN PIT DETAILS	MA	
	CLIENT DEPARTMENT	DRAWN BY	
	WMPC DEPARTMENT	MA	
PAPER SIZE A3	SCALE	NTS, 1:50	
PAGE NO. 14	DWG NO.	DHIG-D1-14	
	DATE	05.02.2024	

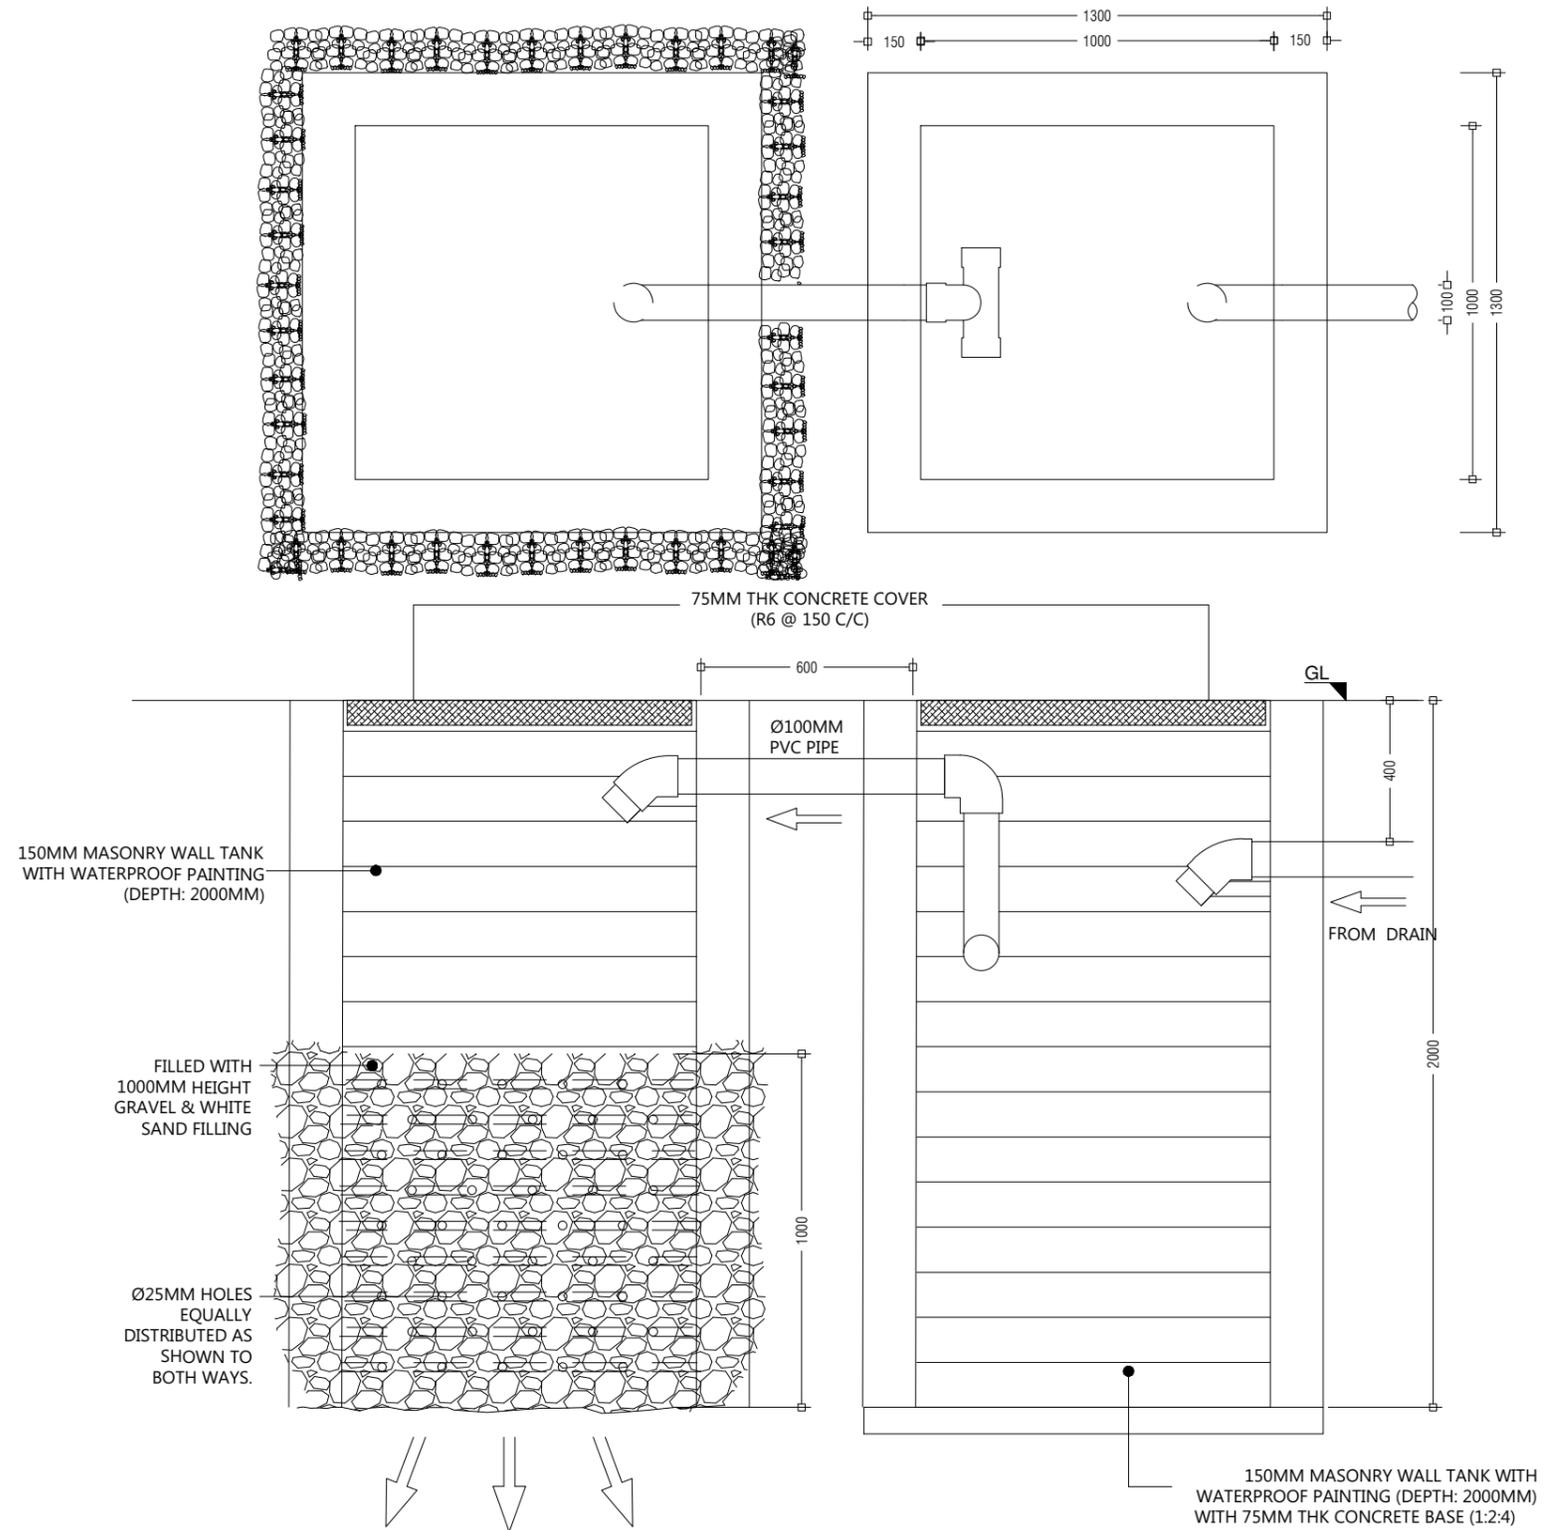

PREPARED BY

PROJECT

DESIGN BY

AMENDMENTS

CONSTRUCTION OF IWRMC
M.DHIGGARU

MA

TITLE

STRUCTURE BY

SEPTIC TANK DETAILS

MA

CLIENT DEPARTMENT

DRAWN BY

WMPC DEPARTMENT

MA

PAPER SIZE A3

SCALE

1:50

PAGE NO. 15

DWG NO.


DHIG-D1-15

DATE

05.02.2024



MINISTRY OF CLIMATE CHANGE, ENVIRONMENT AND ENERGY
GREEN BUILDING, HANDHUVAREE HIGUN,
MAAFANNU, MALÉ (20392), REPUBLIC OF MALDIVES,
TEL: +960-3018431, +960-3018300, FAX: +960-328301

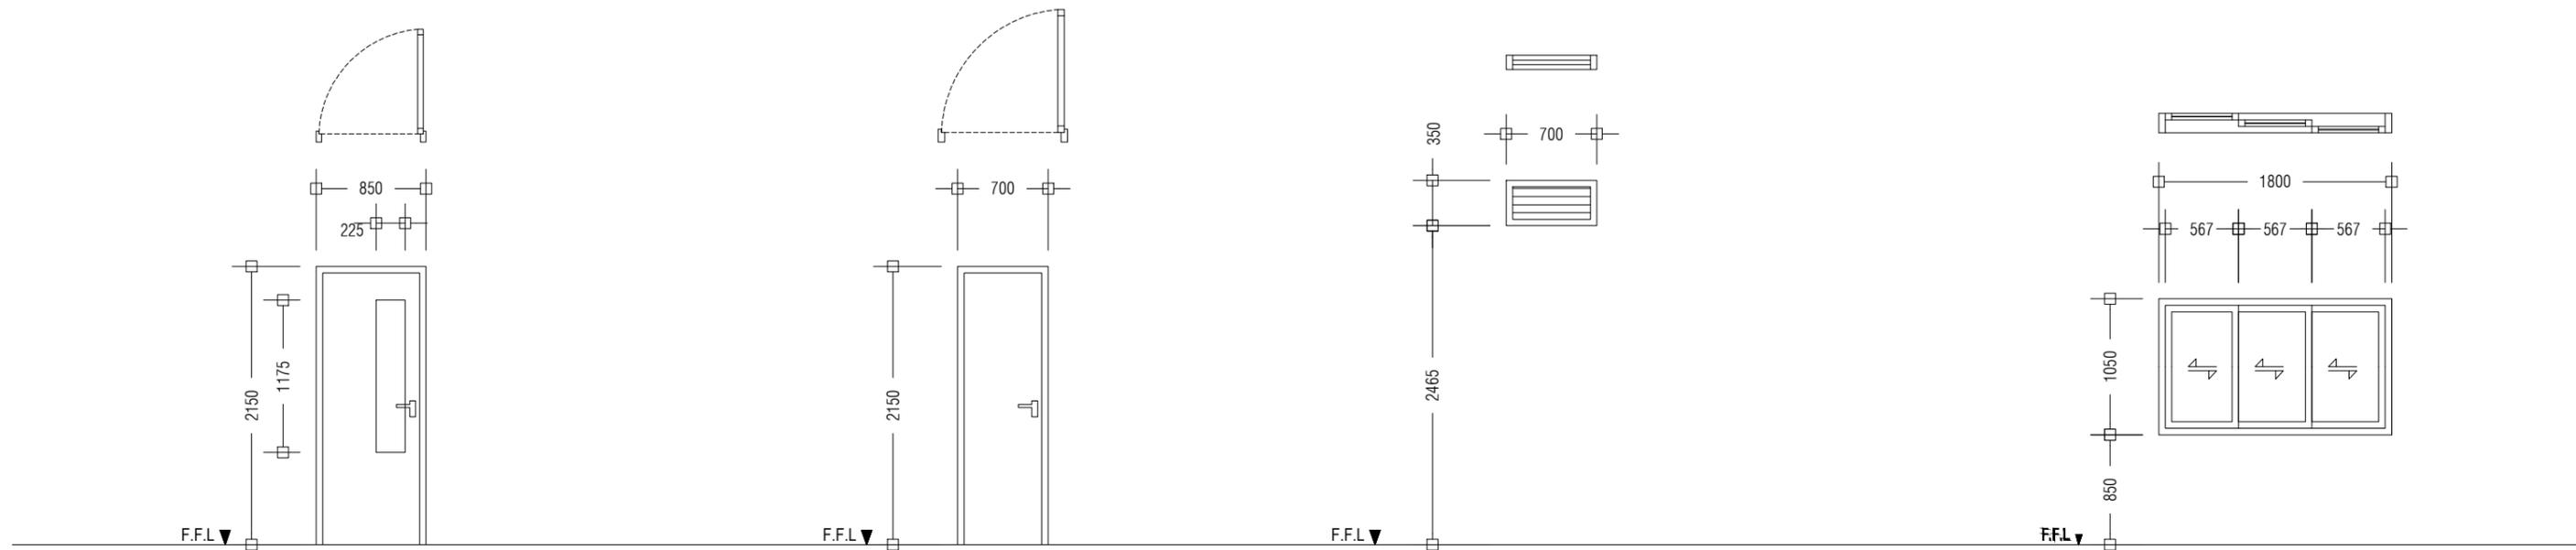


D2	SWING TYPE DOOR
REMARKS	ALUMINIUM DOOR WITH CLEAR GLASS PANEL 01 DOOR KNOB WITH LOCK SET 04 HINGES DOOR STOPPER, FINISHED WITH WHITE COATED PAINT
LOCATION	GROUND FLOOR
QUANTITY	NO.S 04
OPEN AREA	1.83 m ²


D3	SWING TYPE DOOR
REMARKS	ALUMINIUM DOOR WITH DOOR KNOB AND 1 LOCK SET 04 HINGES
LOCATION	GROUND FLOOR
QUANTITY	NO.S 01
OPEN AREA	1.51m ²

W1	ALUNINIUM LOUVER WINDOW
REMARKS	ALUMINIUM FRAMED, ALUMINIUM LOUVERED, FINISHED WITH WHITE COATED PAINT
LOCATION	GROUND FLOOR
QUANTITY	NO.S 2
OPEN AREA	0.25 m ²

W2	ALUMINIUM SLIDING WINDOW
REMARKS	ALUMINIUM FRAMED, TINTED BLACK GLASS, FINISHED WITH WHITE POWDER COATED PAINT
LOCATION	GROUND FLOOR
QUANTITY	NO.S 02
OPEN AREA	1.89 m ²

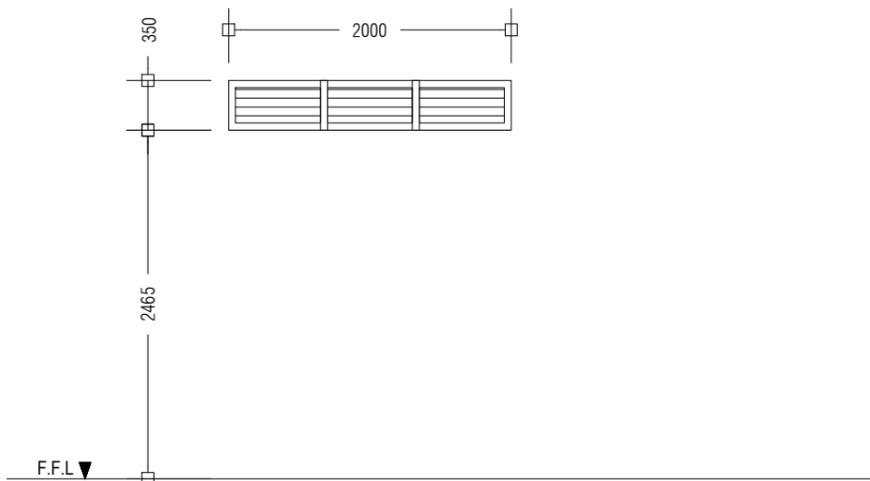

W3	ALUNINIUM LOUVER WINDOW
REMARKS	ALUMINIUM FRAMED, ALUMINIUM LOUVERED, FINISHED WITH WHITE COATED PAINT
LOCATION	GROUND FLOOR
QUANTITY	NO.S 1
OPEN AREA	0.75 m ²

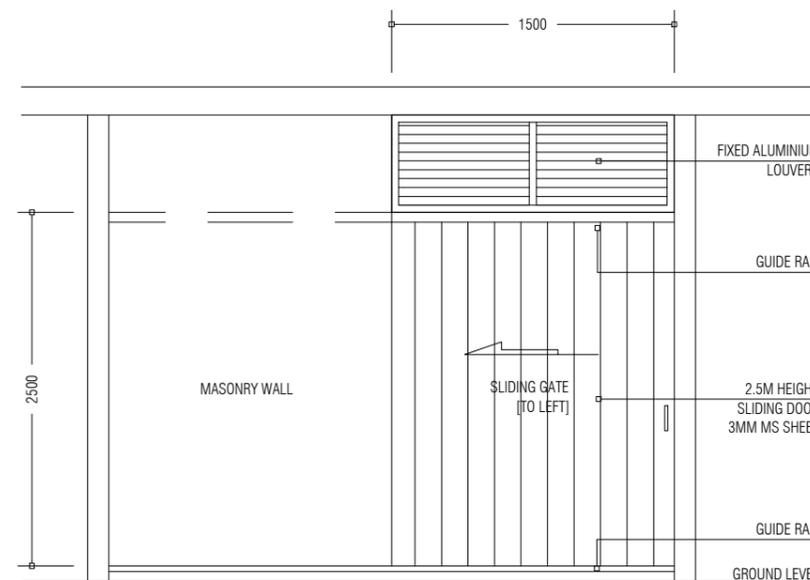

HAZADIOUS WASTE / STORE SD1

PREPARED BY

PROJECT

DESIGN BY

AMENDMENTS

CONSTRUCTION OF IWRMC
M.DHIGGARU

MA

TITLE
DOOR AND WINDOW SCHEDULE

STRUCTURE BY
MA

CLIENT DEPARTMENT
WMPC DEPARTMENT

DRAWN BY
MA

PAPER SIZE A3


SCALE 1:50

PAGE NO. 16

DWG NO. DHIG-A2-16

DATE 05.02.2024



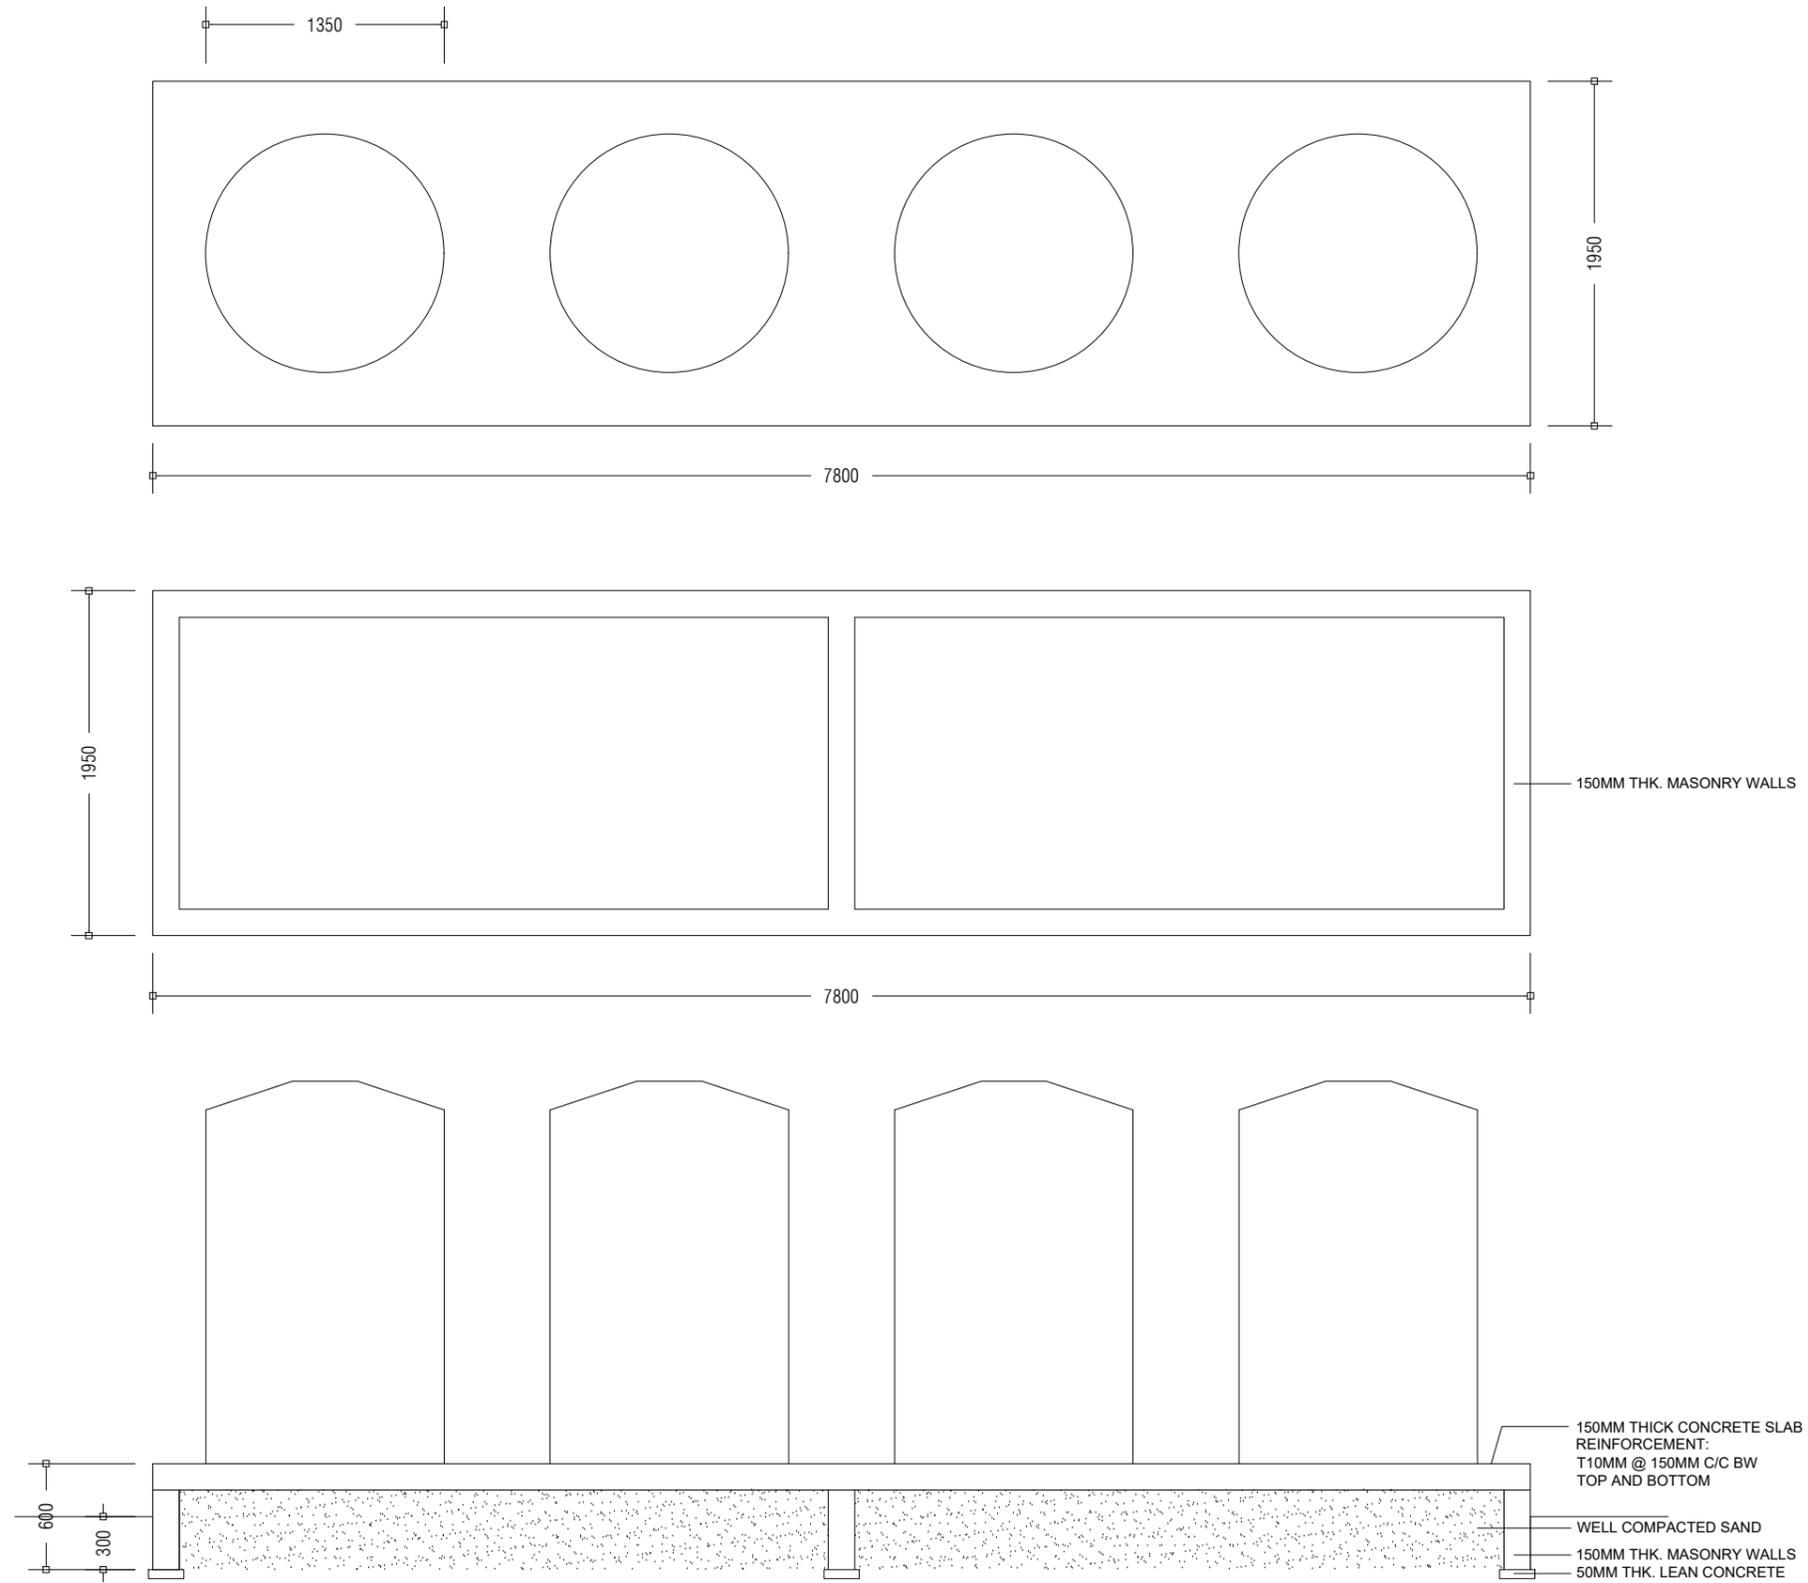

PREPARED BY	PROJECT	DESIGN BY	AMENDMENTS
	CONSTRUCTION OF IWRMC M.DHIGGARU	MA	
 MINISTRY OF CLIMATE CHANGE, ENVIRONMENT AND ENERGY GREEN BUILDING, HANDHUVAREE HIGUN, MAAFANNU, MALE' (20392), REPUBLIC OF MALDIVES, TEL: +960-3018431, +960-3018300, FAX: +960-328301	TITLE	STRUCTURE BY	
	WATER STORAGE TANKS FOUNDATION DETAILS	MA	
CLIENT DEPARTMENT	DRAWN BY		
WMPC DEPARTMENT	MA		
PAPER SIZE A3	SCALE	1:40	
PAGE NO. 17	DWG NO.	DHIG-A2-17	
	DATE	06.03.2024	