

10.08.2024
ISSUED FOR REVIEW (NOT FOR CONSTRUCTION)



DESIGNER
MAKESHOP PVT LTD

CLIENT
URA

URA OFFICE LOBBY DETAIL INTERIOR DESIGN

DRAWING LIST

URA OFFICE LOBBY

DRAWING NO.	DESCRIPTION	SIZE	REMARKS
A3-00	DRAWING LIST	A3	REV-0
A3-01	FLOOR LAYOUT	A3	REV-0
A3-02	FLOOR FINISHES	A3	REV-0
A3-03	WALL FINISHES	A3	REV-0
A3-04	REFLECTED CEILING LAYOUT	A3	REV-0
A3-05	LIGHTING LAYOUT	A3	REV-0
A3-06	POWER AND NETWORK LAYOUT	A3	REV-0
A3-07	COUNTER DETAILS	A3	REV-0
A3-08	COUNTER DETAILS	A3	REV-0
A3-09	COUNTER BACK DETAILS	A3	REV-0
A3-10	POWER LAYOUT	A3	REV-0



Project Name:

**URA
LOBBY INTERIOR**

Client:

URA

Project No. 2024.015



Revisions

Notes

1. Do not Scale Drawing
2. Contractor to check site measurement prior to fabrication
3. All dimensions are in mm.

Project North




Scale 1:20

DRAWING LIST

A3.00

Sheet No. © 2023

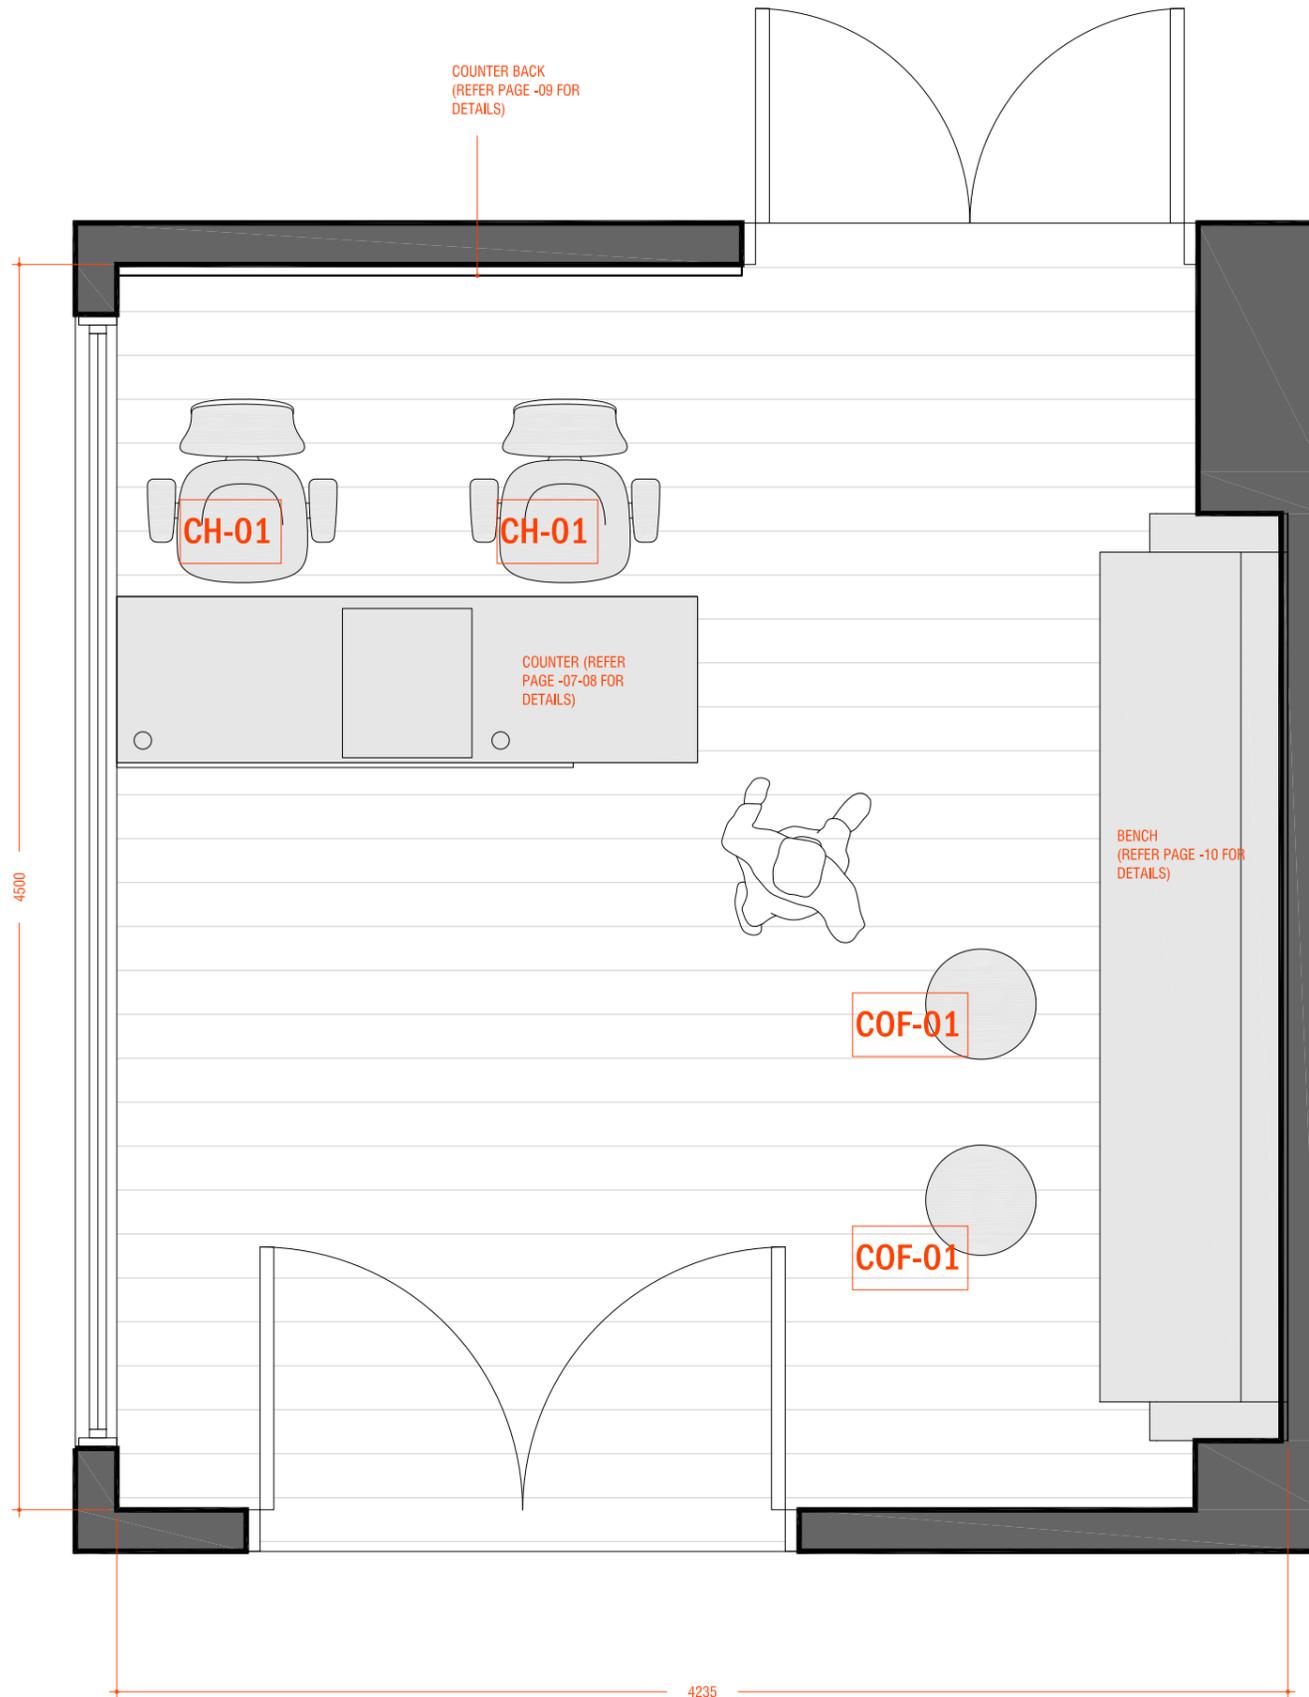

FURNITURE SPEC.

	CODE	DESCRIPTION	DIMENSION
	CH-01	STAFF CHAIR	AS PER SUPPLIER
	COF-01	COFFEE TABLE	Dia 470mm , H - 570mm

Project Name:
URA
LOBBY INTERIOR

Client:
URA

Project No. 2024.015



Revisions

- Notes
1. Do not Scale Drawing
 2. Contractor to check site measurement prior to fabrication
 3. All dimensions are in mm.

Project North



Scale 1:20


FLOOR LAYOUT

A3.01

Sheet No. © 2023

FLOOR FINISHES

	CODE	DESCRIPTION
	FL-01	LAMINATE FLOORING

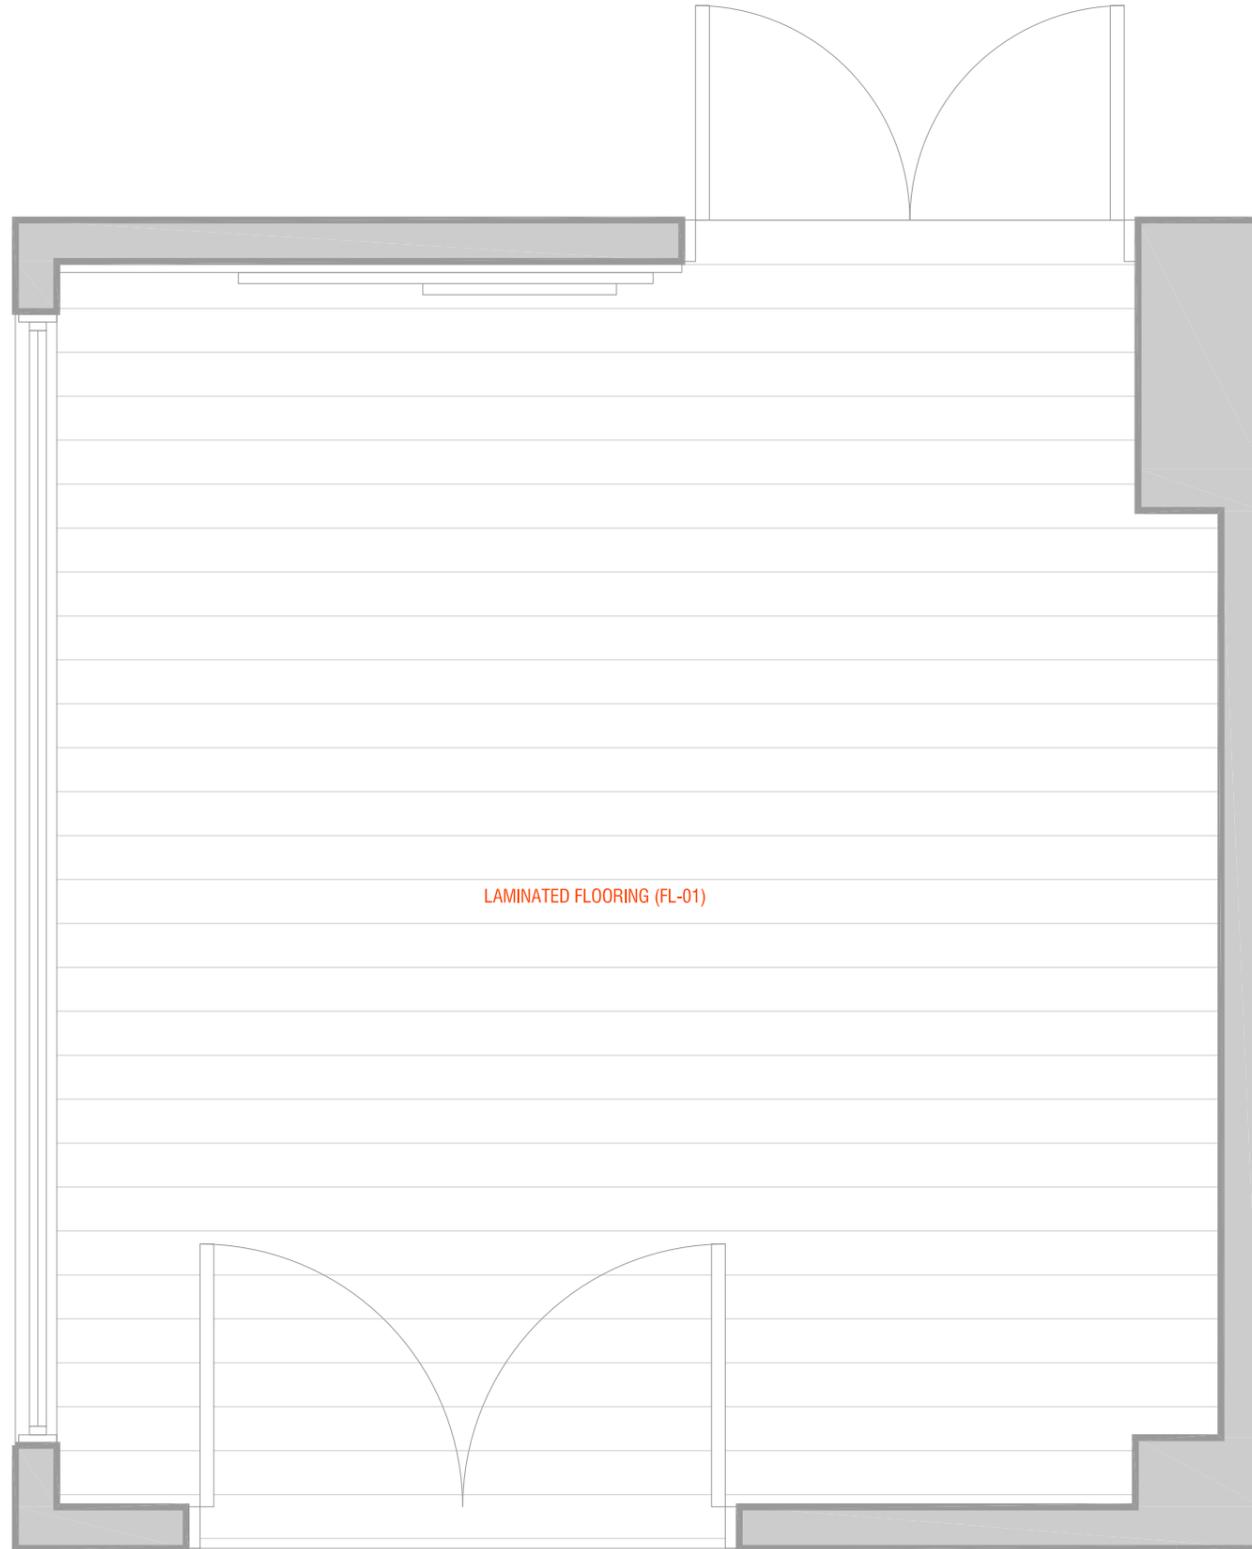

Project Name:
URA
LOBBY INTERIOR

Client:
URA

Project No. 2024.015



Revisions

- Notes
1. Do not Scale Drawing
 2. Contractor to check site measurement prior to fabrication
 3. All dimensions are in mm.

Project North



Scale 1:20


FLOOR FINISHES


A3.02

Sheet No. © 2023

NOTE:
UNLESS OTHERWISE STATED
ALL WALLS TO BE MATTE
WHITE PAINTED WITH PA-01

WALL FINISHES

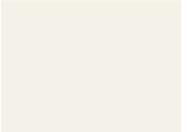	CODE	DESCRIPTION
	A	RIBBED FLUTED PANEL WITH PAINT FINISH 'A' WITH PAINT (PA-02 FINISH)
	PA-01	PAINT FINISH
	PA-02	PAINT FINISH

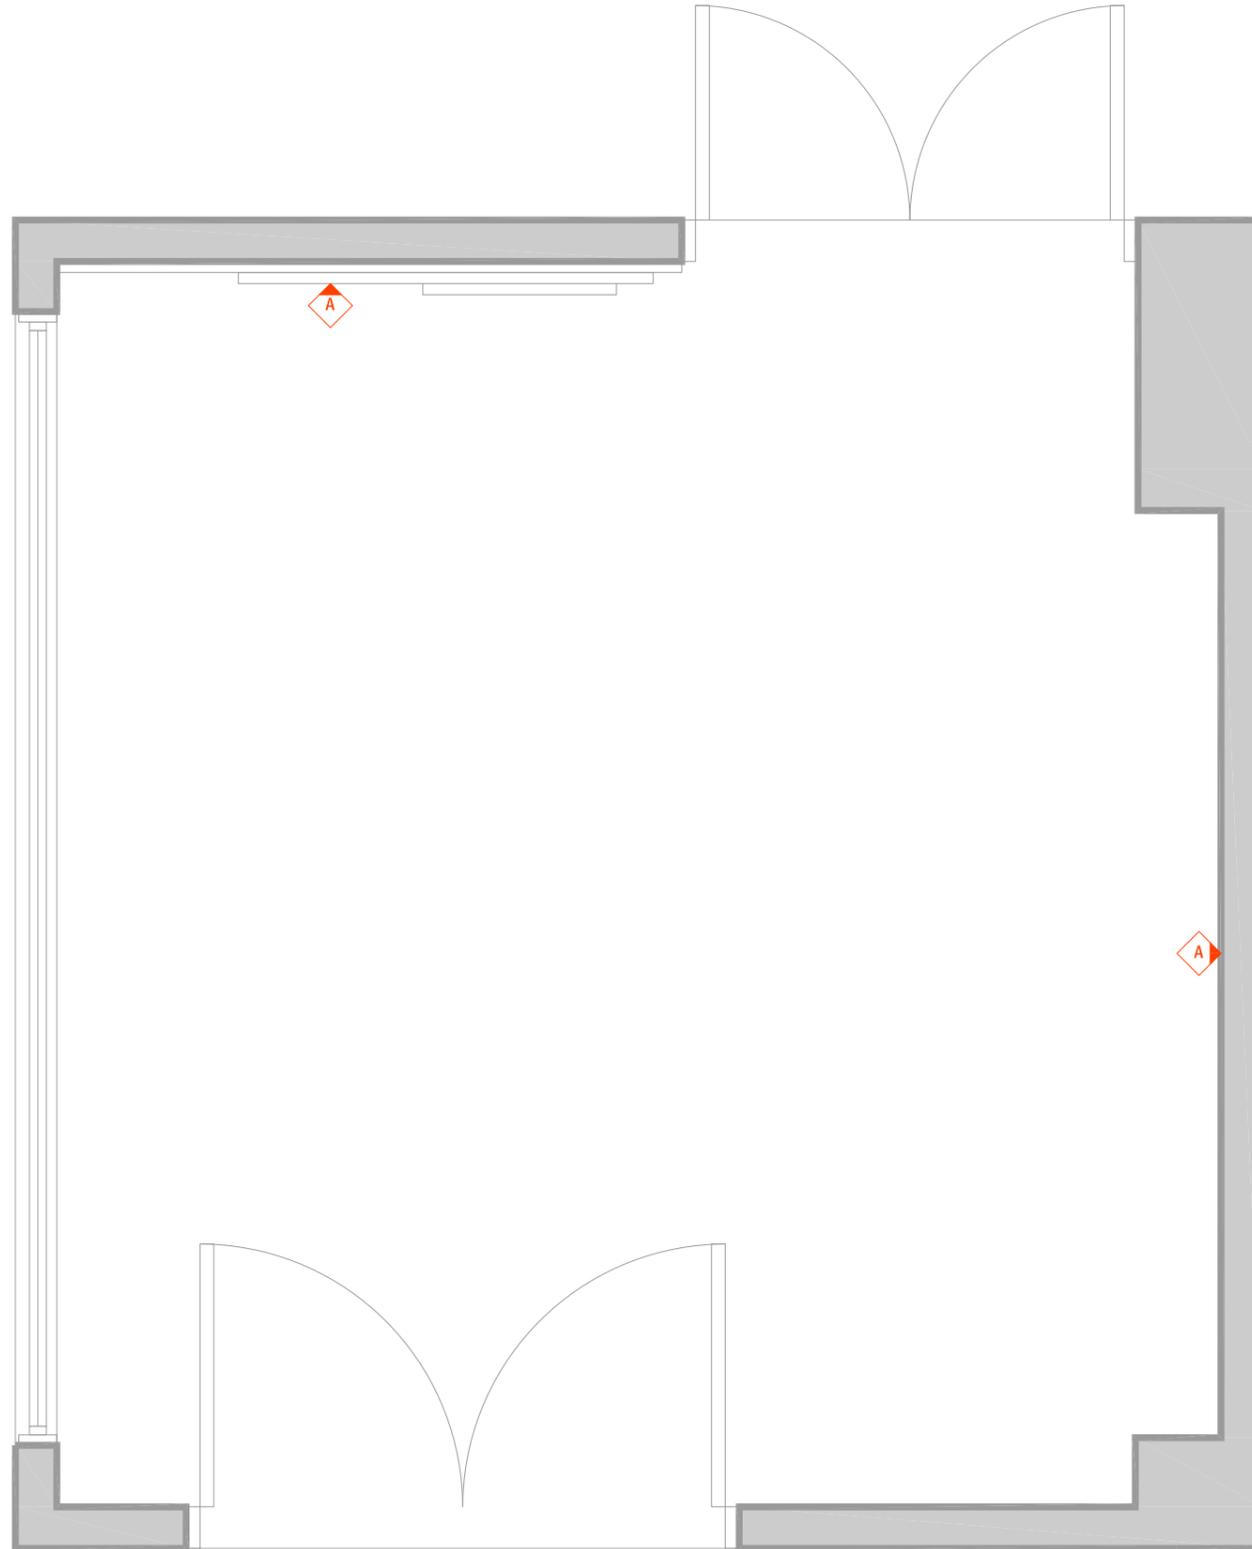

Project Name:
**URA
LOBBY INTERIOR**

Client:
URA

Project No. 2024.015



Revisions

Notes
1. Do not Scale Drawing
2. Contractor to check site measurement prior to fabrication
3. All dimensions are in mm.

Project North




Scale 1:20

WALL FINISHES

A3.03

Sheet No. © 2023

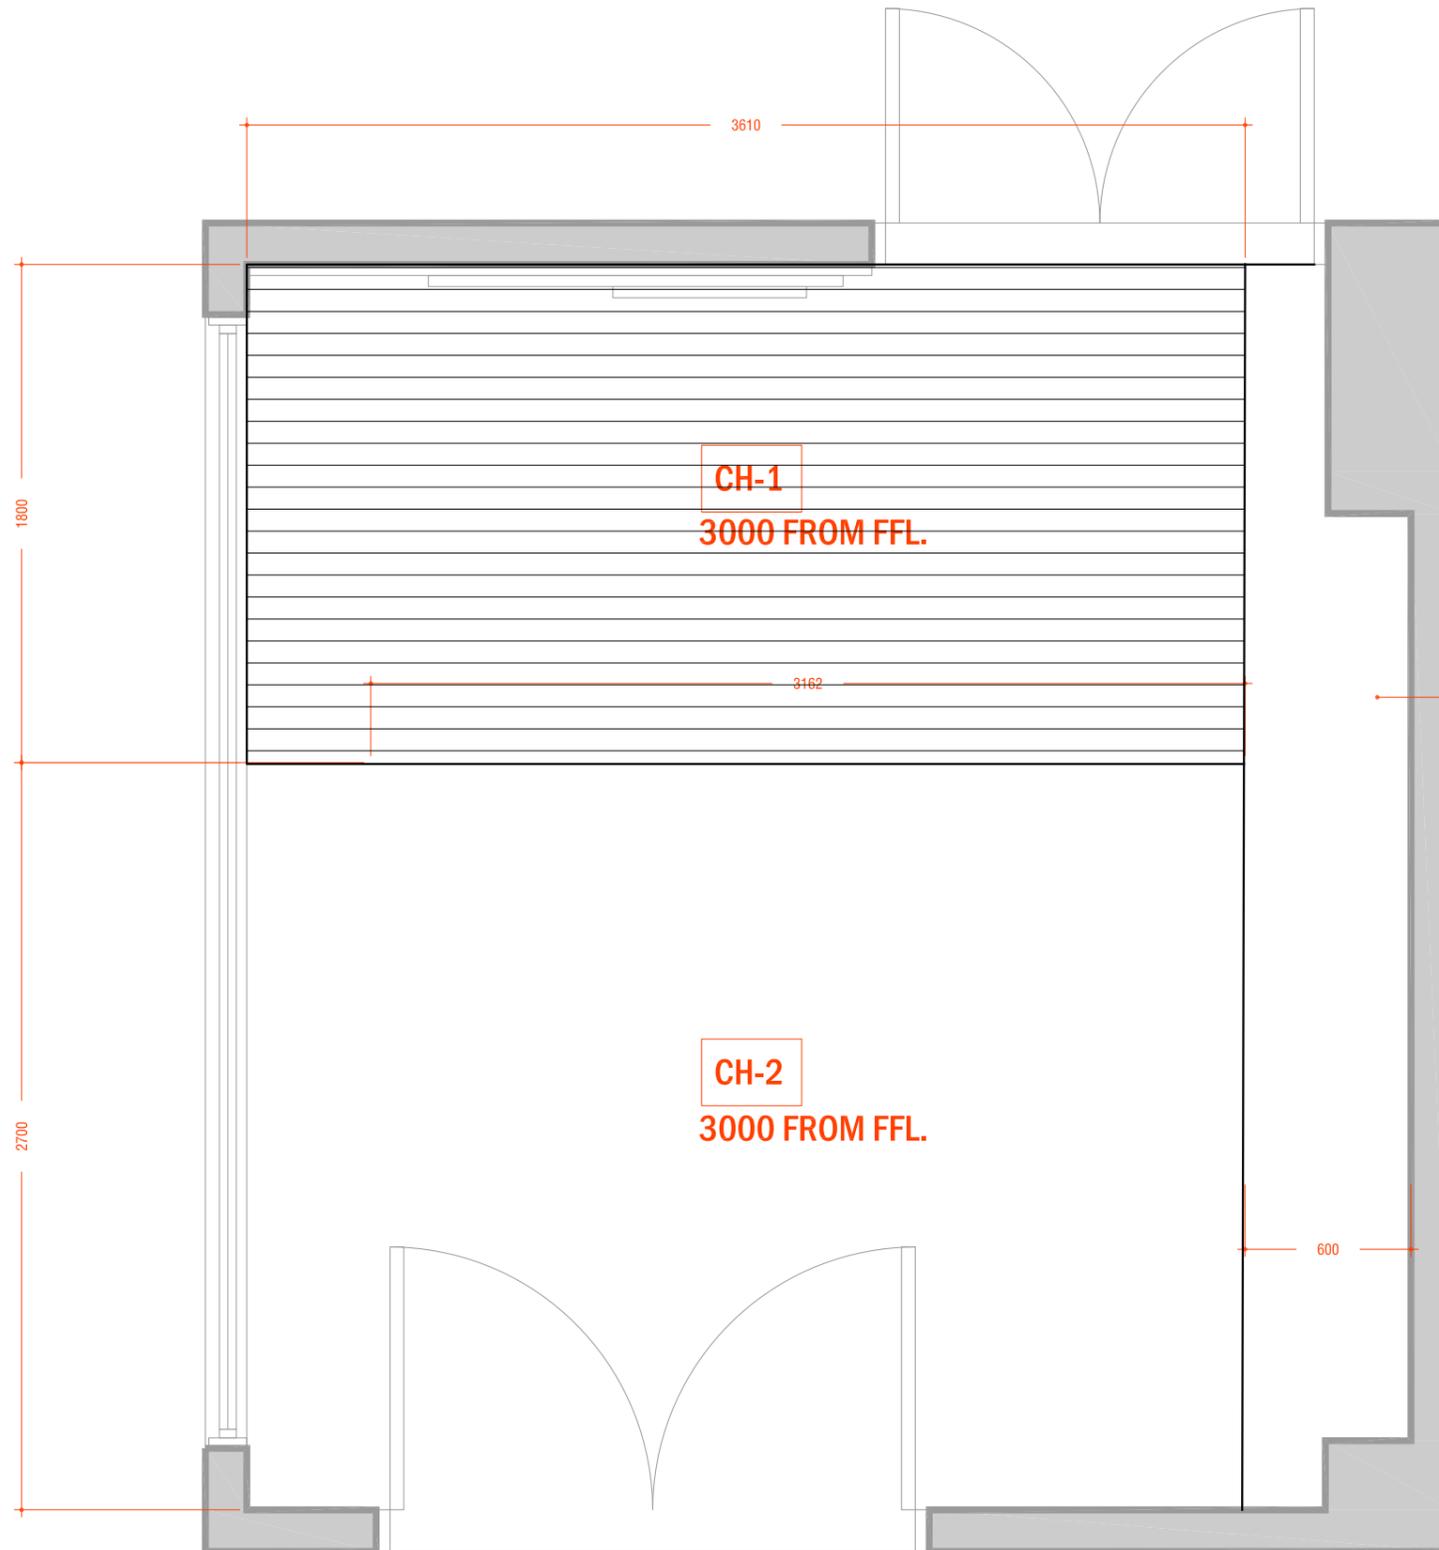

NOTE:
 -CH-1 TO BE FINISHED WITH
 FLUTED PANEL WITH PA-02
 FINISH
 - ALL OTHER CEILING TO BE
 WHITE PAINTED

CH-3
 2600 FROM FFL.

CH-1
 3000 FROM FFL.

CH-2
 3000 FROM FFL.

NOTE
 CH - CEILING HEIGHT

Project Name:
URA
LOBBY INTERIOR

Client:
URA

Project No. 2024.015



Revisions

No.	Description

Notes
 1. Do not Scale Drawing
 2. Contractor to check site measurement prior to fabrication
 3. All dimensions are in mm.

Project North




Scale 1:20


**REFLECTED CEILING
 LAYOUT**

A3.04

Sheet No. © 2023

 WALL FINISHES

	CODE	DESCRIPTION
	L1	LED SPOT LIGHT -15 WATT -COLOR TEMPERATURE 4500K
	L2	PENDANT LIGHT -25 WATT -COLOR TEMPERATURE 4500K

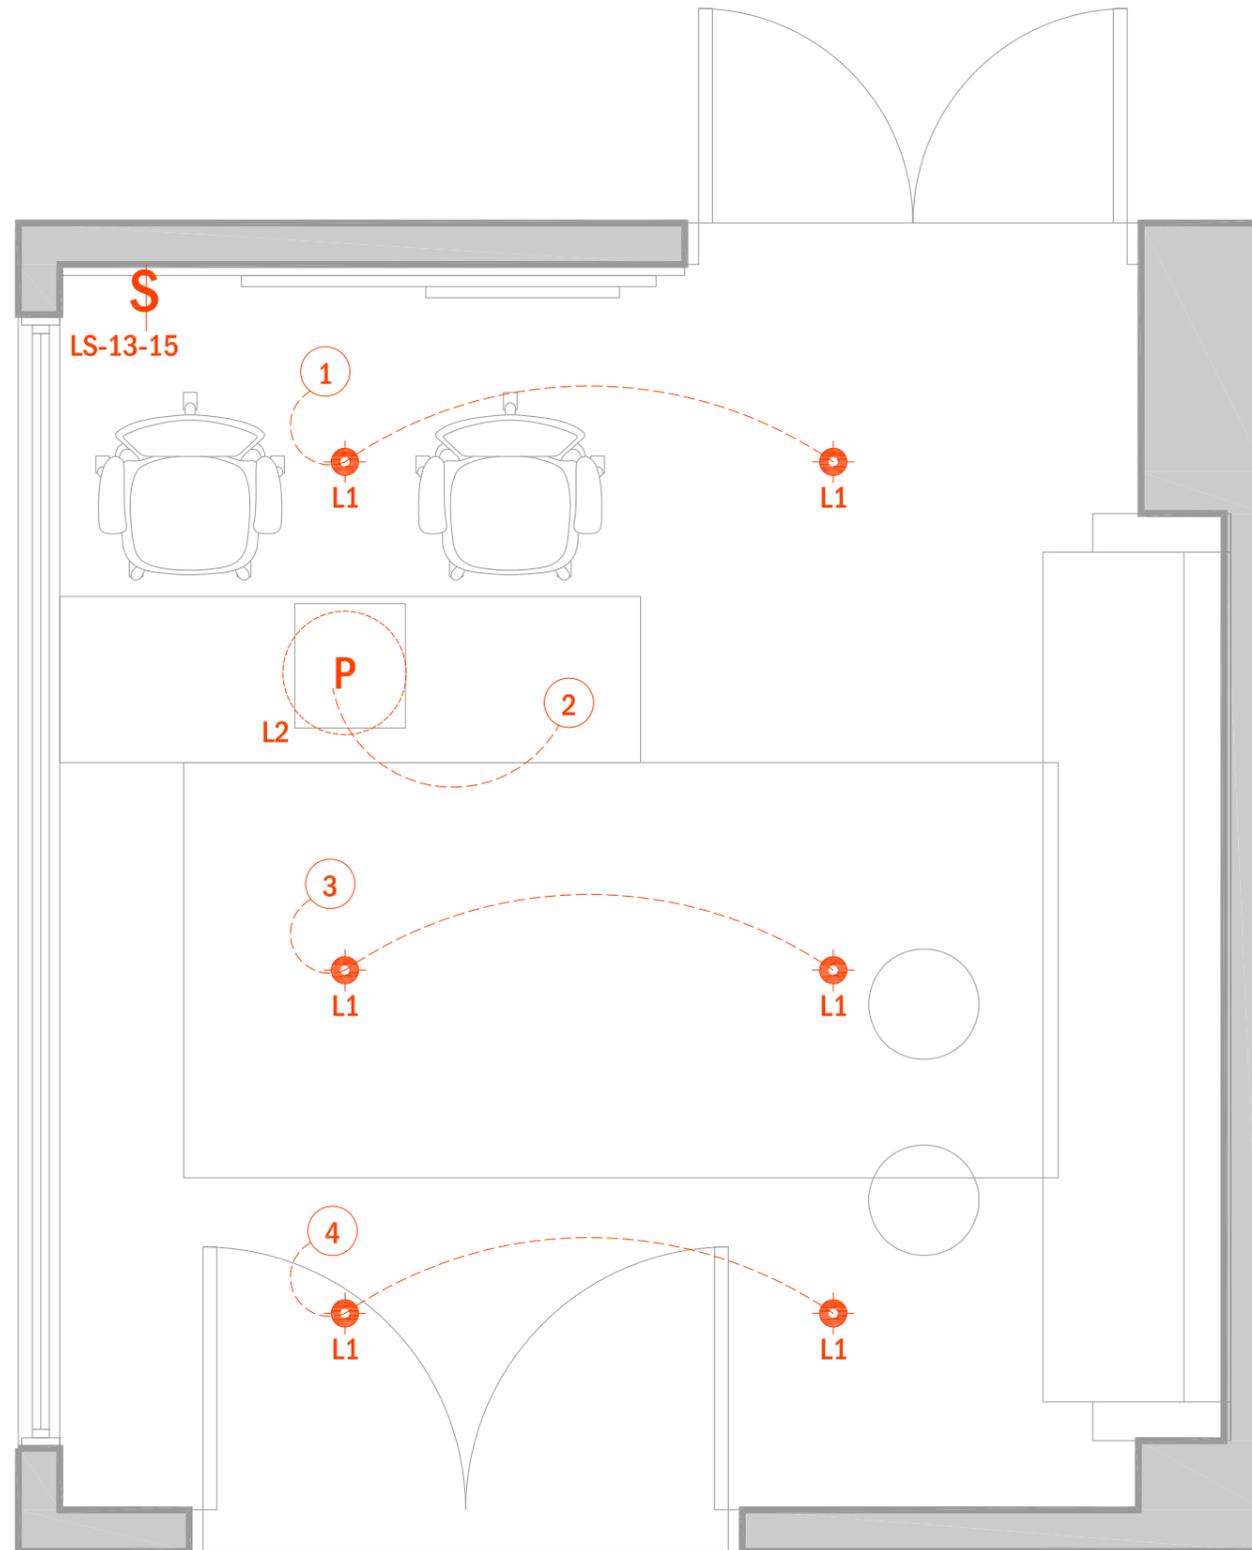

SYMBOLS

-  SPOTLIGHT
-  WALL MOUNTED LIGHT (H-1.8M)
-  LED STRIP LIGHT
-  LED LIGHT TRACK
- S** SWITCH
- S_D** SWITCH (DIMMING CIRCUIT)



Revisions

No.	Description

Notes
 1. Do not Scale Drawing
 2. Contractor to check site measurement prior to fabrication
 3. All dimensions are in mm.

Project North




Scale 1:20

LIGHTING LAYOUT

A3.05

Sheet No. © 2023

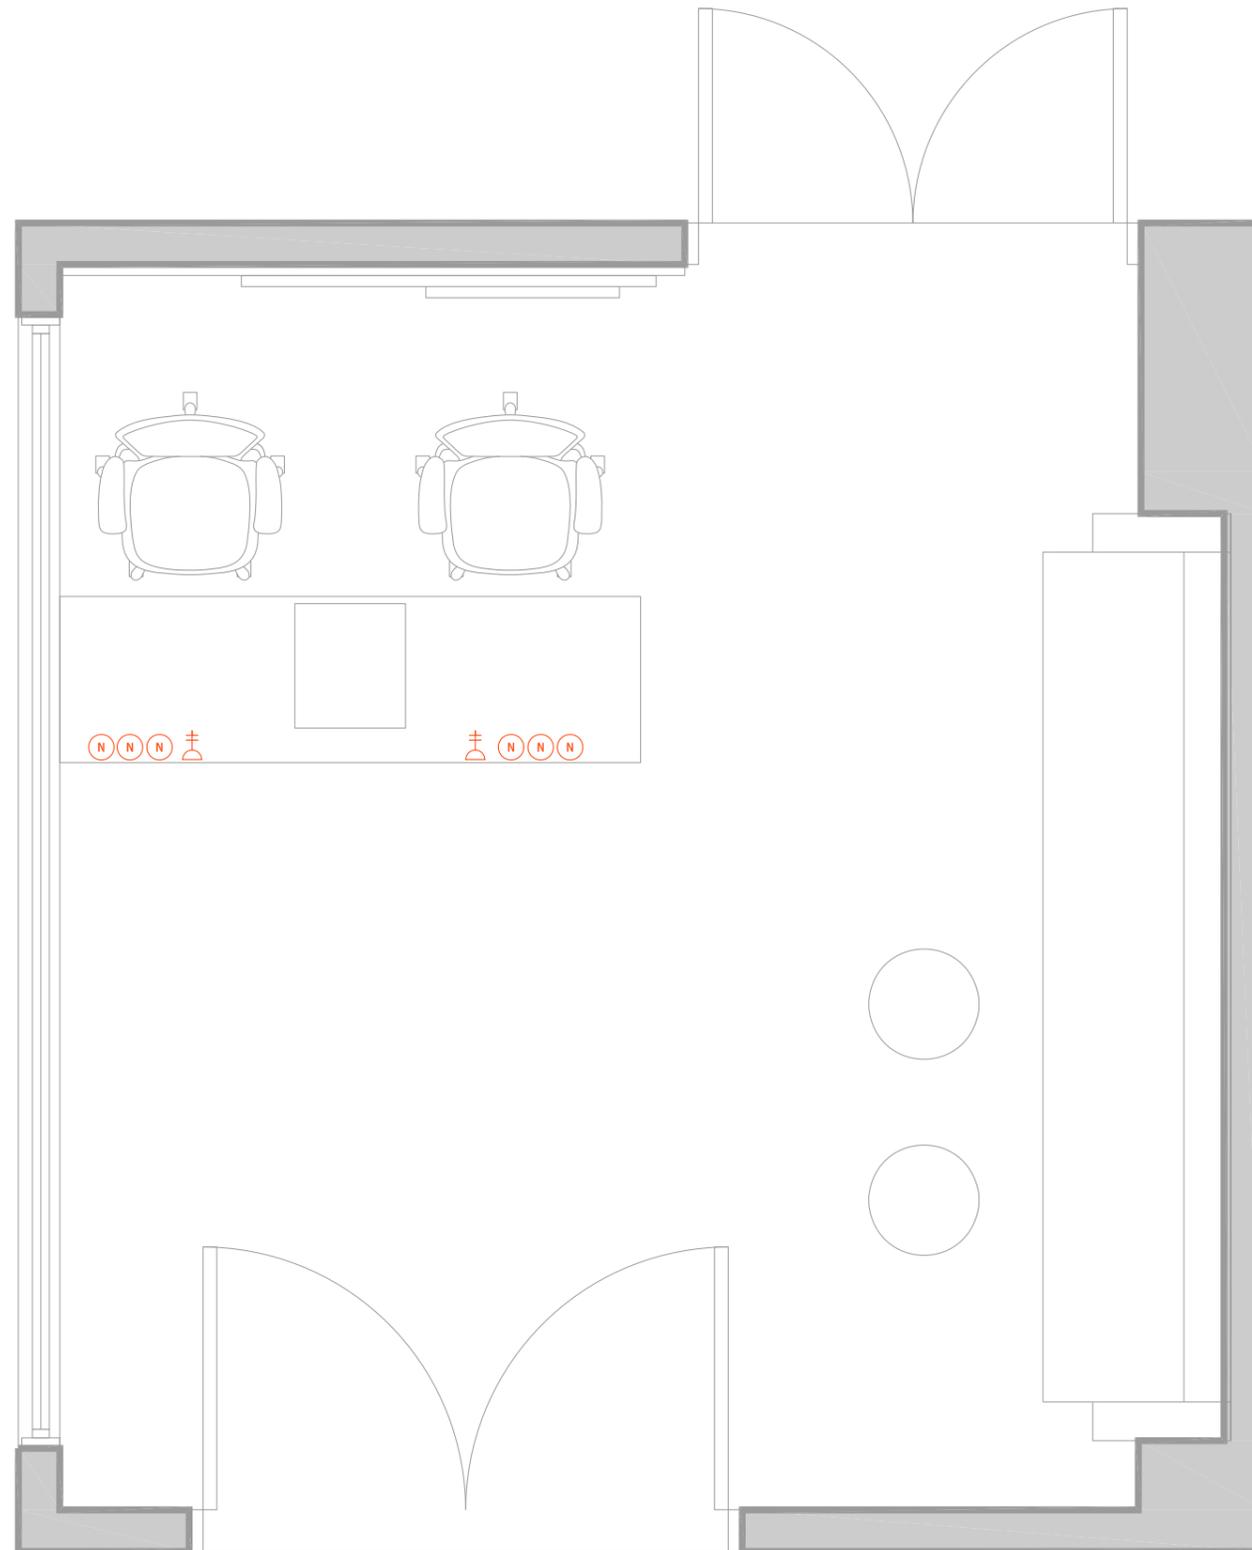

SYMBOLS

-  NETWORK POINT (CAT6)
-  ETHERNET / PHONE (LIST JACK REQUIREMENTS)
-  DOUBLE SOCKET
-  SINGLE SOCKET
-  WATERPROOF DOUBLE SOCKET
-  15 AMP SOCKET FOR AC
-  SHAVER SOCKET
-  FLOOR SOCKET (SPECIFY RECESSED OR SURFACE)
-  THERMOSTAT

GENERAL NOTES

IT IS THE INTENT THAT ALL RECEPTACLES, SWITCHES AND DEVICES BE CENTERED ON ALL FINISHED SURFACES, HORIZONTALLY AND VERTICALLY UNLESS NOTED OTHERWISE. IF FIELD CONDITIONS ARISE THAT MAKE CENTERING IMPOSSIBLE, CONSULT THE ARCHITECT FOR GUIDANCE ON FINAL PLACEMENT. CONTRACTOR SHALL COORDINATE ALL ROOF FRAMING TO ALLOW THE CENTERING SHOWN ON THIS PLAN FOR ALL RECESSED LIGHTING. IF ADDITIONAL FRAMING IS REQUIRED TO ACCOMMODATE THIS LAYOUT, THE CONTRACTOR SHALL INCL. SUCH FRAMING AS PART OF THE COST OF THE WORK. ANY COORDINATION SHALL TAKE PLACE DURING ROUGH FRAMING, PRIOR TO ROUGH-IN.

ALL HEIGHTS ARE FROM FINISHED FLOOR LEVEL EXCEPT WHERE STATED.

ALL LIGHT SWITCHES ARE AT 1.2M AFFL. EXCEPT WHERE STATED.

ALL WALL SOCKETS ARE 350MM AFFL. EXCEPT WHERE STATED.

REFER TO ID DETAIL DRAWINGS FOR LIGHTING FIXTURE AND SOCKETS ON BUILT-IN FURNITURE.

POWER SOCKET FOR AIR CONDITIONER TO BE GIVEN BY M&E SPECIALIST.



Project Name:
**URA
LOBBY INTERIOR**

Client:
URA

Project No. 2024.015



Revisions

Notes
1. Do not Scale Drawing
2. Contractor to check site measurement prior to fabrication
3. All dimensions are in mm.

Project North




Scale 1:20


**POWER & NETWORK
LAYOUT**

A3.06

Sheet No. © 2023

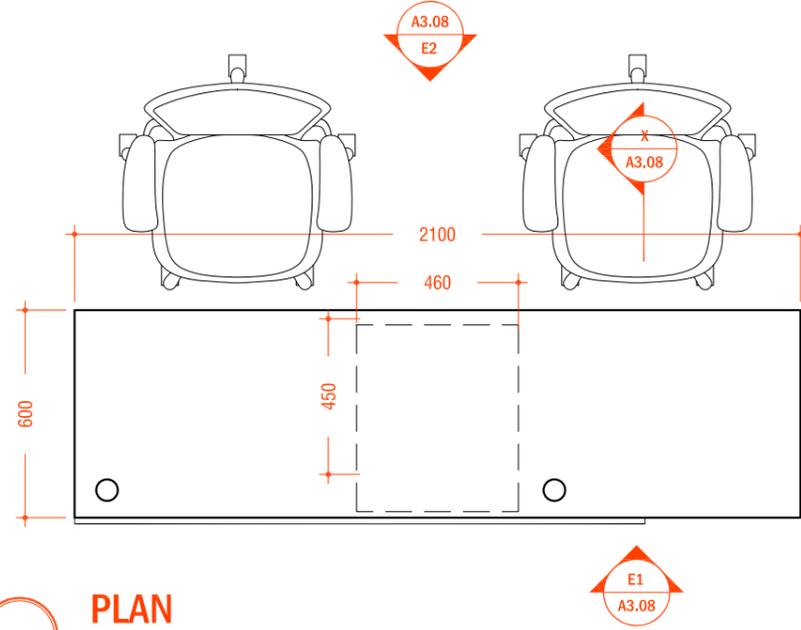

PLAN
SCALE: 1:20

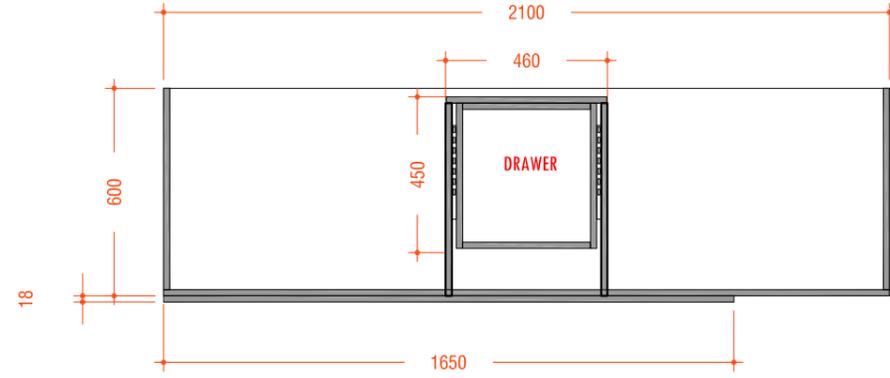

DETAIL SECTIONAL PLAN
SCALE: 1:20



Revisions

- Notes
1. Do not Scale Drawing
 2. Contractor to check site measurement prior to fabrication
 3. All dimensions are in mm.


Project North




Scale 1:20

RECEPTION COUNTER
DETAILS


A3.07

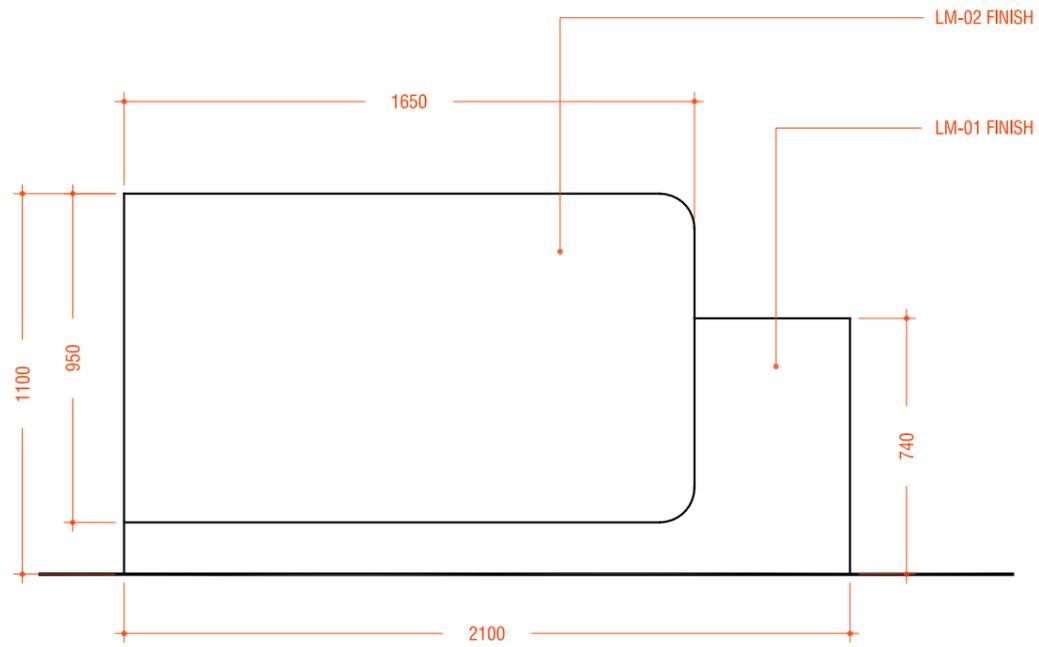

ELEVATION E1
SCALE: 1:20

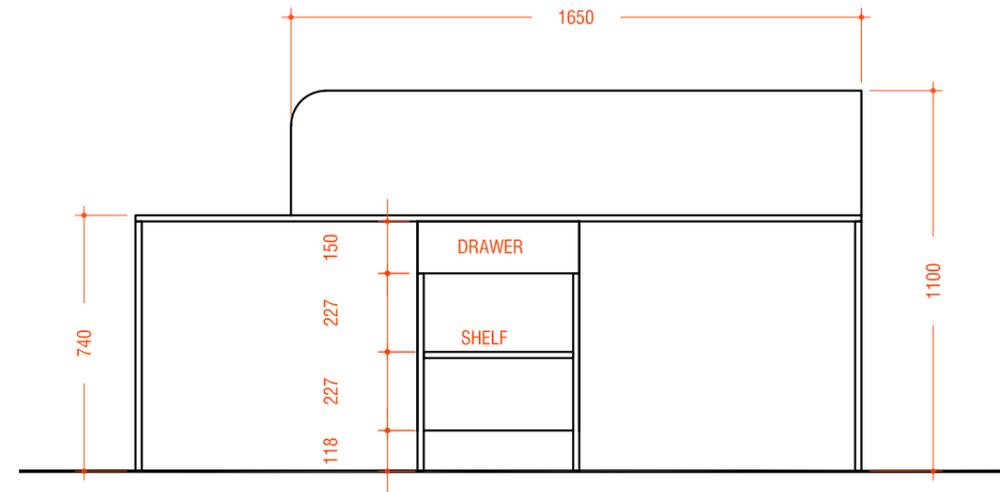

ELEVATION E2
SCALE: 1:20

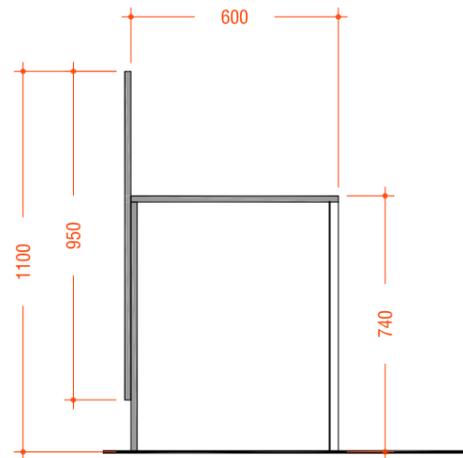

SECTION X-X
SCALE: 1:20

FINISHES

	CODE	DESCRIPTION
	LM-01	LAMITAK FINISH
	LM-02	LAMITAK FINISH



Project Name:
**URA
LOBBY INTERIOR**

Client:
URA

Project No. 2024.015



Revisions

Notes
1. Do not Scale Drawing
2. Contractor to check site measurement prior to fabrication
3. All dimensions are in mm.

Project North




Scale 1:20


**RECEPTION COUNTER
DETAILS**

A3.08

Sheet No. © 2023

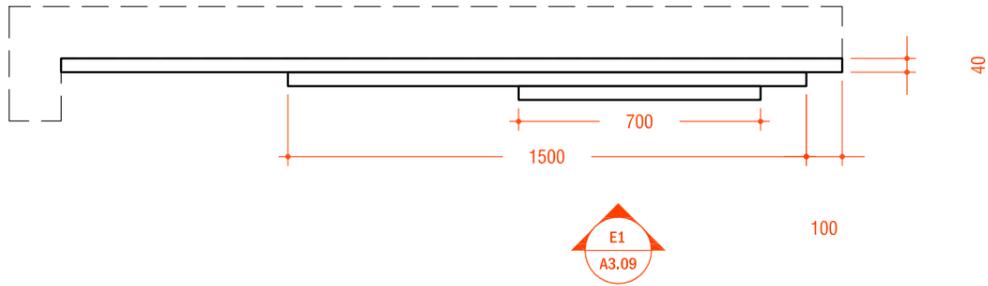

PLAN
SCALE: 1:20

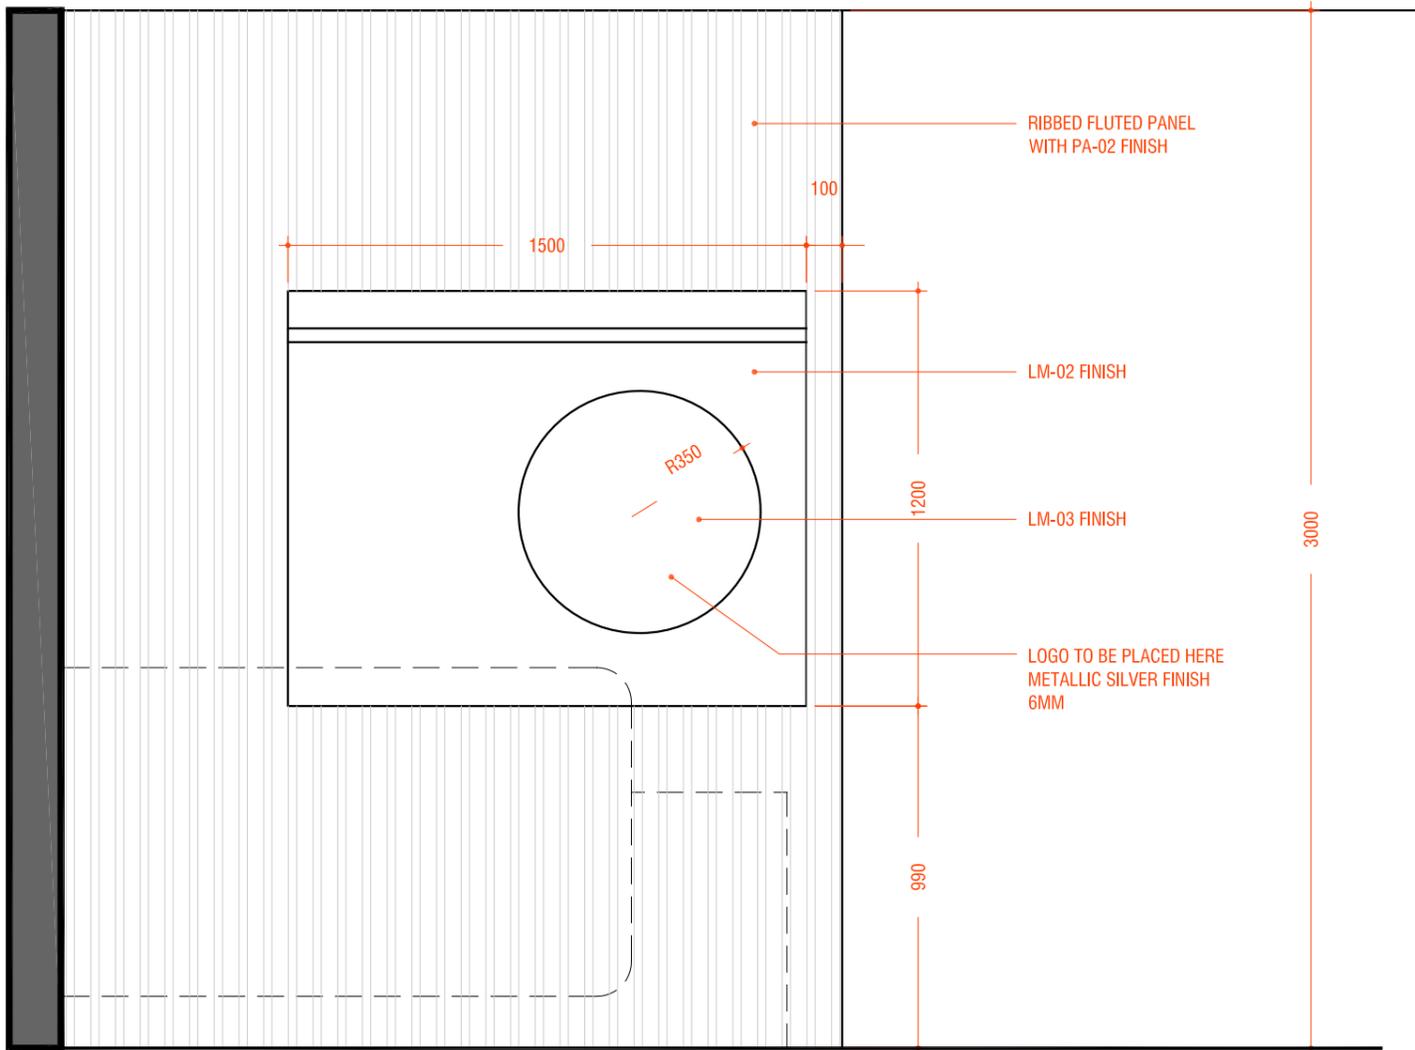

ELEVATION E1
SCALE: 1:20

FINISHES

	CODE	DESCRIPTION
	LM-02	LAMITAK FINISH
	LM-03	LAMITAK FINISH



Revisions

No.	Description

- Notes
- Do not Scale Drawing
 - Contractor to check site measurement prior to fabrication
 - All dimensions are in mm.







PLAN
SCALE: 1:20

FINISHES

	CODE	DESCRIPTION
	LM-01	LAMITAK FINISH
	LM-02	LAMITAK FINISH

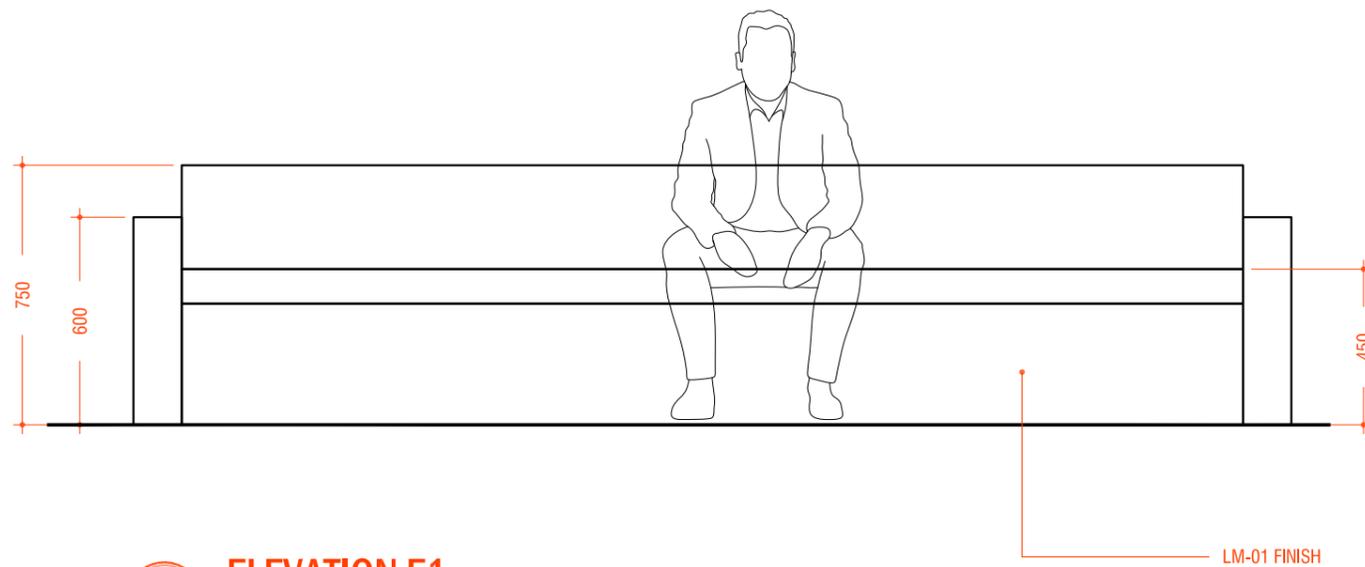

ELEVATION E1
SCALE: 1:20

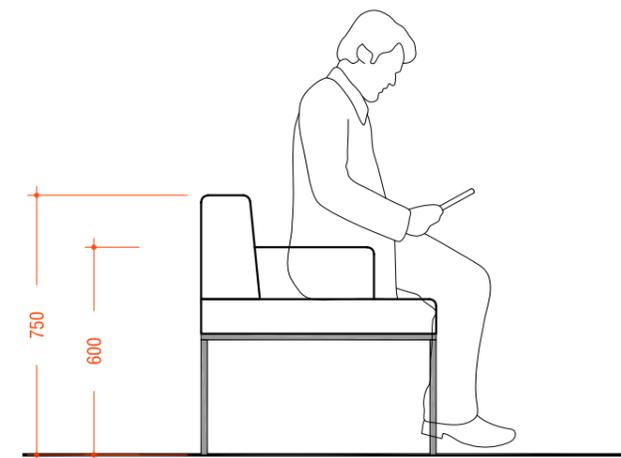

SECTION X-X
SCALE: 1:20



Revisions

- Notes
- Do not Scale Drawing
 - Contractor to check site measurement prior to fabrication
 - All dimensions are in mm.

Project North



Scale 1:20
BENCH DETAILS