



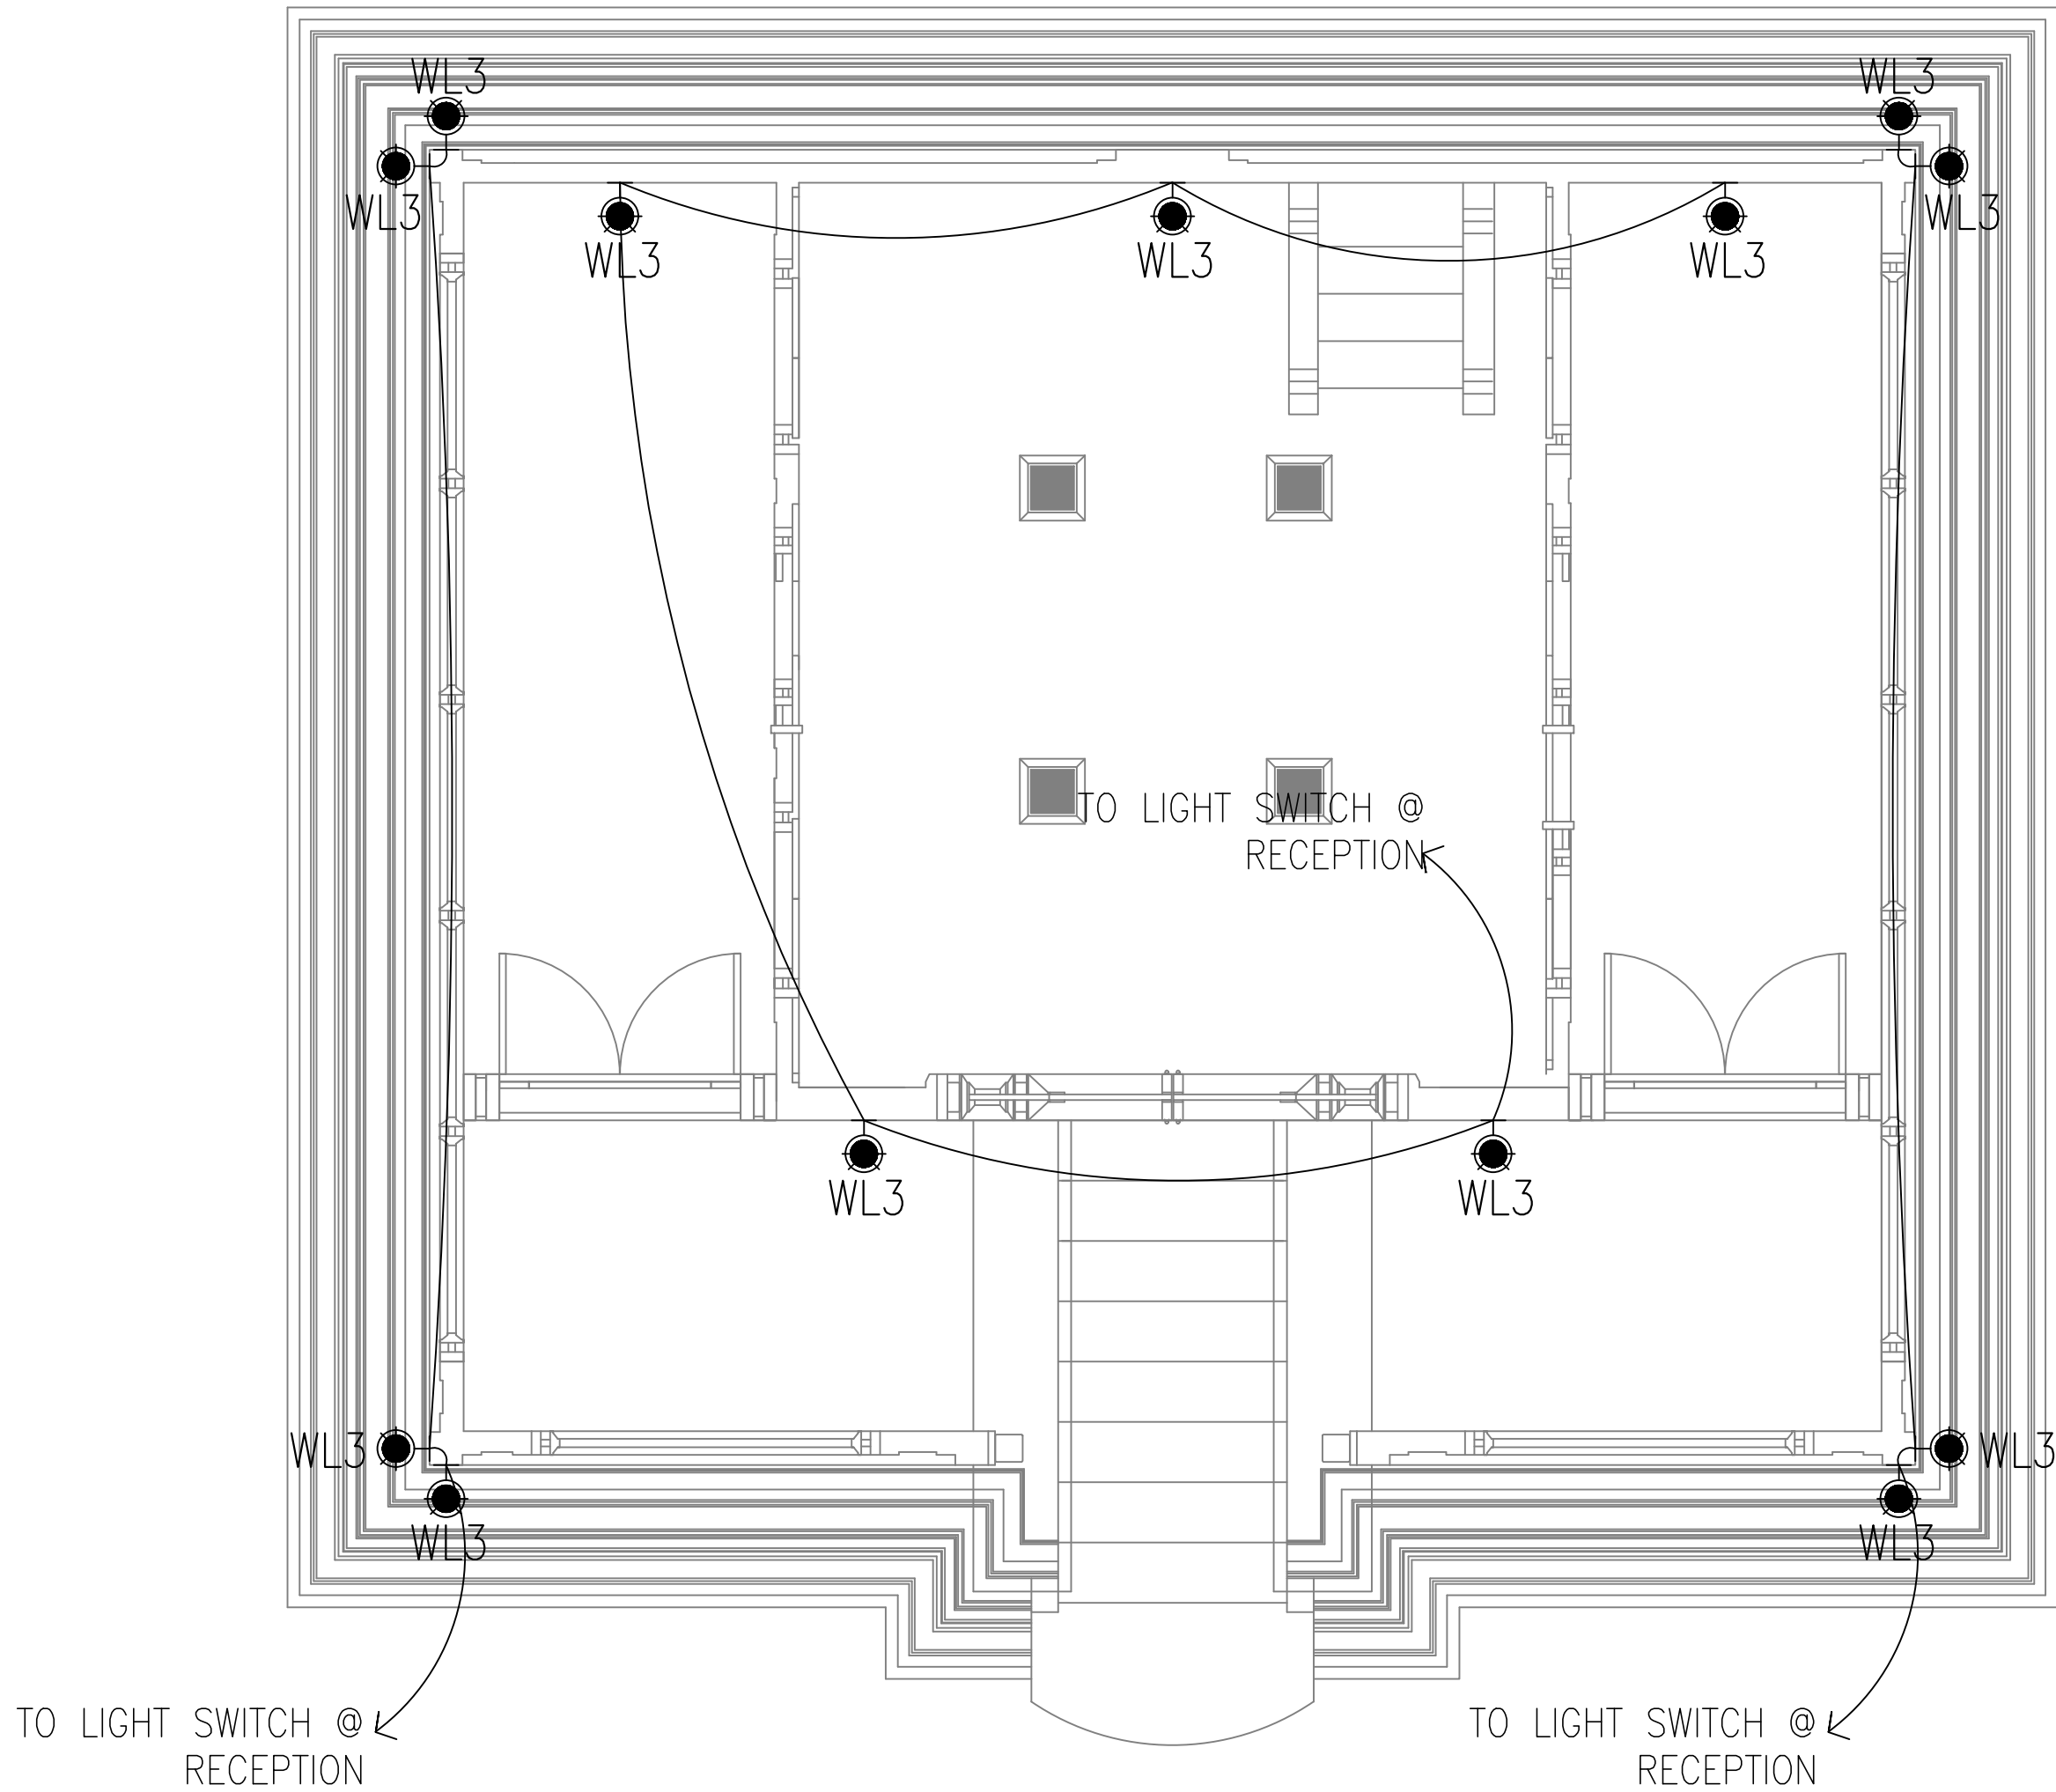


FLOOR LIGHTING PLAN

SCALE 1:100

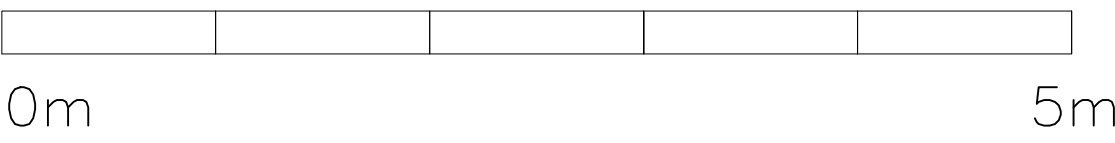

LIGHTING LEGEND		
SYMBOL	CODE	DECRPTION
	CL1	CEILING MOUNTED LED DOWN LIGHT (15W)
	CL2	CEILING MOUNTED LED DOWN LIGHT (15W) WEATHER PROOF
	CL2	CEILING MOUNTED LED DOWN LIGHT WITH DIFFUSER (15W)
	CL3	CEILING MOUNTED LED DOWN LIGHT WITH DIFFUSER (10W)
	BL1	WALKWAY BOLLARD LIGHT (10W)
	TL1	LED TABLE TOP LIGHT (10W)
	CL4	300X300mm LED CEILING MOUNTED LIGHT (20W)
	LL1	LED STREET LIGHT (20W)
	LL2	LED GATE PILLAR LIGHT (20W)
	PL1	LED PENDANT LIGHT (15W)
	VL1	LED MIRROR BACK VANITY LIGHT (15W)
	SL1	LED UNDER CUPBOARDS STRIP LIGHT (10W)
	WL1	LED WALL MOUNTED LIGHT (20W)
	WL2	LED WALL MOUNTED LIGHT (UP AND DOWN) (20W)
	WL3	LED WALL MOUNTED LIGHT (DOWN) (20W)
	TR1	LED TRAC LIGHT (10W)
	xxW xxG	LIGHT SWITCH (xxW = No fo WAY xxG = No fo GANG)
	MDB	POWER MAIN DISTRIBUTION BOARD
	SDB	POWER SUB DISTRIBUTION BOARD
	PL	DECORATIVE PENDENT LIGHT
	VF	VENTILATION FAN

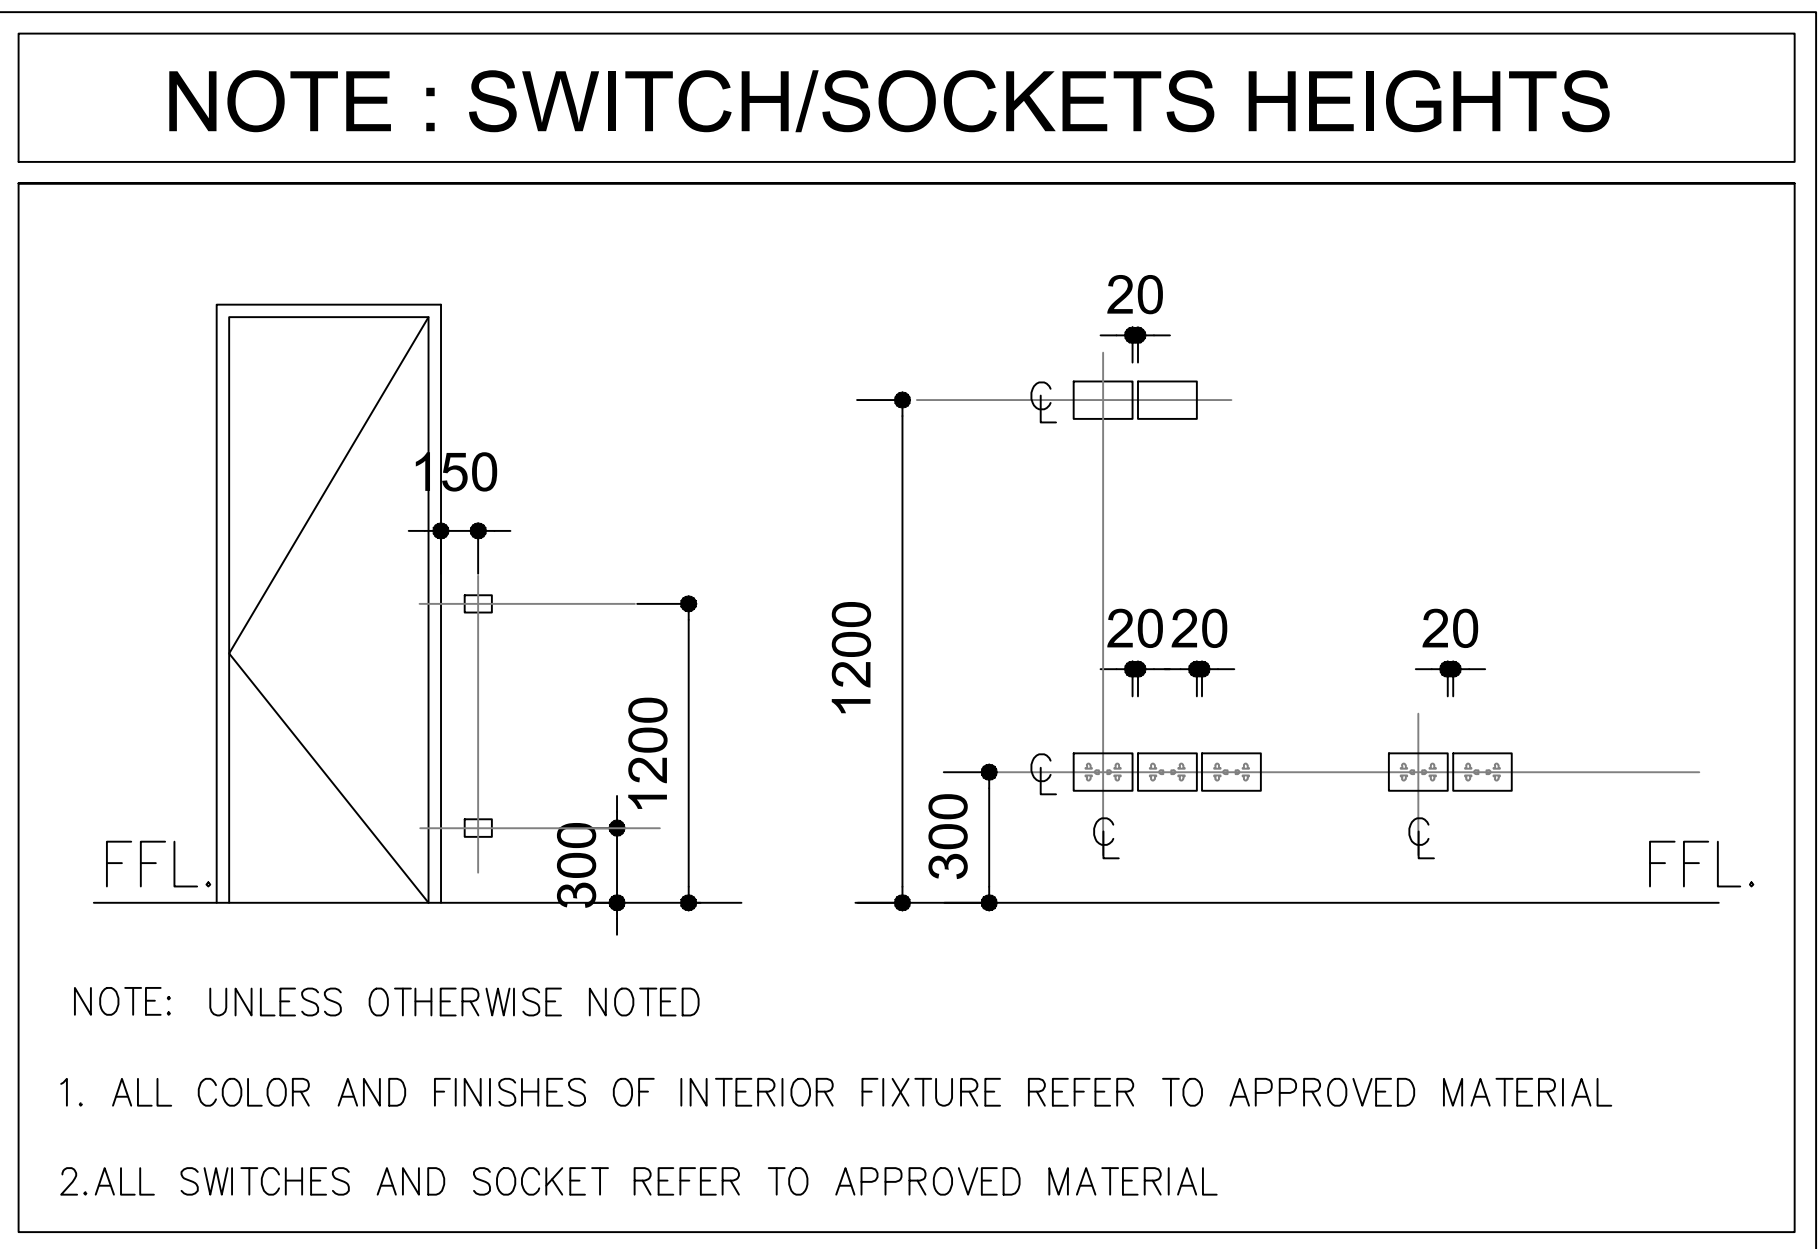

NOTE:
ALL WIRING TO BE OF MEA APPROVED STANDARDS
ALL WIRING TO BE DONE IN CONDUITS INSIDE SLABS/WALLS
ELECTRICAL DB LEVEL = 1600MM FROM FLOOR FIN. LEVEL
FLOOR LEVEL SOCKETS = 300MM FROM FLOOR FIN. LEVEL
SWITCH CONTROLS = BOTTOM 1150MM FROM FLOOR FIN. LEVEL
AC = 2500MM FROM FLOOR FIN. LEVEL.

CLIENT:
GDH.THINADHOO COUNCIL

SIARCH
PRIVATE LIMITED
LONUZIYAARIY MAGU,MALE',20075,MALDIVES
EMAIL: INFO@SIARCH.DESIGN
HTTP://WWW.SIARCH.DESIGN

DESIGN:

DXYN
PRIVATE LIMITED
M. Alcyon Emerald, Male' Maldives.

KEY PLAN:

WARNING:

- This drawing shall not be used for construction unless certified.
- Contractor to verify all dimensions of existing works on site before commencing any work or preparing shop drawings.
- Do not scale drawings, use written dimensions only.
- This drawing is to be read in conjunction with the specifications and conditions of contract.
- This drawing and design is copyright and no portion may be reproduced without the permission of the Consultant

REVISIONS		
NO	DESCRIPTION	DATE

PROJECT:
GDH.THINADHOO
HERITAGE PARK

PHASE:

- CONCEPT DESIGN
- DESIGN DEVELOPMENT
- TENDER DOCUMENT
- FOR CONSTRUCTION
- AS BUILD DRAWINGS

DESIGNATION	NAME	SIGNATURE
PROJECT MANAGER	SIARCH PVT LTD	
STR. ENGINEER	ALI NISHAM	
CHIEF ARCHITECT	MUTHU	
CHECKED	MOHAMED SIRAJ	
DRAWN	SAMPATH	

DWG. NAME:

MEP

FLOOR LIGHTING
PLAN

CODE COM-17	DATE 07.04.2023	DWG. NO: MEP01
FORMAT A1 A2 A3	SCALE - 1:100 -	ISSUE A
PDF FILE NAME: BAR-CA_MEP01_A		