

**Proposed 02 Classroom Block at
HDh. Nellaidhoo School
(02 Storey)**

SERVICES DRAWING
Client: Ministry of Education




RIYAN PRIVATE LIMITED
t: +960315049 f: +9603310776
e: info@riyan.com.mv
w: www.riyan.com.mv
3rd floor, H. Azur, Aneeneenogu, Male'

The contents of these drawings remain as a property of Riyan Private Limited. Any use other than those expressly stated is a violation of this copyright

TABLE OF CONTENTS

DRAWING No.	TITLE	REVISION No.	DATE	REMARKS
A R C H I T E C T U R A L				
DR - 01 /03	GROUND FLOOR DRAINAGE LAYOUT	---	---	---
DR - 02 /03	1ST FLOOR DRAINAGE LAYOUT	---	---	---
DR - 03 /03	ROOF DRAINAGE LAYOUT	---	---	---
EL - 01 / 02	GROUND FLOOR LIGHTING LAYOUT	---	---	---
EL - 02 / 02	1ST FLOOR LIGHTING LAYOUT	---	---	---
EP - 01 / 02	GROUND FLOOR POWER LAYOUT	---	---	---
EP - 02 / 02	1ST FLOOR POWER LAYOUT	---	---	---

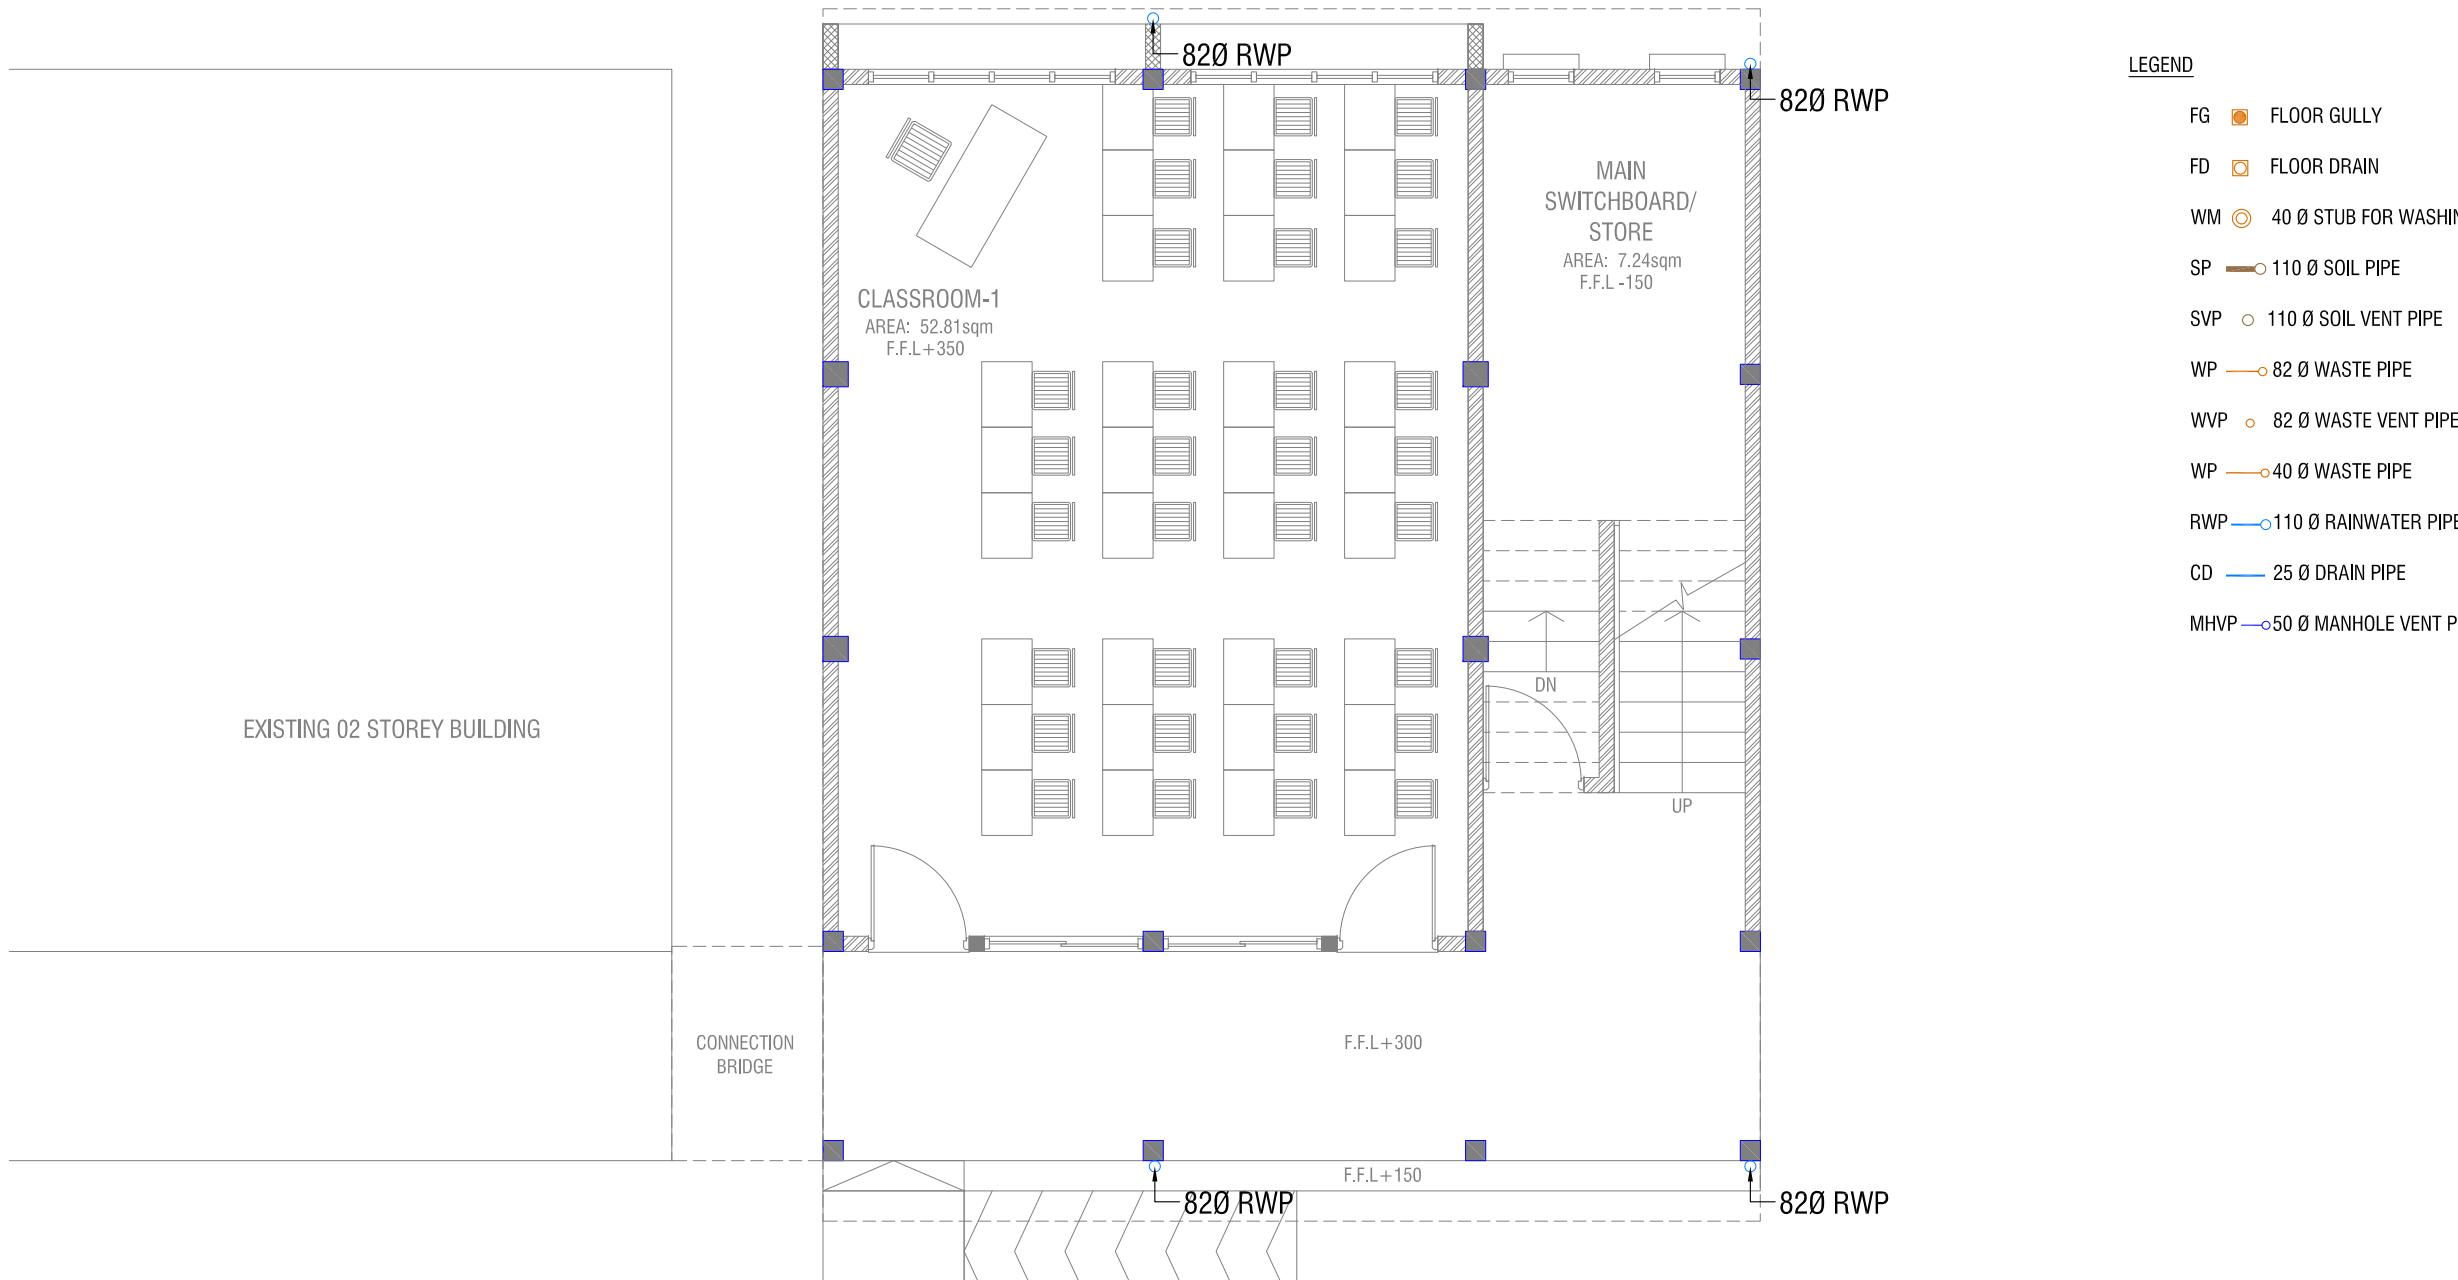

GROUND FLOOR DRAINAGE LAYOUT

SCALE 1:75

0 0.5 1 2 3 4 5

HDh.Nellaidhoo School - 02 Classroom (02 Storey)
Client: Ministry of Education

Project Number:	R/2019/012	Date:
Architect:	Razana Amir	Engineer:	Isaam Waheed
Drawn by:	Mohamed Yashiq	Services :	Aishath Ahmed
Interior :




RIYAN PRIVATE LIMITED

t : +960319049 f : +960310776
e : info@ryan.com.mv
w : www.ryan.com.mv
3rd floor, H. Azum, Ameeneenagu, Male'

Title: Ground Floor
Drainage Layout
Page: DR 01-03

FIRST FLOOR DRAINAGE LAYOUT

SCALE 1:75

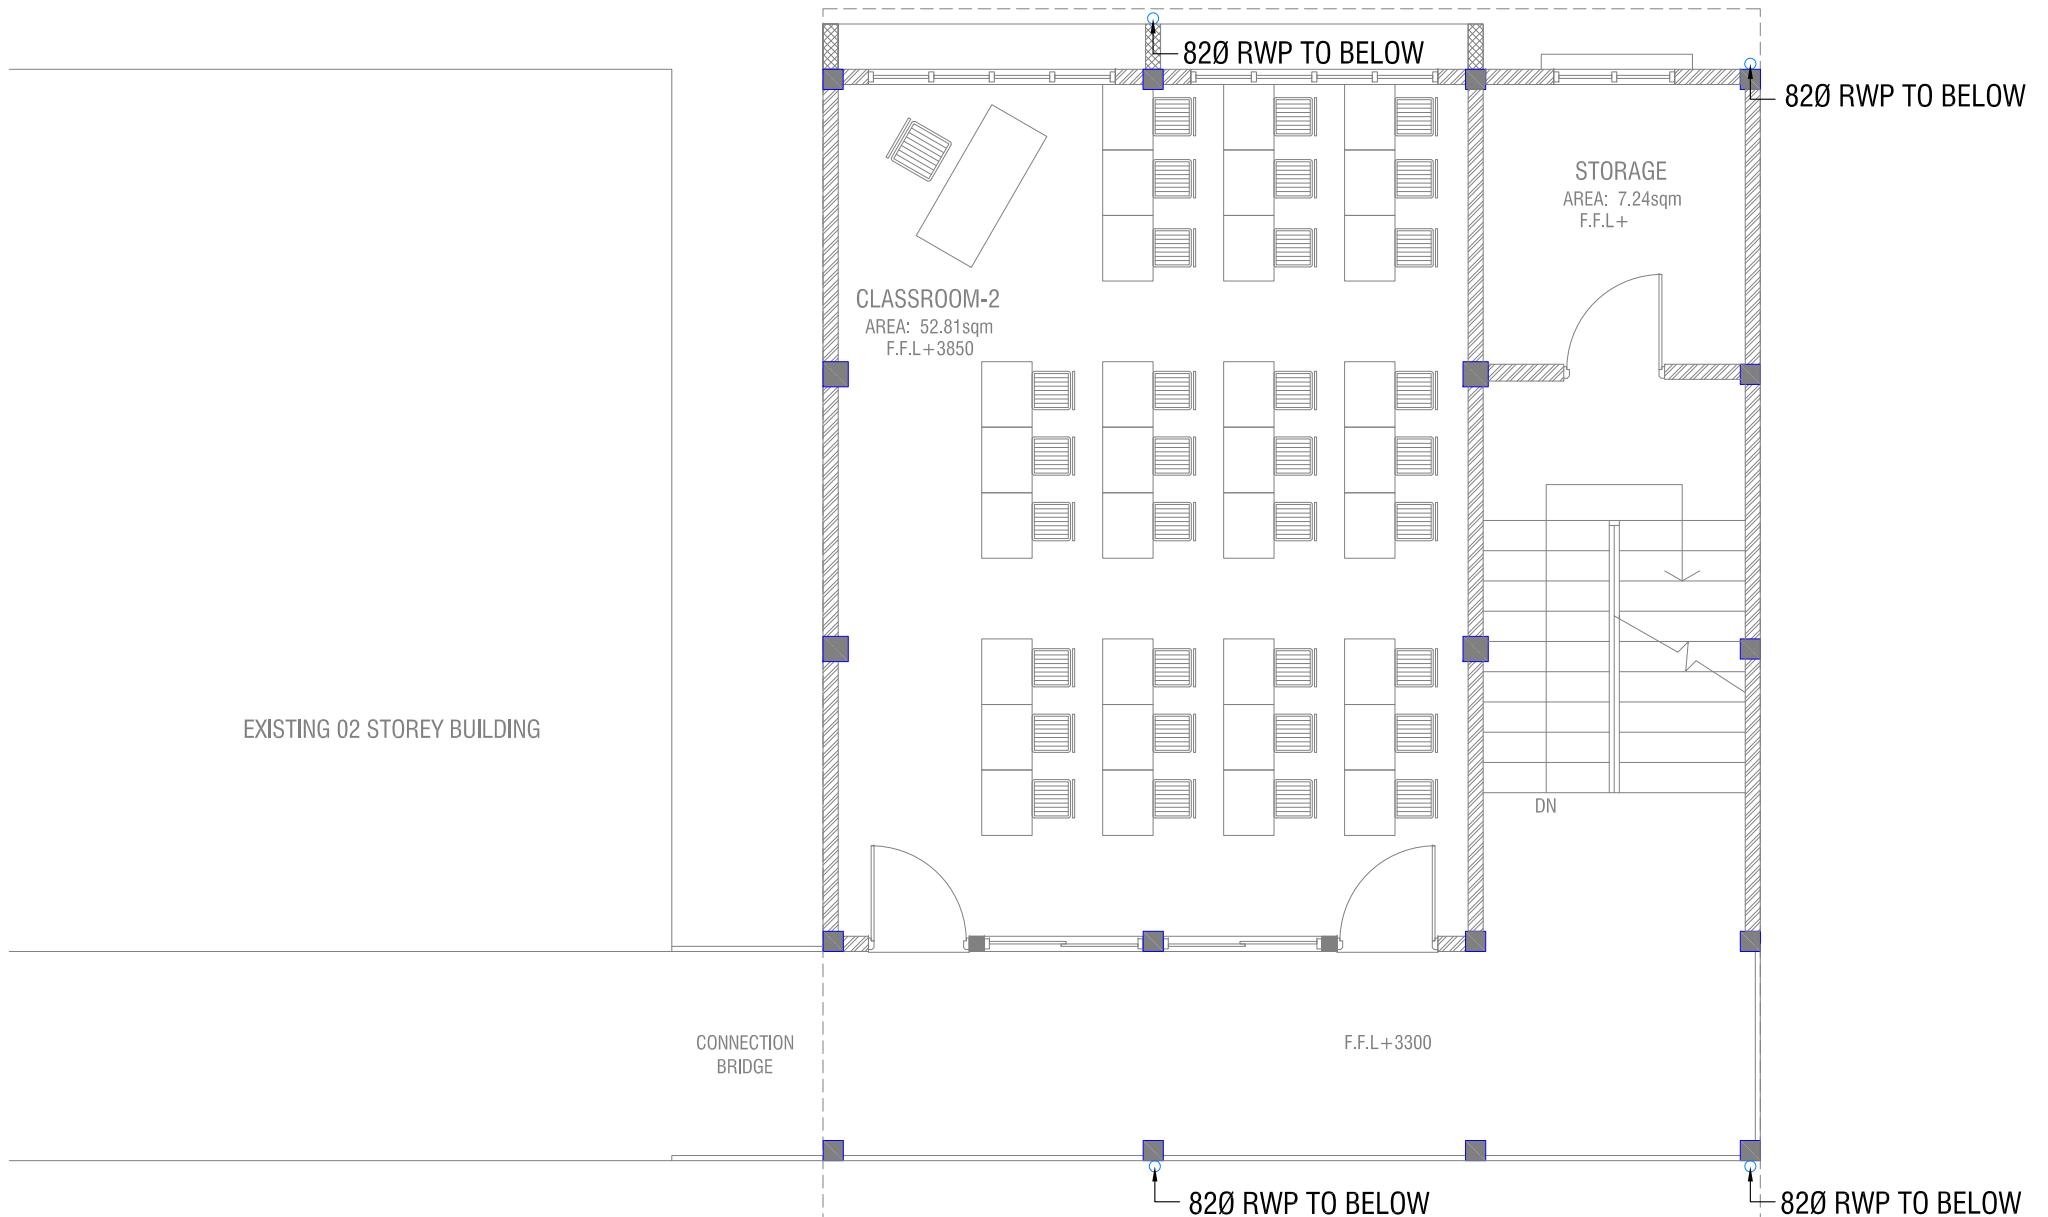

LEGEND

FG  FLOOR GULLY

FD  FLOOR DRAIN

WM  40 Ø STUB FOR WASHING MACHINE

SP  110 Ø SOIL PIPE

SVP  110 Ø SOIL VENT PIPE

WP  82 Ø WASTE PIPE

WVP  82 Ø WASTE VENT PIPE

WP  40 Ø WASTE PIPE

RWP  110 Ø RAINWATER PIPE

CD  25 Ø DRAIN PIPE

MHVP  50 Ø MANHOLE VENT PIPE

HDH.Nellaidhoo School - 02 Classroom (02 Storey)
Client: Ministry of Education

3


t: +9603315049 f: +9603310776
e: info@rtuan.com.mv

Title: First Floor Drainage Layout

The contents of t

ROOF DRAINAGE LAYOUT

SCALE 1:75

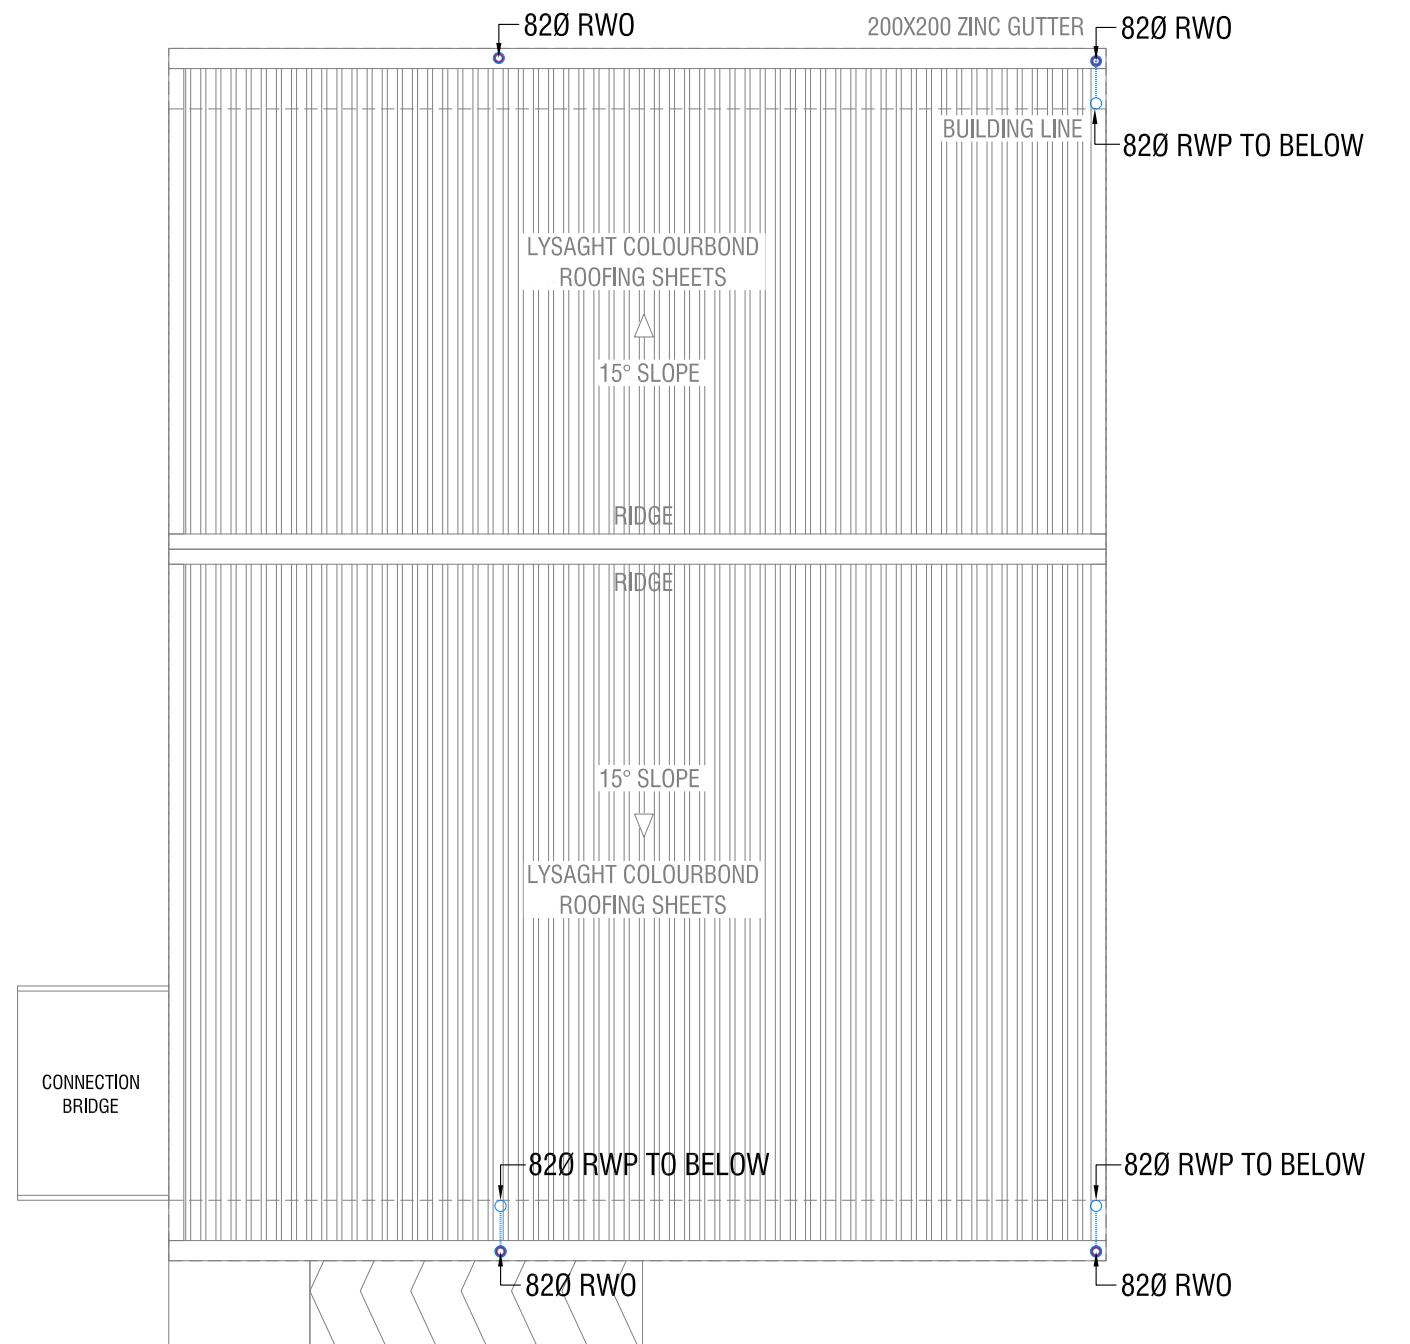

LEGEND

FG	■ FLOOR GULLY
FD	□ FLOOR DRAIN
WM	○ 40 Ø STUB FOR WASHING MACHINE
SP	— 110 Ø SOIL PIPE
SVP	○ 110 Ø SOIL VENT PIPE
WP	— 82 Ø WASTE PIPE
WVP	○ 82 Ø WASTE VENT PIPE
WP	— 40 Ø WASTE PIPE
RWP	— 110 Ø RAINWATER PIPE
CD	— 25 Ø DRAIN PIPE
MHVP	— 50 Ø MANHOLE VENT PIPE

HDh.Nellaidhoo School - 02 Classroom (02 Storey)
Client: Ministry of Education




RIYAN PRIVATE LIMITED

t : +960318049 f : +960310776
e : info@riyan.com.mv
w : www.riyan.com.mv
3rd floor, H. Azum, Ameeneenagu, Male'

Title: Roof
Drainage Layout

Page: DR 01-03

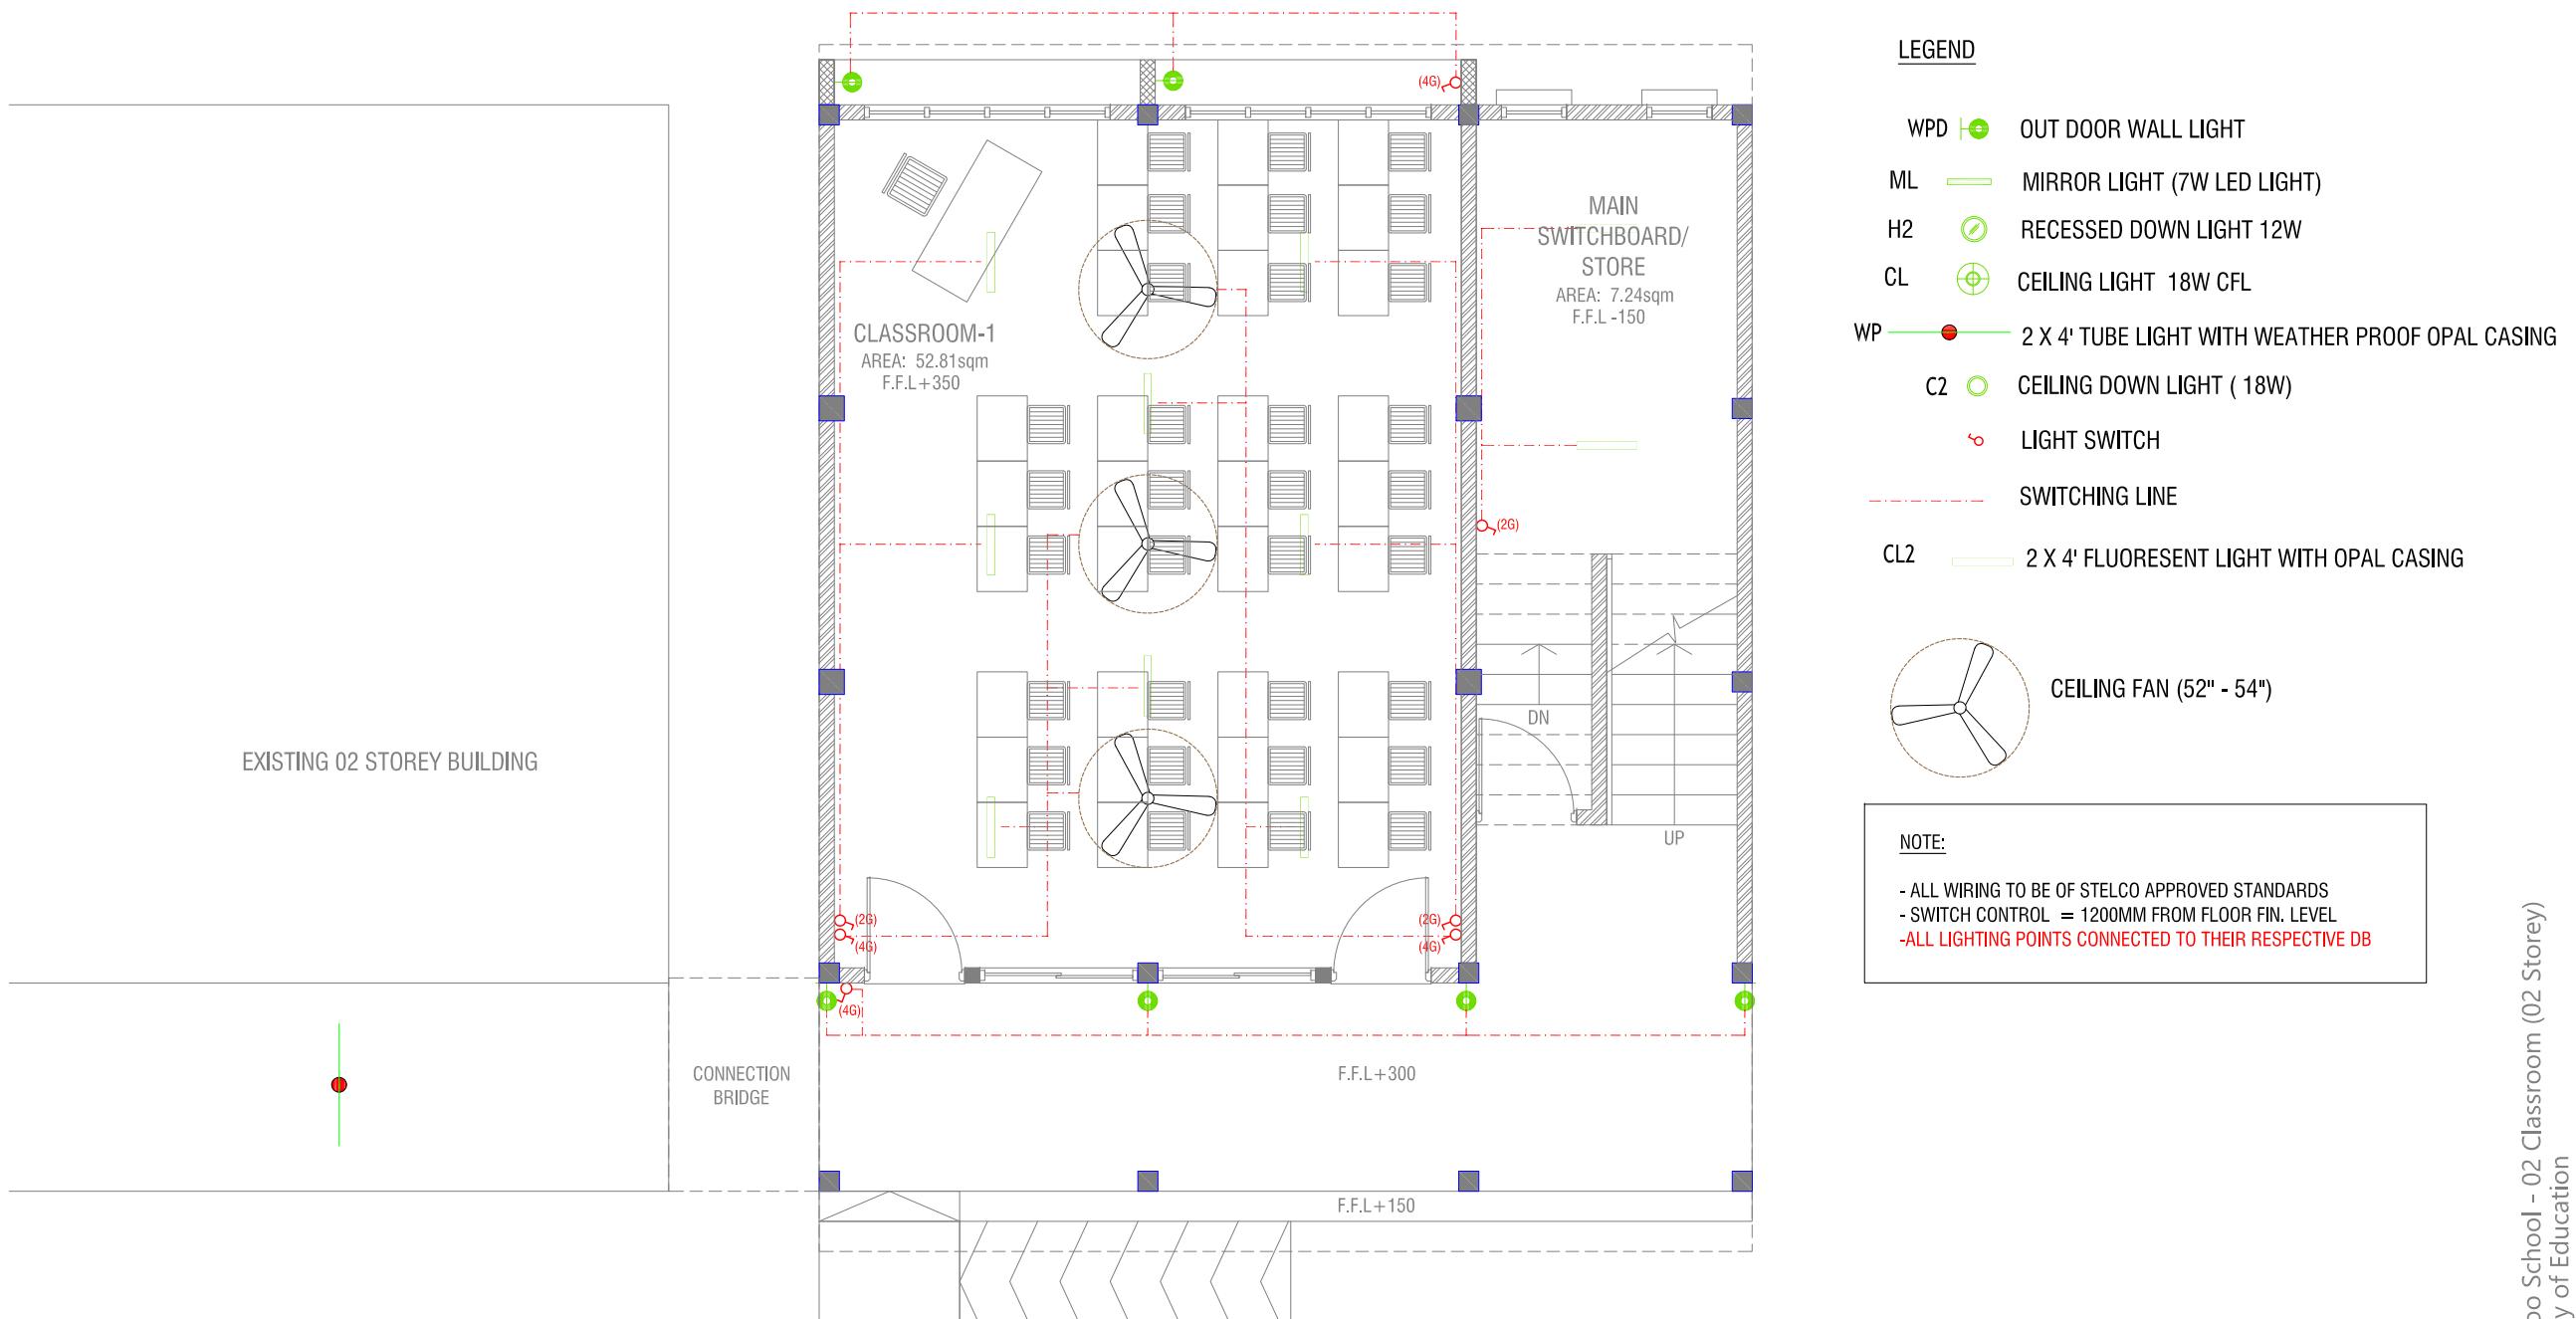



GROUND FLOOR LIGHTING LAYOUT

SCALE 1:75

0 0.5 1 2 3 4 5



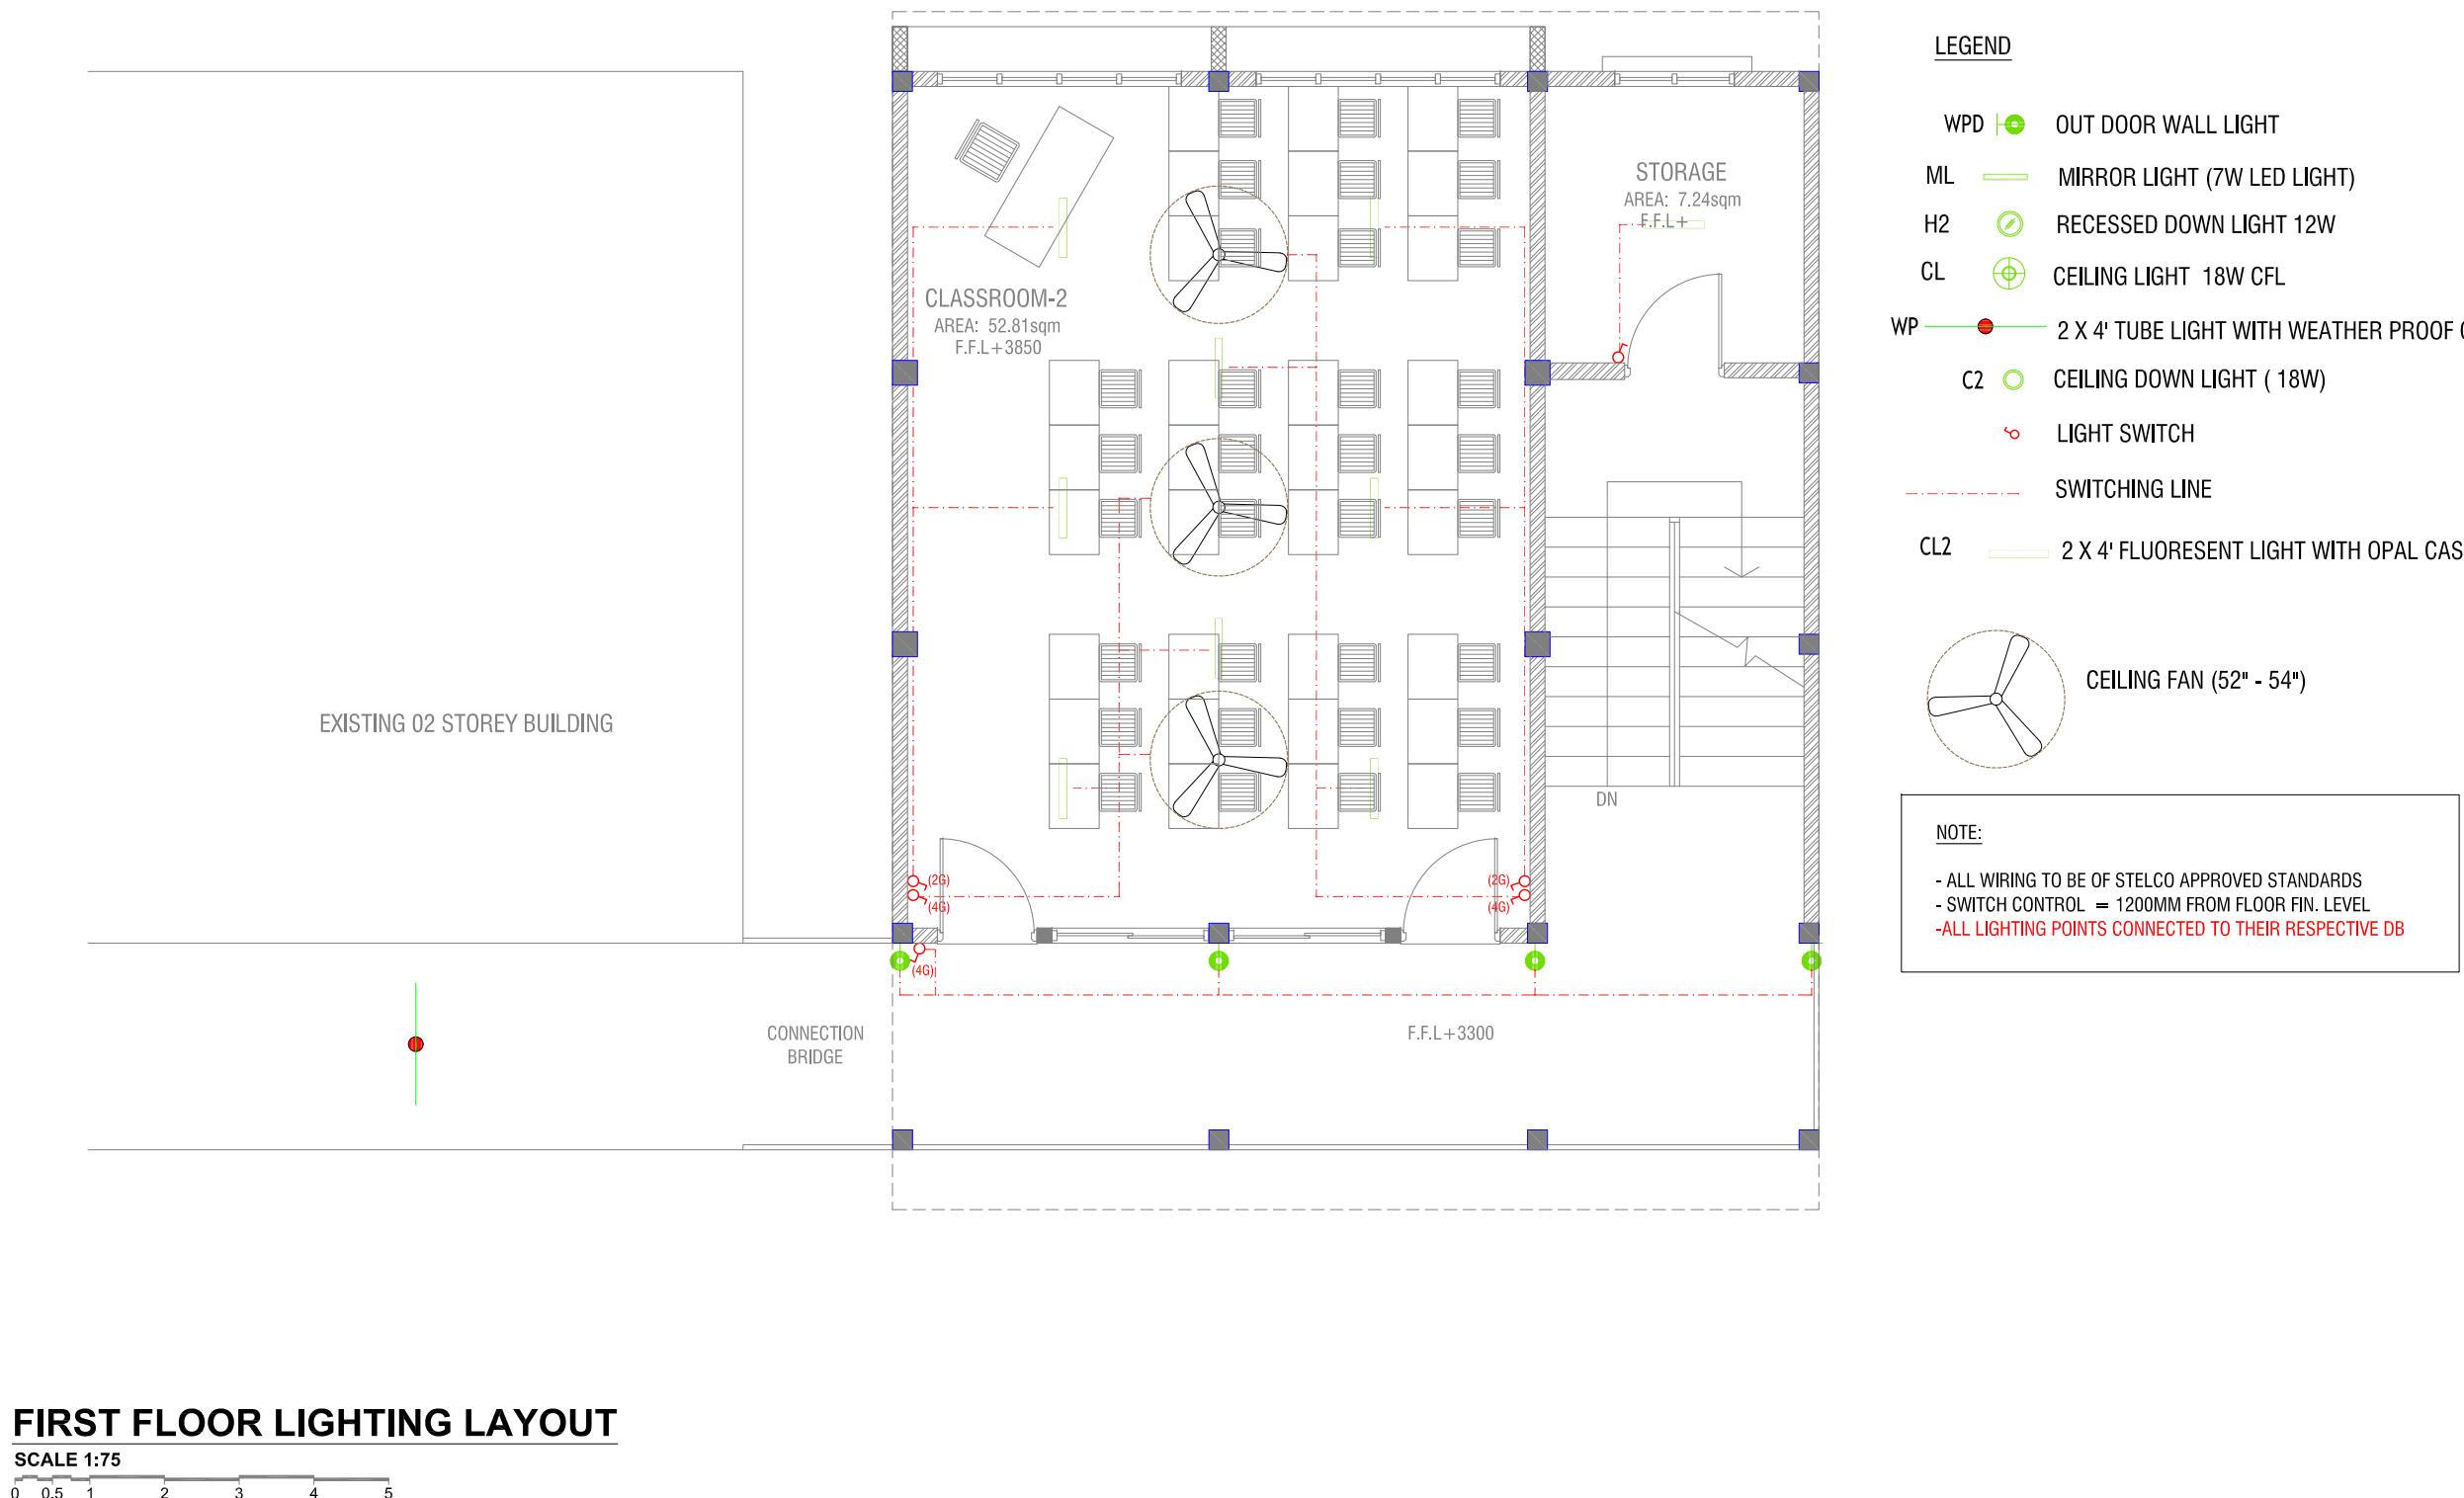

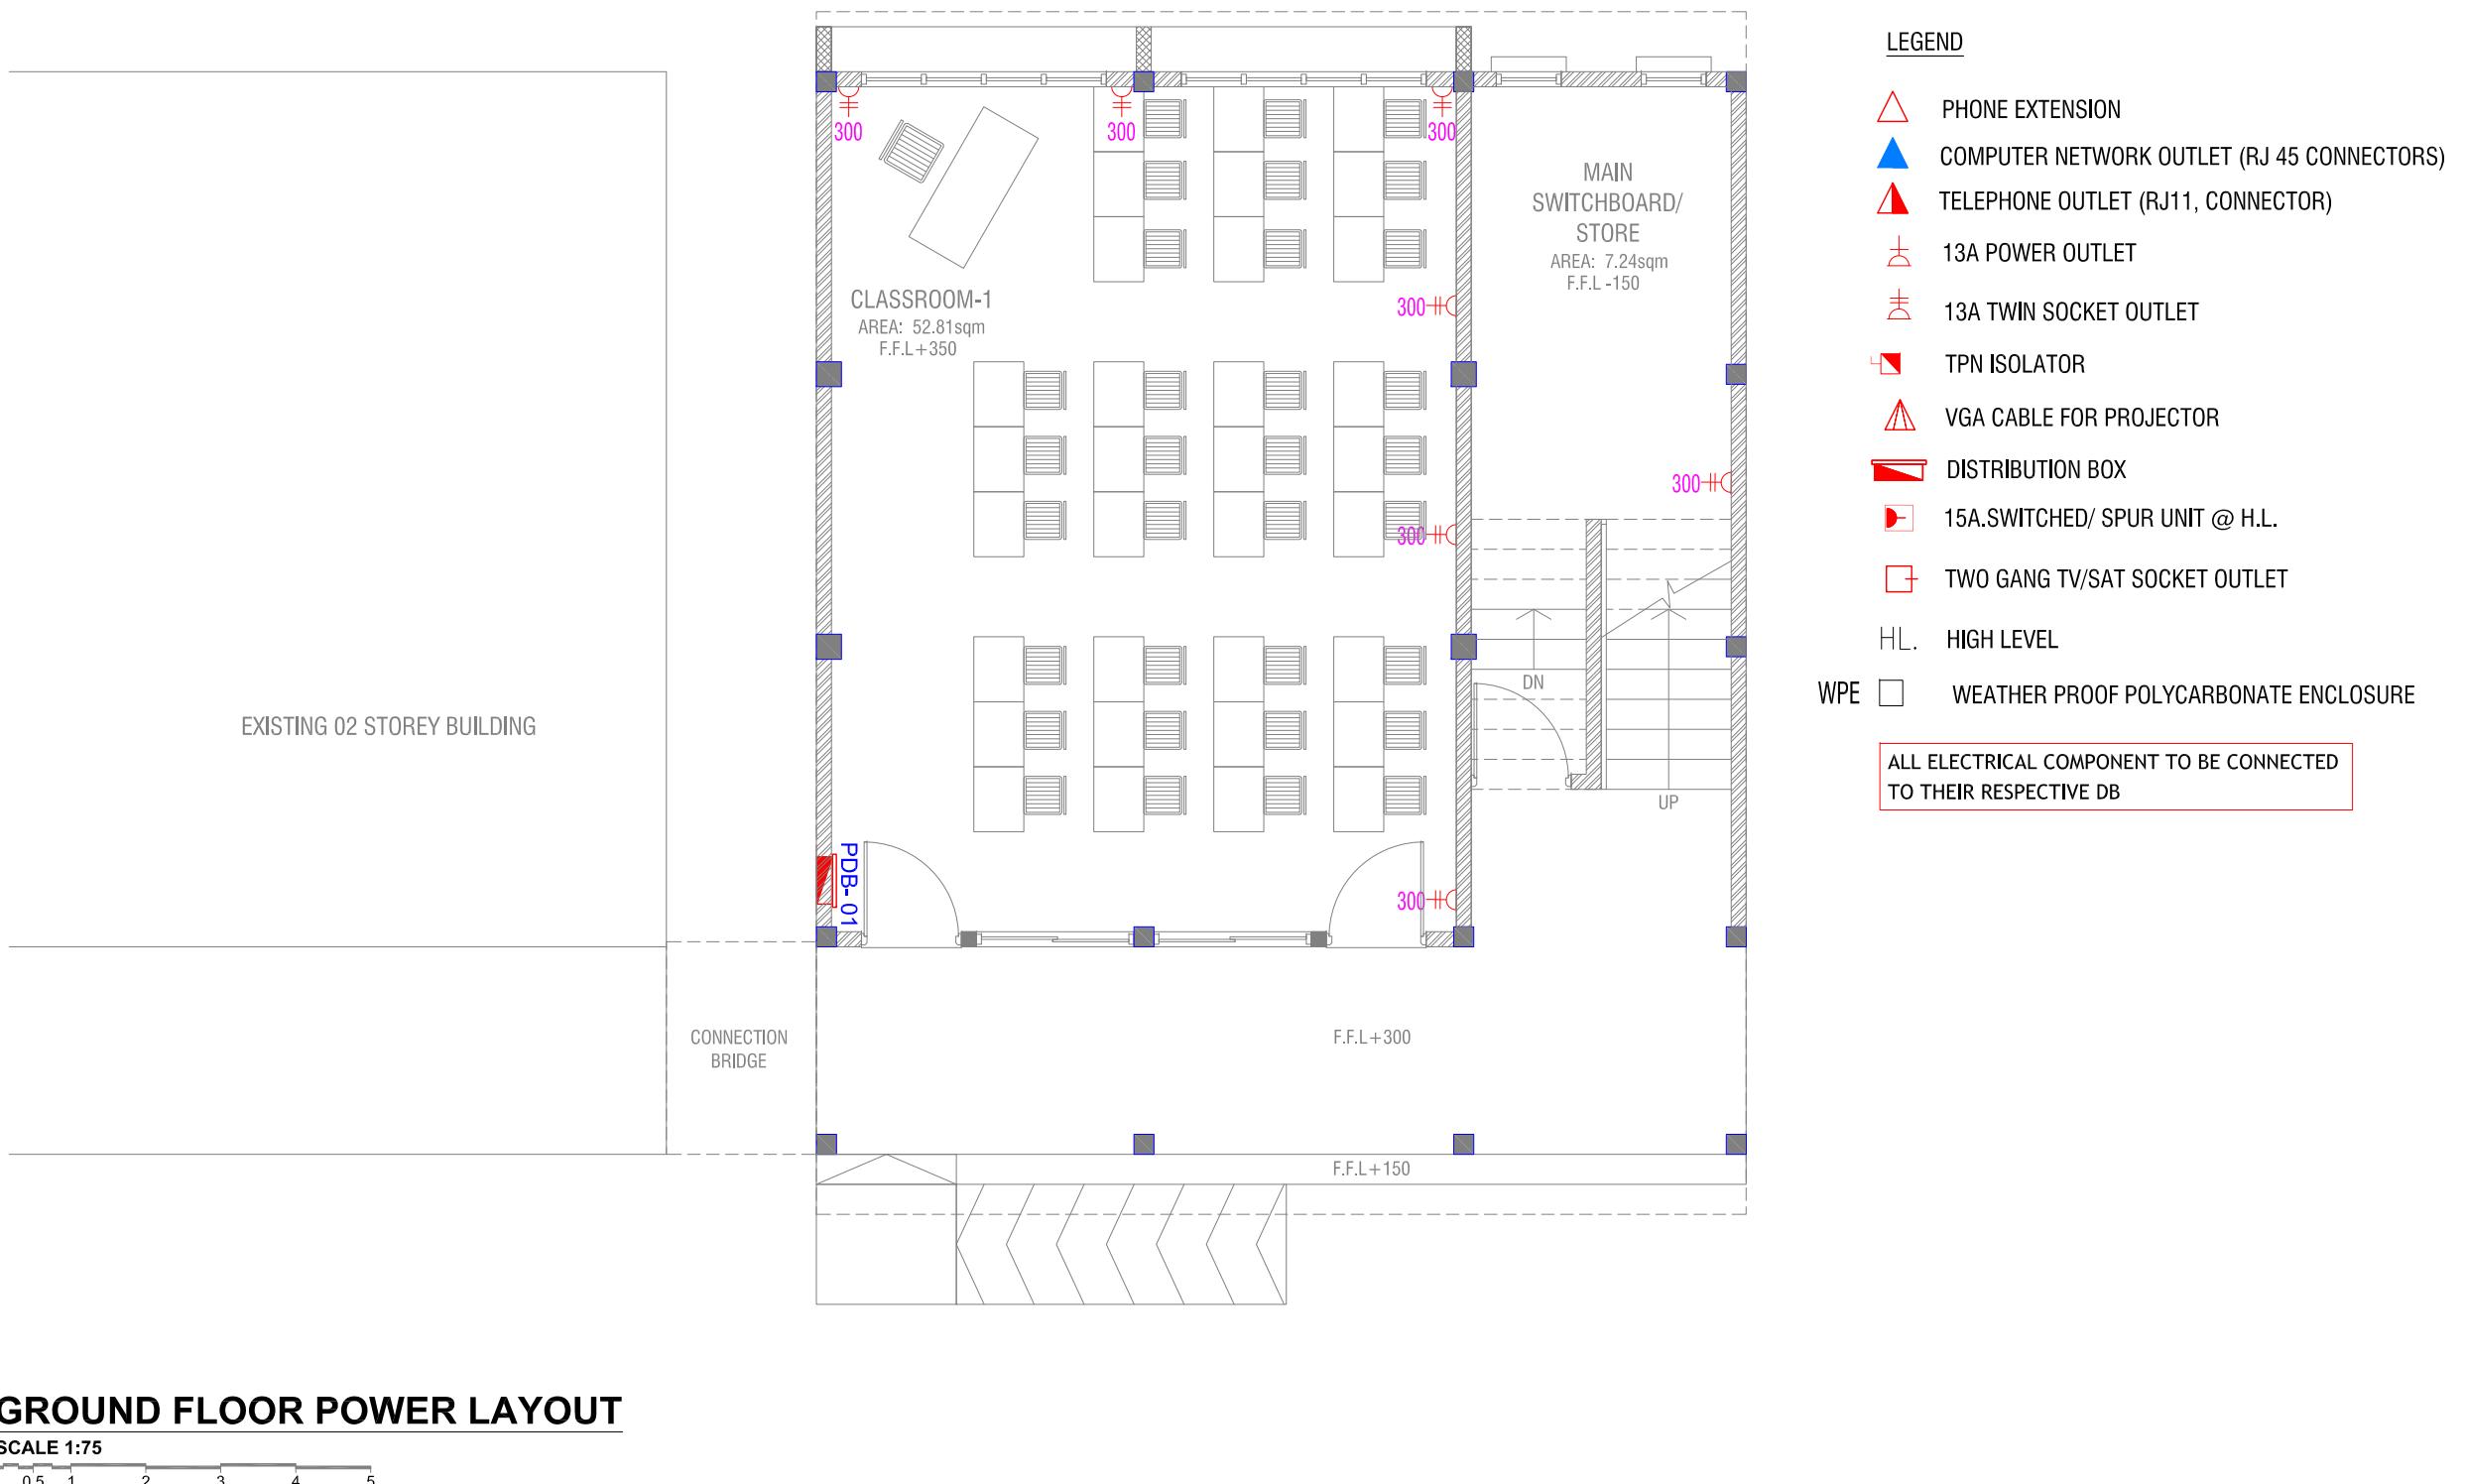

HDH.Nellaidhoo School - 02 Classroom (02 Storey)
Client: Ministry of Education

3

YAN PRIVATE LIMITED
t : +9603315049 f : +9603310776
e : info@ryan.com.mv

Site: Ground Floor Power Layout

The contents of t

FIRST FLOOR DRAINAGE LAYOUT

SCALE 1:75



HDh Nellaidhoo School - 02 Classroom (02 Storey)
Client: Ministry of Education

Project Number: R/2019/012
Date: June 2019

2

t: +9603315049 f: +9603310776
e: info@rutan.com.mv

Title: First Floor
Power Layout

The contents of t