FOOTBALL STADIUM CHANGING ROOM, SEATINGS, CAFE', SHOP ARCHITECTURAL, STRUCTURAL, ELECTRICAL & PLUMBING DRAWINGS 01-22-2020



FOOTBALL STADIUM CHANGING ROOM, SEATINGS, CAFE', SHOP DRAWING INDEX

PROJECT CODE: COM-18

CLIENT: MINISTRY OF YOUTH, SPORTS & COMMUNITY EMPOWERMENT BUILDING: FOOTBALL STADIUM CHANGING ROOM, SEATINGS, CAFE', SHOP

DRAWING TITLE

_DN.CODE.	DISC.	NO.	PDF FILE NAME	PRIMARY	SECONDARY	SCALE	FORMAT	DATE
CON 10	AR	01	COM-18_SCF_AR01_A	DDAWING DEGISTED		NTS	A 2	0000 10000
COM-18				DRAWING REGISTER			A2	22ND JANUARY 2020
COM-18	AR	02	COM-18_SCF_AR02 _A	FLOOR PLAN, ROOF PLAN		1:100	A2	22ND JANUARY 2020
COM-18	AR	03	COM-18_SCF_AR03_A	ELEVATIONS		1:100	A2	22ND JANUARY 2020
COM-18	AR	04	COM-18_SCF_AR04_A	SECTIONS		1:100	A2	22ND JANUARY 2020
COM-18	AR	05	COM-18_SCF_AR05_A	DOOR & WINDOW SCHEDULES		1:50	A2	22ND JANUARY 2020
COM-18	ST	01	COM-18_SCF_ST01 _A	FOUNDATION, COLUMN, ROOF BEAM & SLAB PLAN		1:100	A2	22ND JANUARY 2020
COM-18	ST	02	COM-18_SCF_ST02 _A	CANVAS ROOF STRUCTURE PLAN		1:100	A2	22ND JANUARY 2020
COM-18	ST	03	COM-18_SCF_ST03 _A	STAIR DETAILS		1:50	A2	22ND JANUARY 2020
COM-18	ST	04	COM-18_SCF_ST04 _A	STRUCTURAL DETAILS		1:50, 1:20, 1:10	A2	22ND JANUARY 2020
COM-18	EL	01	COM-18_SCF_EL01 _A	ELECTRICAL LIGHTING, POWER SOCKETS & AC LAYOUT		1:100	A2	22ND JANUARY 2020
COM-18	PL	01	COM-18_SCF_PL01 _A	SEWAGE, FRESH WATER LINES LAYOUT		1:100	A2	22ND JANUARY 2020

MINISTRY OF YOUTH & SPORTS

DESIGN AND CONSULTANCY:



KEY PLAN:

This drawing shall not be used for construction unless certified.
Contractor to verify all dimensions of existing works on site before commencing any work or preparing shop drawings.
Do not scale drawings, use written dimensions only.
This drawing is to be read in conjunction with the specifications and conditions of contract.
This drawing and design is copyright and no portion may be reproduced without the permission of the Consultant

NO DESCRIPTION DATE

PROPOSED STADIUM SEATING, CHANGING ROOMS, SHOP, CAFE

CONCEPT DESIGNDESIGN DEVELOPMENTTENDER DOCUMENT


O FOR CONSTRUCTION \bigcirc AS BUILD DRAWINGS


DESIGNATION NAME SIGNATURE
PROJECT MANAGER MOHAMED SIRAJ
STR. ENGINEER AHMED ZUHAL
CHIEF ARCHITECT MOHAMED SHAMIN
CHECKED MOHAMED SIRAJ
DRAWN AHUSAN.A.MUHUSIN

DWG. NAME:

ARCHITECTURAL

DRAWING INDEX

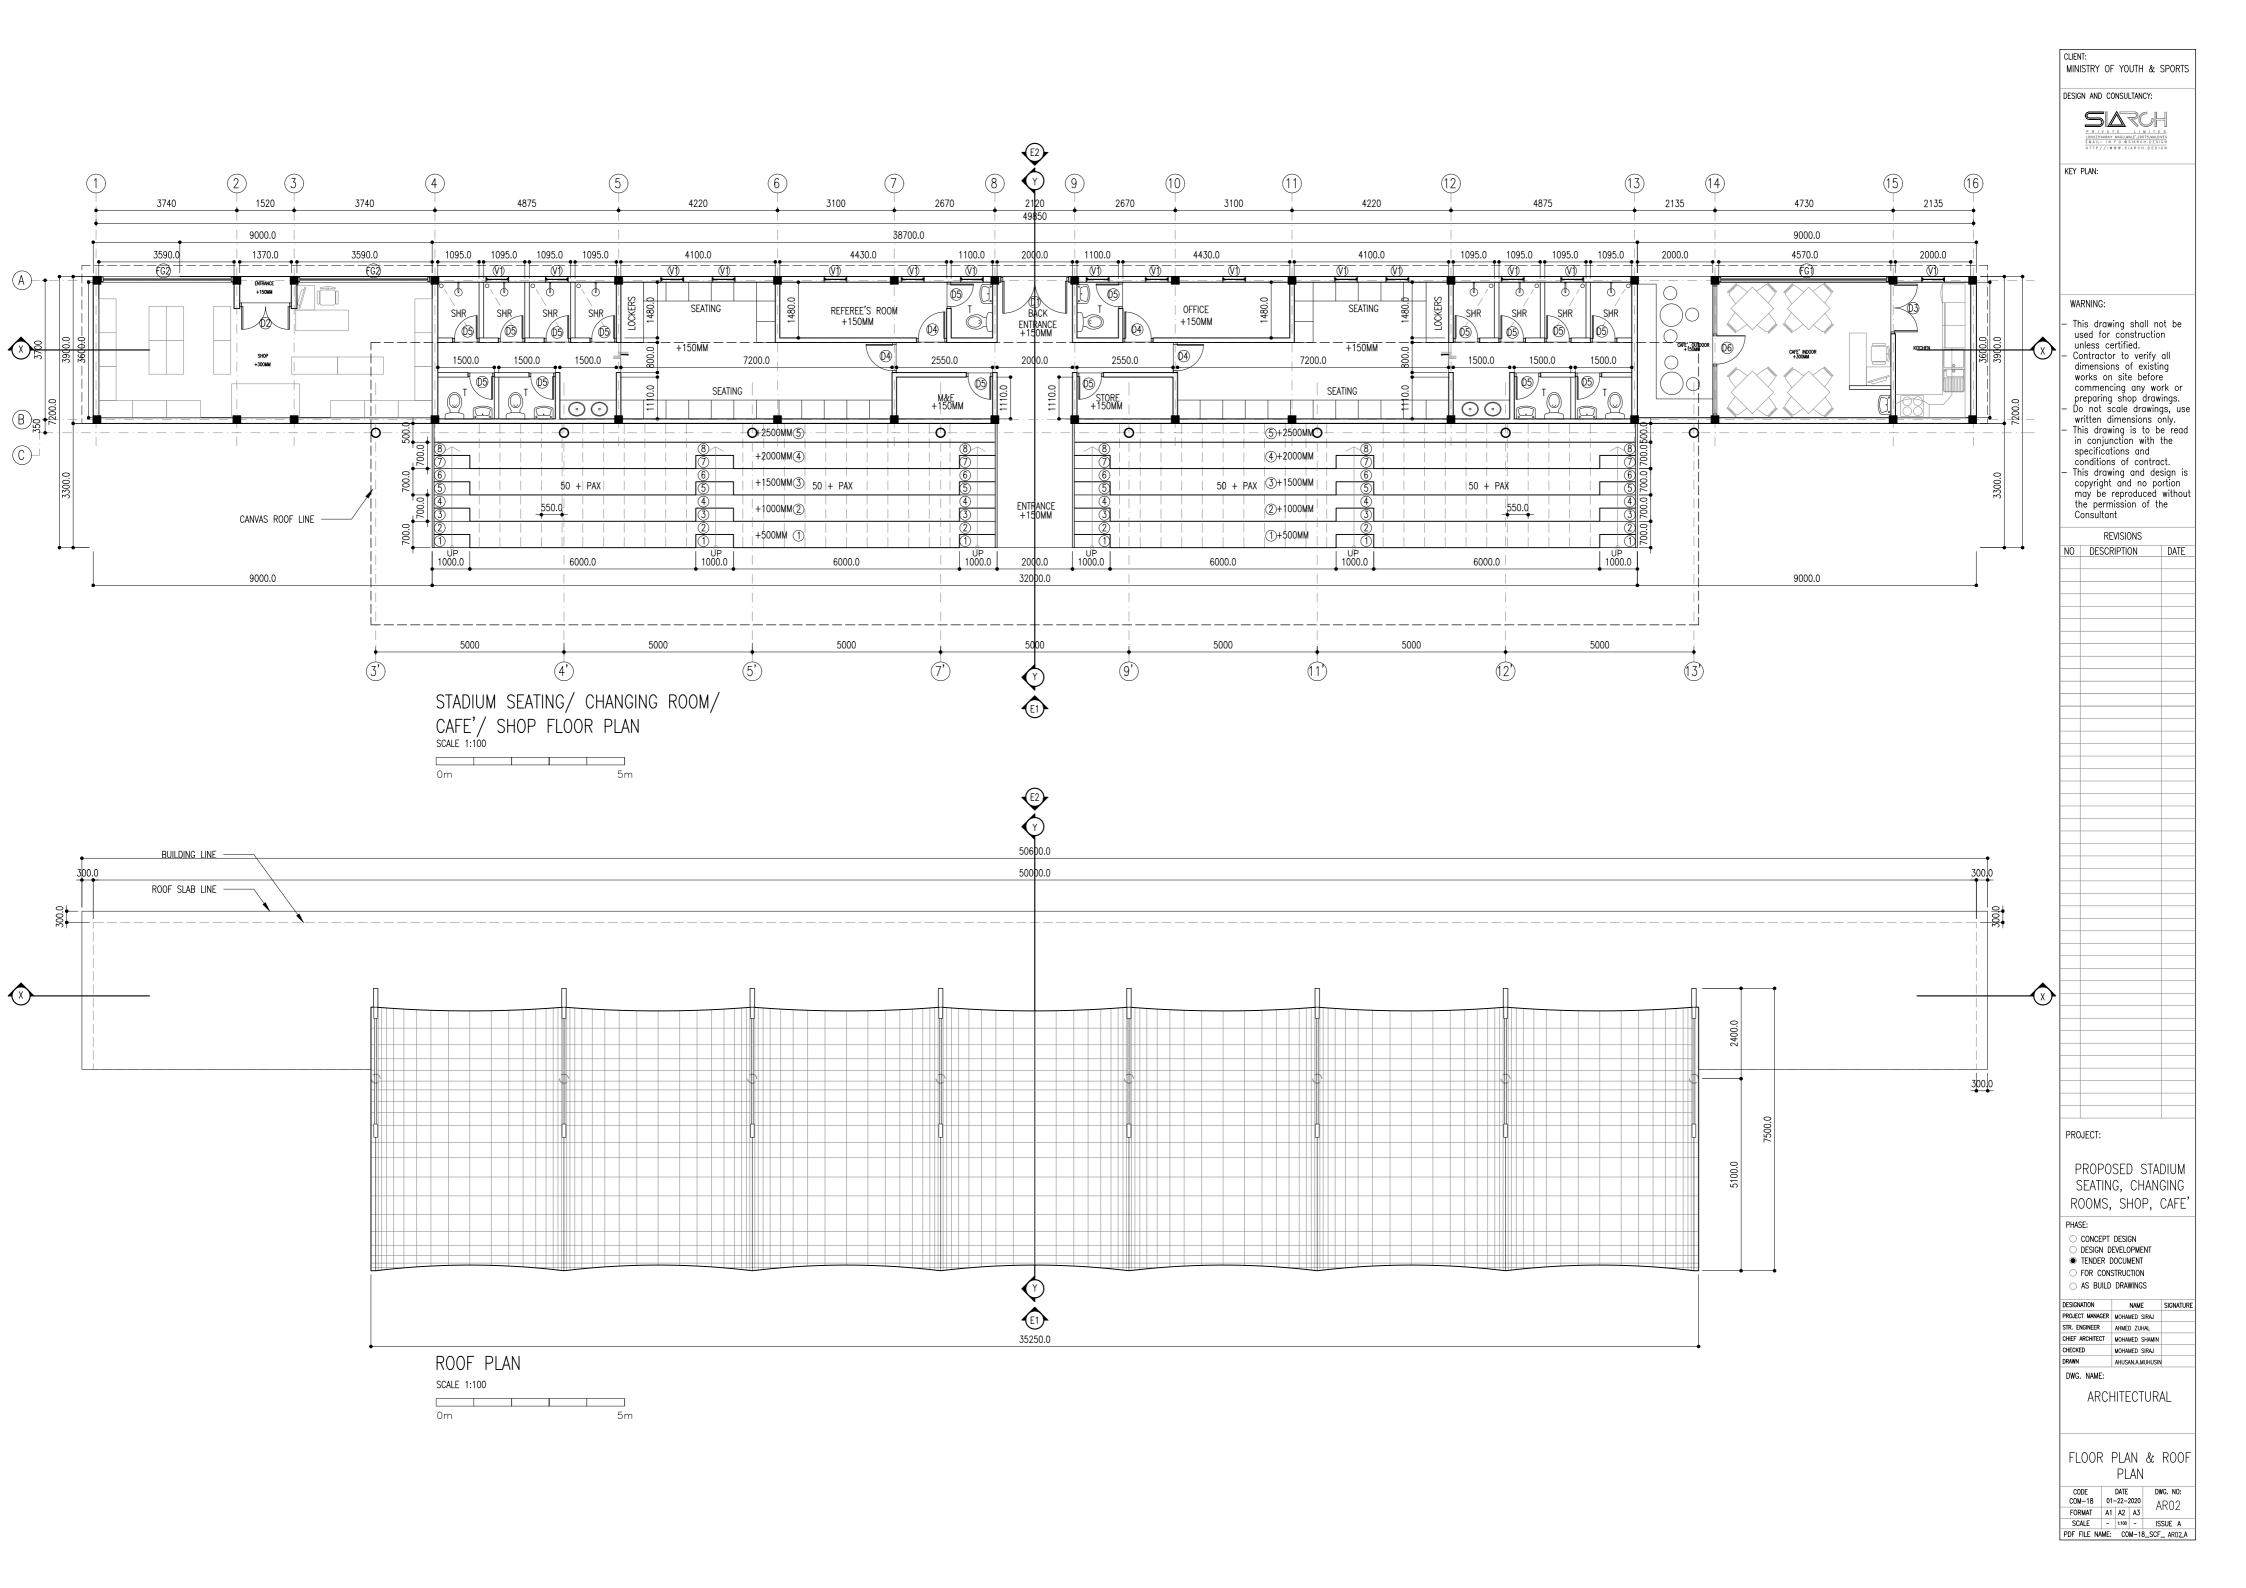

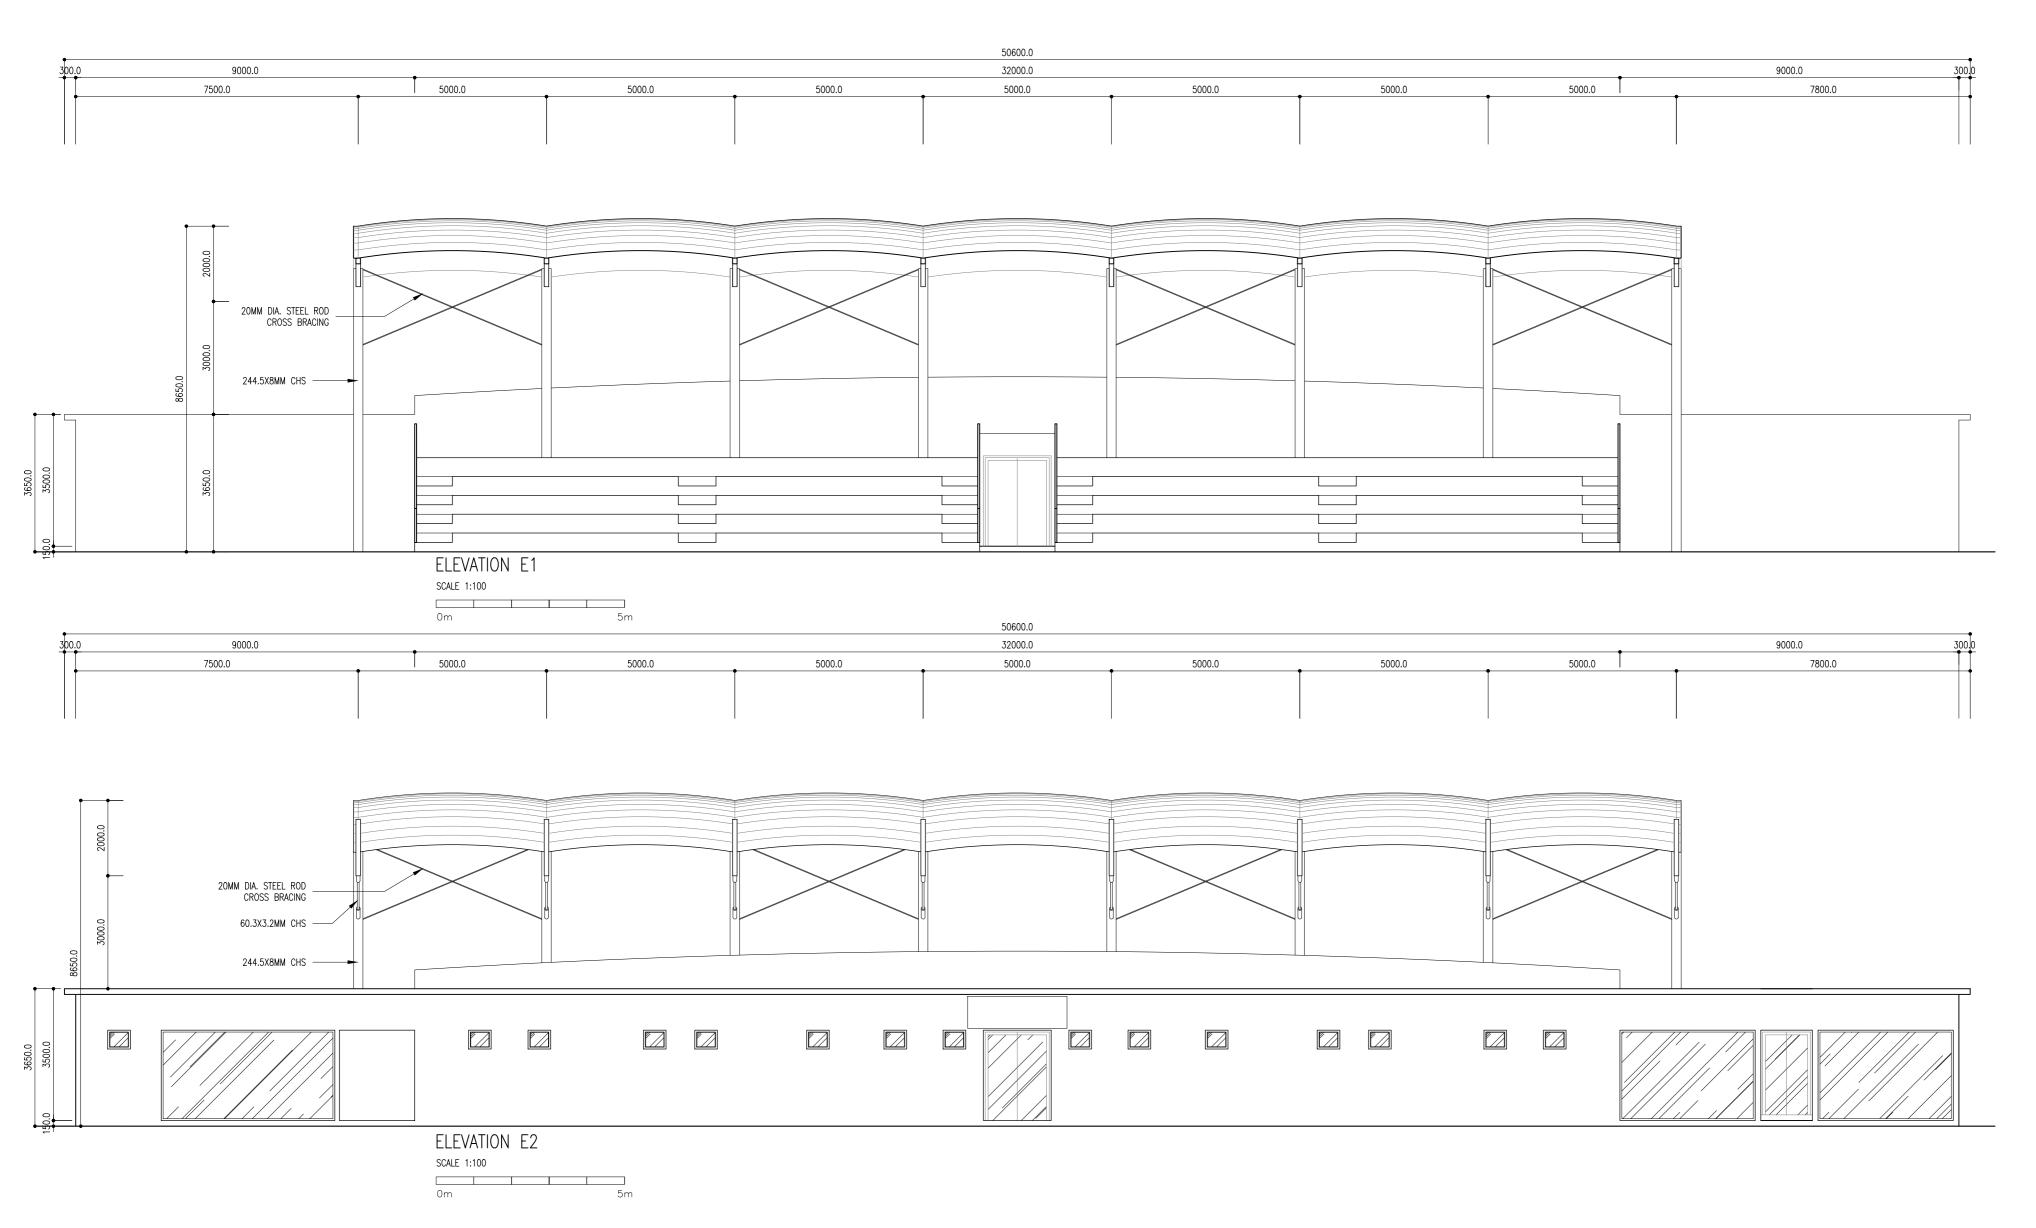

MINISTRY OF YOUTH & SPORTS

DESIGN AND CONSULTANCY:

SARCH

KEY PLAN:

WARNING:

WARKINIOG:

This drawing shall not be used for construction unless certified.
Contractor to verify all dimensions of existing works on site before commencing any work or preparing shop drawings.
Do not scale drawings, use written dimensions only.
This drawing is to be read in conjunction with the specifications and conditions of contract.
This drawing and design is copyright and no portion may be reproduced without the permission of the Consultant

NO	REVISIONS DESCRIPTION				
110	PESCIVII HOIN				
		_			
		_			
		_			
		_			
		_			
		_			
		+			
		+			
		+			
		- 1			

PROPOSED STADIUM SEATING, CHANGING ROOMS, SHOP, CAFE'

PHASE:

CONCEPT DESIGN
DESIGN DEVELOPMENT
TENDER DOCUMENT FOR CONSTRUCTION


 \bigcirc AS BUILD DRAWINGS DESIGNATION NAME SIGNATURE
PROJECT MANAGER MOHAMED SIRAJ
STR. ENGINEER AHMED ZUHAL
CHIEF ARCHITECT MOHAMED SHAMIN
CHECKED MOHAMED SIRAJ
DRAWN AHMSAN.AMUHUSIN
DWC. NAME:

DWG. NAME:


ARCHITECTURAL

ELEVATIONS

CODE DATE DWG. NO:
COM-18 01-22-2020 ARO 3
FORMAT A1 A2 A3
SCALE - 1:100 - ISSUE A
PDF FILE NAME: COM-18_SCF_ ARO 3.4

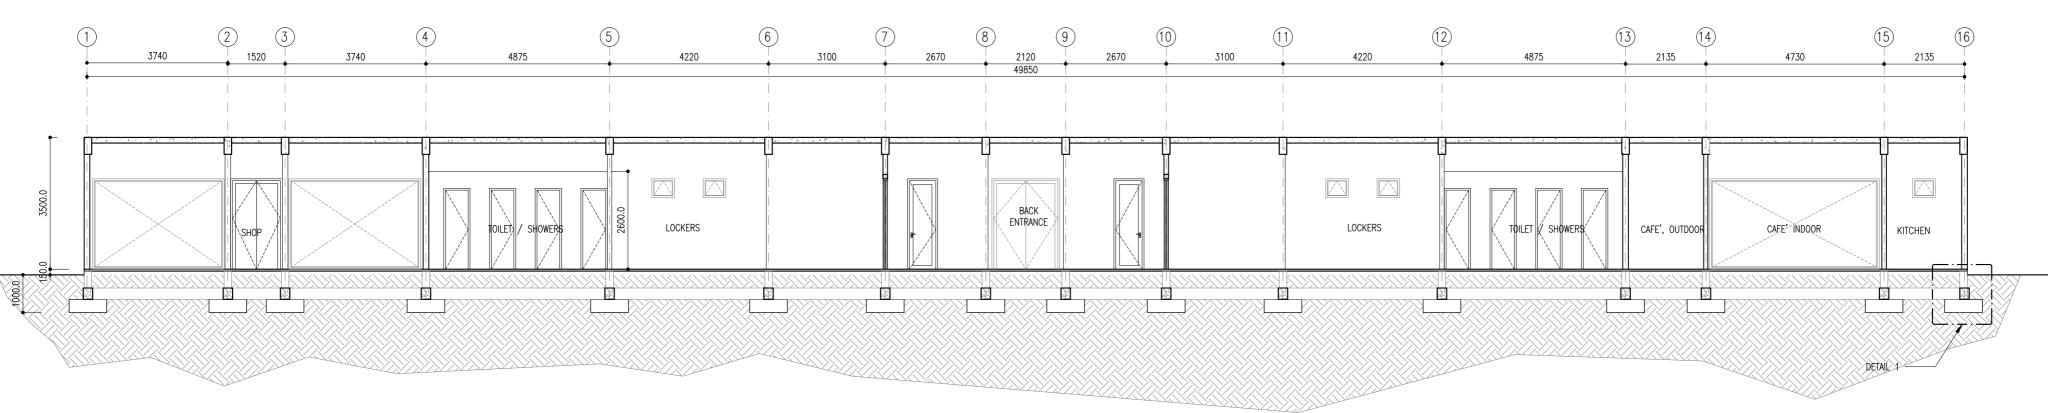

SECTION X-X SCALE 1:100 5m

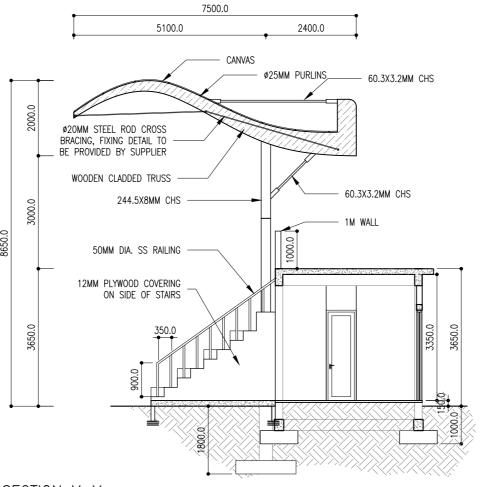

SECTION Y-Y SCALE 1:100

MINISTRY OF YOUTH & SPORTS

DESIGN AND CONSULTANCY:

SARCH

KEY PLAN:

WARNING:

This drawing shall not be used for construction unless certified.
Contractor to verify all dimensions of existing works on site before commencing any work or preparing shop drawings.
Do not scale drawings, use written dimensions only.
This drawing is to be read in conjunction with the specifications and conditions of contract.
This drawing and design is copyright and no portion may be reproduced without the permission of the Consultant

REVISIONS NO DESCRIPTION DATE



PROJECT:

PROPOSED STADIUM SEATING, CHANGING ROOMS, SHOP, CAFE

PHASE:

○ CONCEPT DESIGN○ DESIGN DEVELOPMENT● TENDER DOCUMENT

 FOR CONSTRUCTION \bigcirc AS BUILD DRAWINGS

DESIGNATION NAME SIGNATURE
PROJECT MANAGER MOHAMED SIRAJ
STR. ENGINEER A-MMED ZUHAL
CHIEF ARCHITECT MOHAMED SHAMIN
CHECKED MOHAMED SIRAJ
DRAWN A-HUSANLA-MUHUSIN

DWG. NAME:

ARCHITECTURAL


SECTIONS

CODE DATE DWG. NO:
COM-18 01-22-2020 ARO 4

FORMAT A1 A2 A3

SCALE - 1000 - ISSUE A

PDF FILE NAME: COM-18_SCF_ ARO4.A

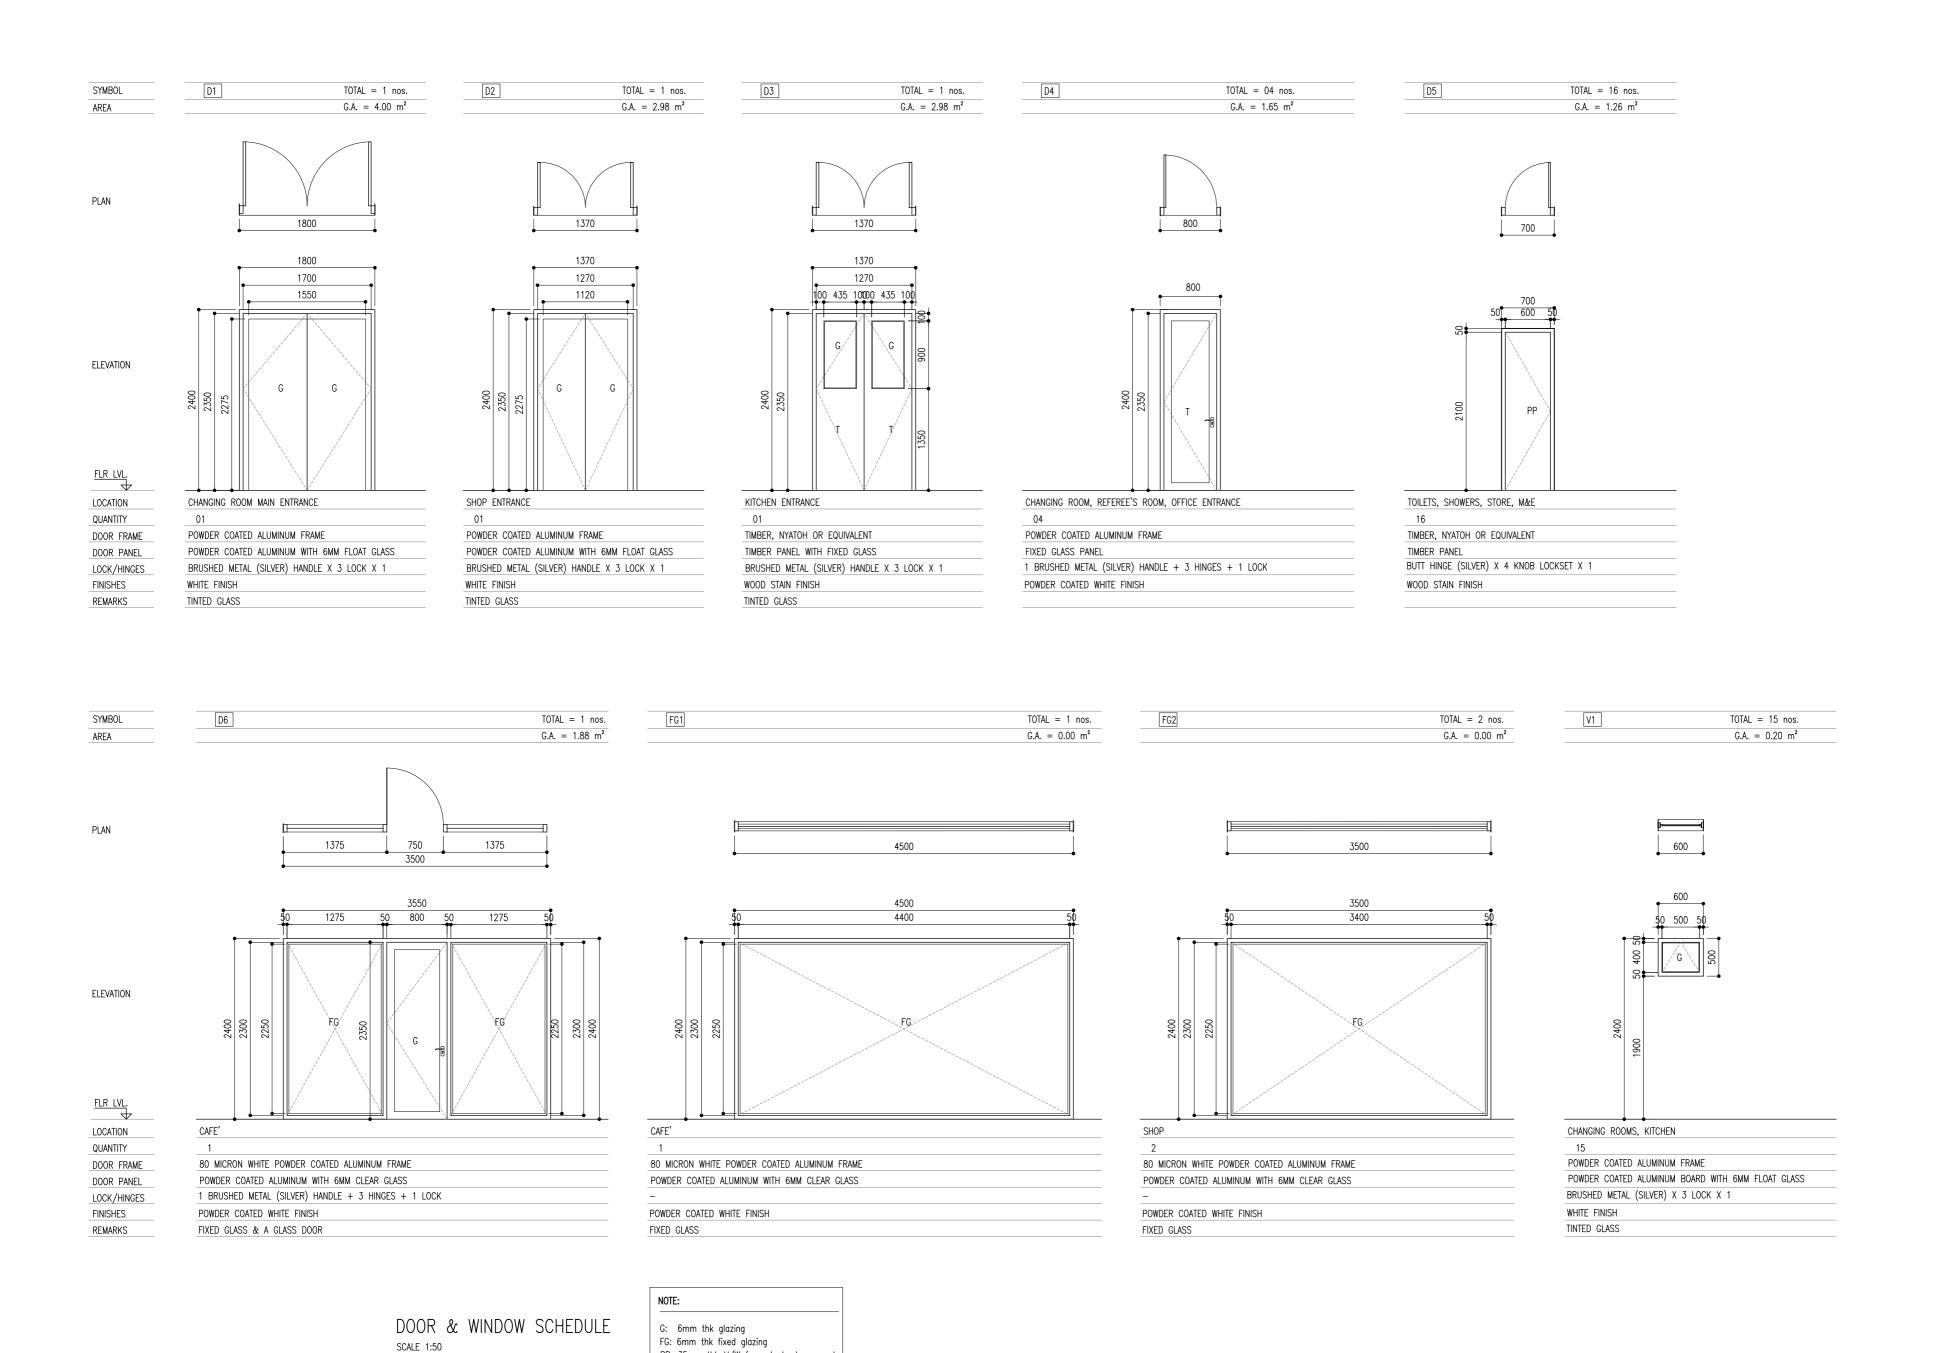

PP: 35mm thk H/W framed ply door panel

MINISTRY OF YOUTH & SPORTS

DESIGN AND CONSULTANCY:



KEY PLAN:

WARNING:

 This drawing shall not be used for construction unless certified.
 Contractor to verify all dimensions of existing works on site before works on site before commencing any work or preparing shop drawings.

Do not scale drawings, use written dimensions only.

This drawing is to be read in conjunction with the specifications and conditions of contract

conditions of contract. This drawing and design is copyright and no portion may be reproduced without the permission of the Consultant

REVISIONS NO DESCRIPTION DATE

PROJECT:

PROPOSED STADIUM SEATING, CHANGING ROOMS, SHOP, CAFE

PHASE:

CONCEPT DESIGNDESIGN DEVELOPMENT● TENDER DOCUMENT

O FOR CONSTRUCTION AS BUILD DRAWINGS


DESIGNATION NAME SIGNATURE
PROJECT MANAGER MOHAMED SIRAJ
STR. ENGINEER AHMED ZUHAL
CHIEF ARCHITECT MOHAMED SHAMIN
CHECKED MOHAMED SIRAJ
DRAWN AHUSAN.A.MUHUSIN


DWG. NAME:

ARCHITECTURAL

DOOR & WINDOW SCHEDULE

CODE | DATE | DWG. NO: COM-18 | 01-22-2020 | ARO5 |
FORMAT | A1 | A2 | A3 |
SCALE | - | 150 | - | ISSUE A |
PDF FILE NAME: COM-18_SCF_ARO5_A

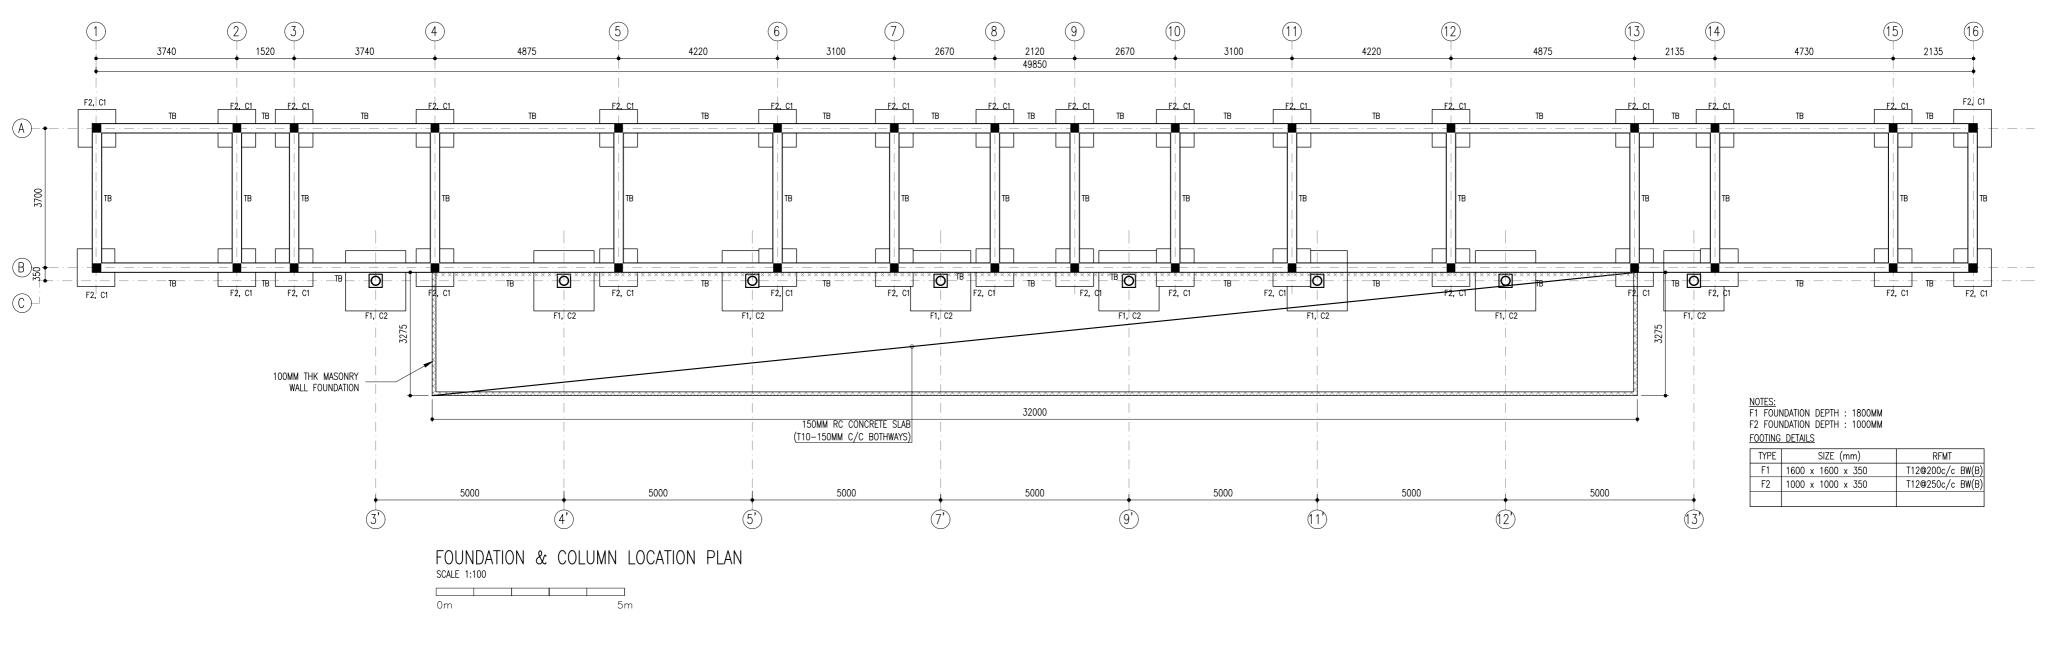

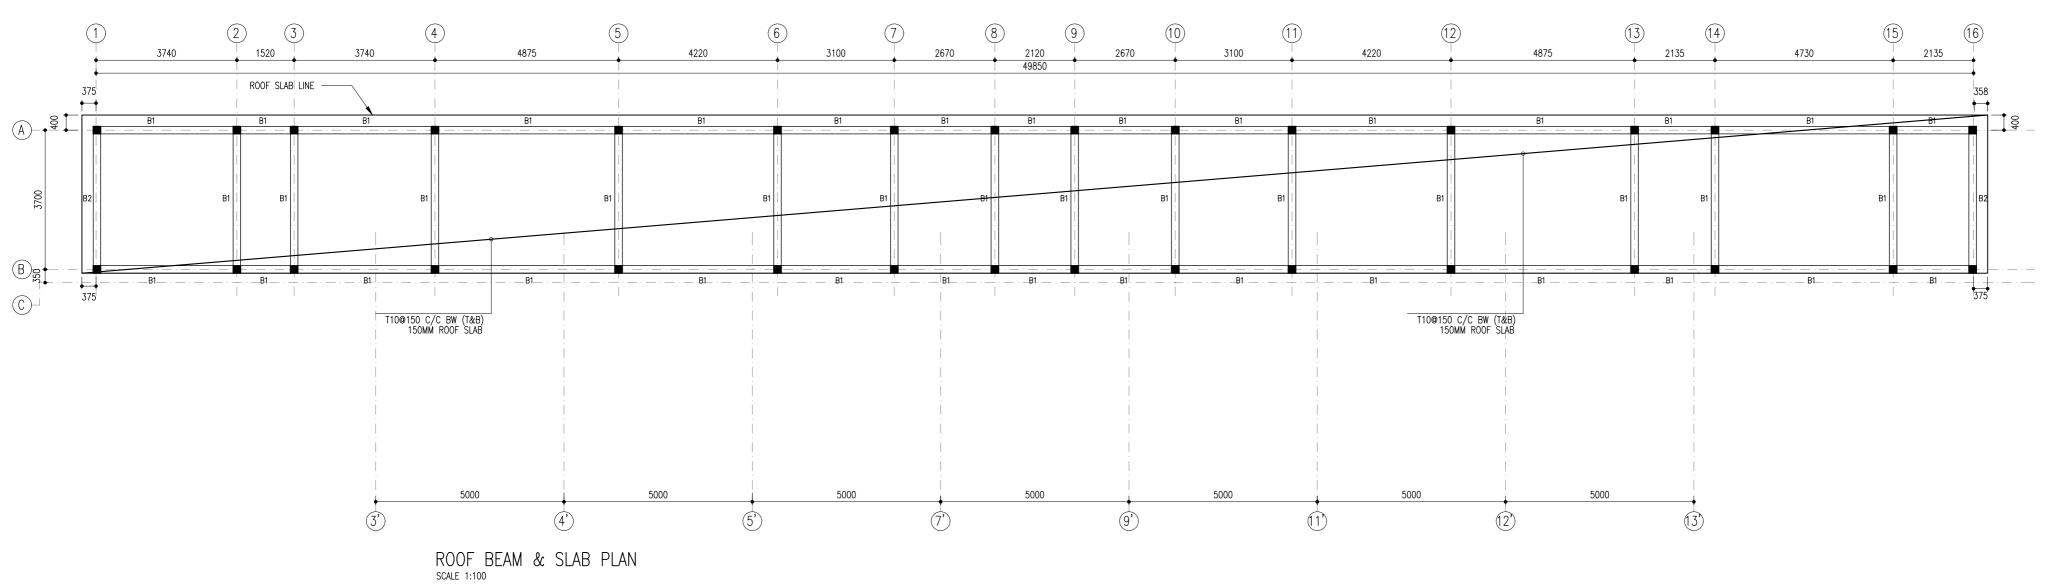

MINISTRY OF YOUTH & SPORTS

DESIGN AND CONSULTANCY:

SARCH

KEY PLAN:

WARNING:

This drawing shall not be used for construction unless certified.
Contractor to verify all dimensions of existing works on site before works on site before commencing any work or preparing shop drawings.

Do not scale drawings, use written dimensions only.

This drawing is to be read in conjunction with the specifications and conditions of contract.

This drawing and design is copyright and no portion may be reproduced without the permission of the Consultant

REVISIONS

NO DESCRIPTION DATE PROJECT:

PROPOSED STADIUM

SEATING, CHANGING ROOMS, SHOP, CAFE

PHASE:

CONCEPT DESIGNDESIGN DEVELOPMENT TENDER DOCUMENT


O FOR CONSTRUCTION AS BUILD DRAWINGS

DESIGNATION NAME SIGNATURE
PROJECT MANAGER MOHAMED SIRAJ
STR. ENGINEER AHMED ZUHAL
CHIEF ARCHITECT MOHAMED SHAMIN
CHECKED MOHAMED SIRAJ
DRAWN AHUSAN.A.MUHUSIN

DWG. NAME: STRUCTURAL

FOUNDATION, COLUMN, ROOF BEAM

& SLAB PLAN CODE | DATE | DWG. NO: COM-18 | 01-22-2020 | STO 1 |
FORMAT | A1 | A2 | A3 |
SCALE | - 1*100 | ISSUE A |
PDF FILE NAME: COM-18_SCF_ST01_A

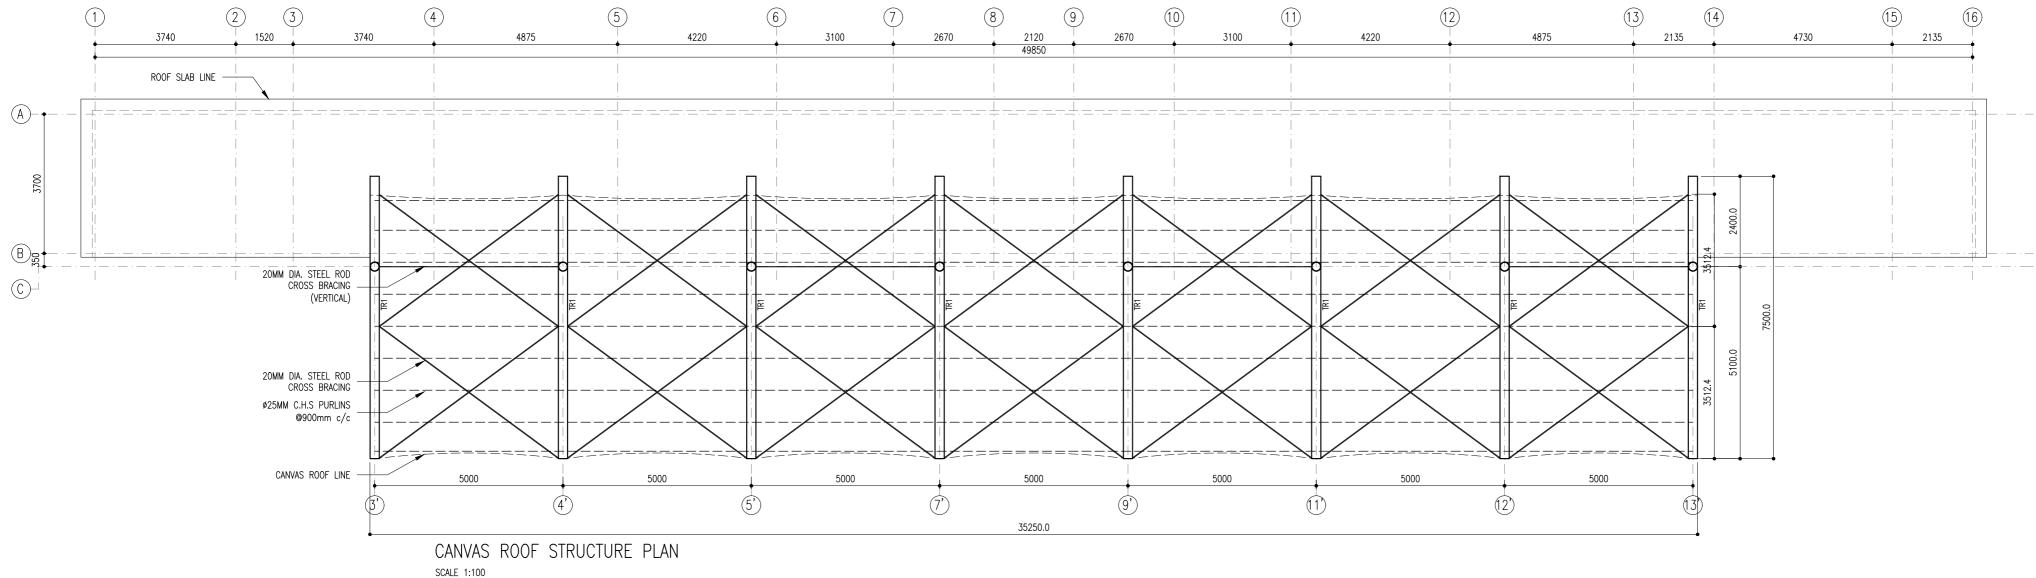

CLIENT:
MINISTRY OF YOUTH & SPORTS

DESIGN AND CONSULTANCY:



KEY PLAN:

WARNING:

This drawing shall not be used for construction unless certified.
Contractor to verify all dimensions of existing works on site before commencing any work or preparing shop drawings.
Do not scale drawings, use written dimensions only.
This drawing is to be read in conjunction with the specifications and conditions of contract.
This drawing and design is copyright and no portion may be reproduced without the permission of the Consultant

REVISIONS			
NO	DESCRIPTION	DATE	
_			

PROPOSED STADIUM SEATING, CHANGING ROOMS, SHOP, CAFE

PHASE:

CONCEPT DESIGN
DESIGN DEVELOPMENT
TENDER DOCUMENT
FOR CONSTRUCTION

 \bigcirc AS BUILD DRAWINGS


DESIGNATION NAME SIGNATURE
PROJECT MANAGER MOHAMED SIRAJ
STR. ENGINEER AHMED ZUHAL
CHIEF ARCHITECT MOHAMED SHAMIN
CHECKED MOHAMED SIRAJ
DRAWN AHUSANA.MUHUSIN

DWG. NAME:

STRUCTURAL

CANVAS ROOF STRUCTURE PLAN

CODE DATE DWG. NO:
COM-18 01-22-2020
FORMAT A1 A2 A3
SCALE - 1:100 - ISSUE A
PDF FILE NAME: COM-18_SCF_ST02_A

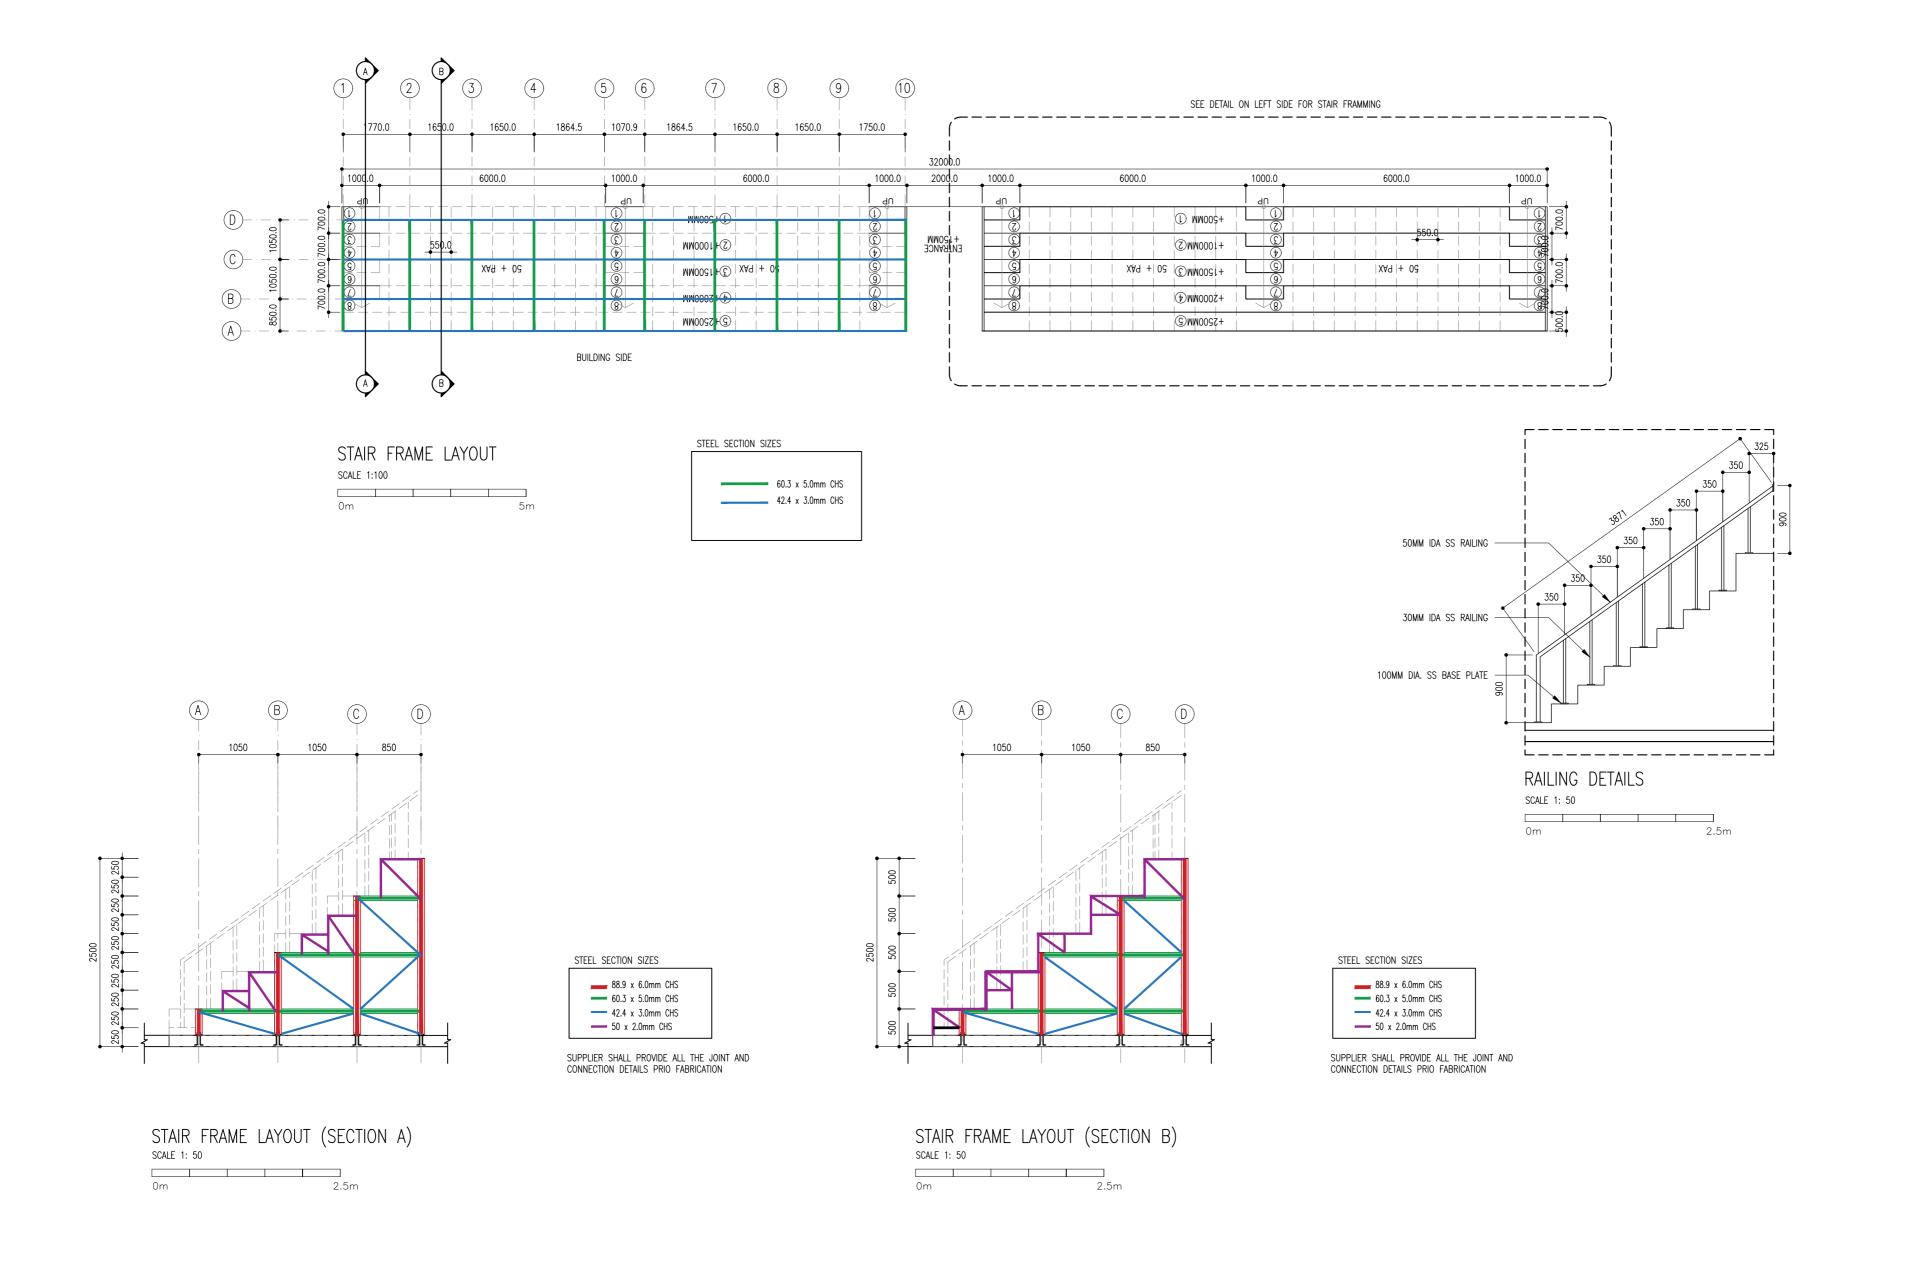

CLIENT:
MINISTRY OF YOUTH & SPORTS

DESIGN AND CONSULTANCY:



KEY PLAN:

WARNING:


This drawing shall not be used for construction unless certified.
 Contractor to verify all dimensions of existing works on site before commencing any work or preparing shop drawings.
 Do not scale drawings, use written dimensions only.
 This drawing is to be read in conjunction with the specifications and conditions of contract.

in conjunction with the specifications and conditions of contract.

This drawing and design is copyright and no portion may be reproduced without the permission of the Consultant

REVISIONS

NO DESCRIPTION DATE

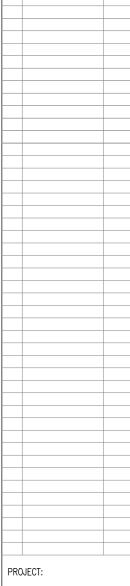

PROPOSED STADIUM SEATING, CHANGING ROOMS, SHOP, CAFE'

PHASE:

CONCEPT DESIGN
 DESIGN DEVELOPMENT
 TENDER DOCUMENT

FOR CONSTRUCTION
AS BUILD DRAWINGS


DESIGNATION NAME SIGNATURE
PROJECT MANAGER MOHAMED SIRAJ
STR. ENGINEER AHMED ZUHAL
CHIEF ARCHITECT MOHAMED SHAMIN
CHECKED MOHAMED SIRAJ
DRAWN AHUSAN.A.MUHUSIN

DWG. NAME:

STRUCTURAL

STAIR DETAILS

CODE DATE DWG. NO:
COM-18 01-22-2020
FORMAT A1 A2 A3
SCALE - 1:50 - ISSUE A
PDF FILE NAME: COM-18_SCF_STO3_A

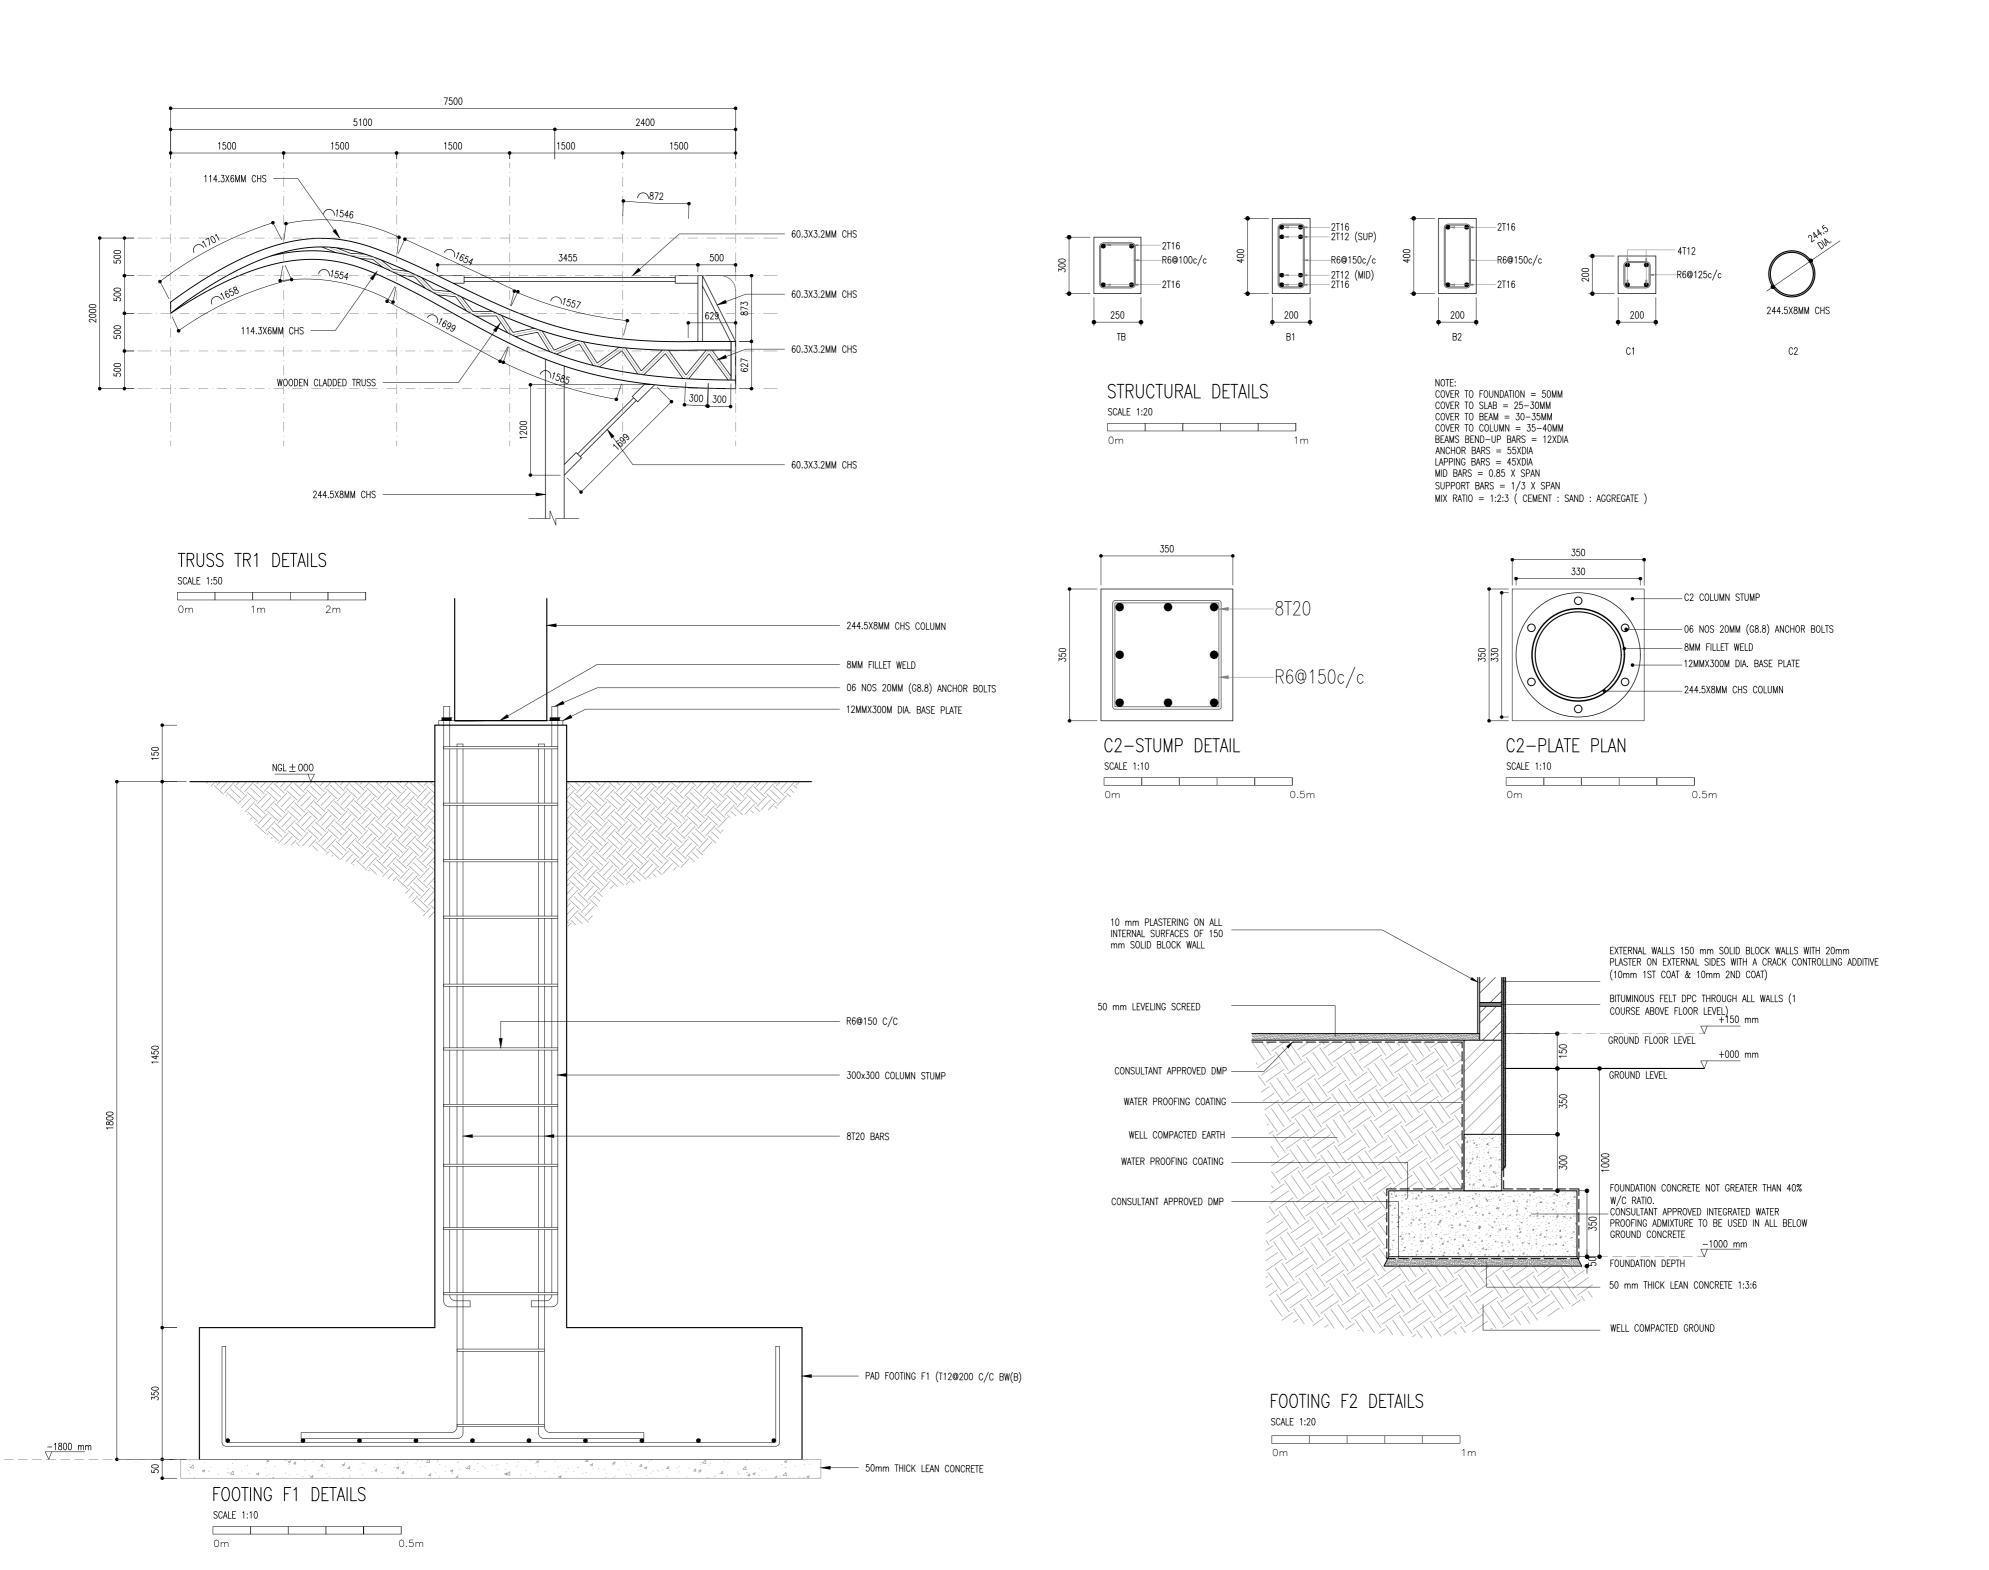

MINISTRY OF YOUTH & SPORTS

DESIGN AND CONSULTANCY:

SARCH

KEY PLAN:

WARNING:

This drawing shall not be used for construction unless certified. Contractor to verify all dimensions of existing works on site before commencing any work or preparing shop drawings. Do not scale drawings, use written dimensions only. This drawing is to be read in conjunction with the specifications and conditions of contract. This drawing and design is

REVISIONS

may be reproduced without the permission of the Consultant

copyright and no portion

NO DESCRIPTION DATE PROJECT:

PROPOSED STADIUM SEATING, CHANGING ROOMS, SHOP, CAFE

PHASE:

CONCEPT DESIGNDESIGN DEVELOPMENT TENDER DOCUMENT


O FOR CONSTRUCTION \bigcirc AS BUILD DRAWINGS

DESIGNATION NAME SIGNATURE PROJECT MANAGER MOHAMED SIRAJ STR. ENGINEER AHMED ZUHAL CHIEF ARCHITECT MOHAMED SHAMIN CHECKED MOHAMED SIRAJ
DRAWN AHUSAN.A.MUHUSII AHUSAN.A.MUHUSIN

DWG. NAME:

STRUCTURAL

STRUCTURAL DETAILS

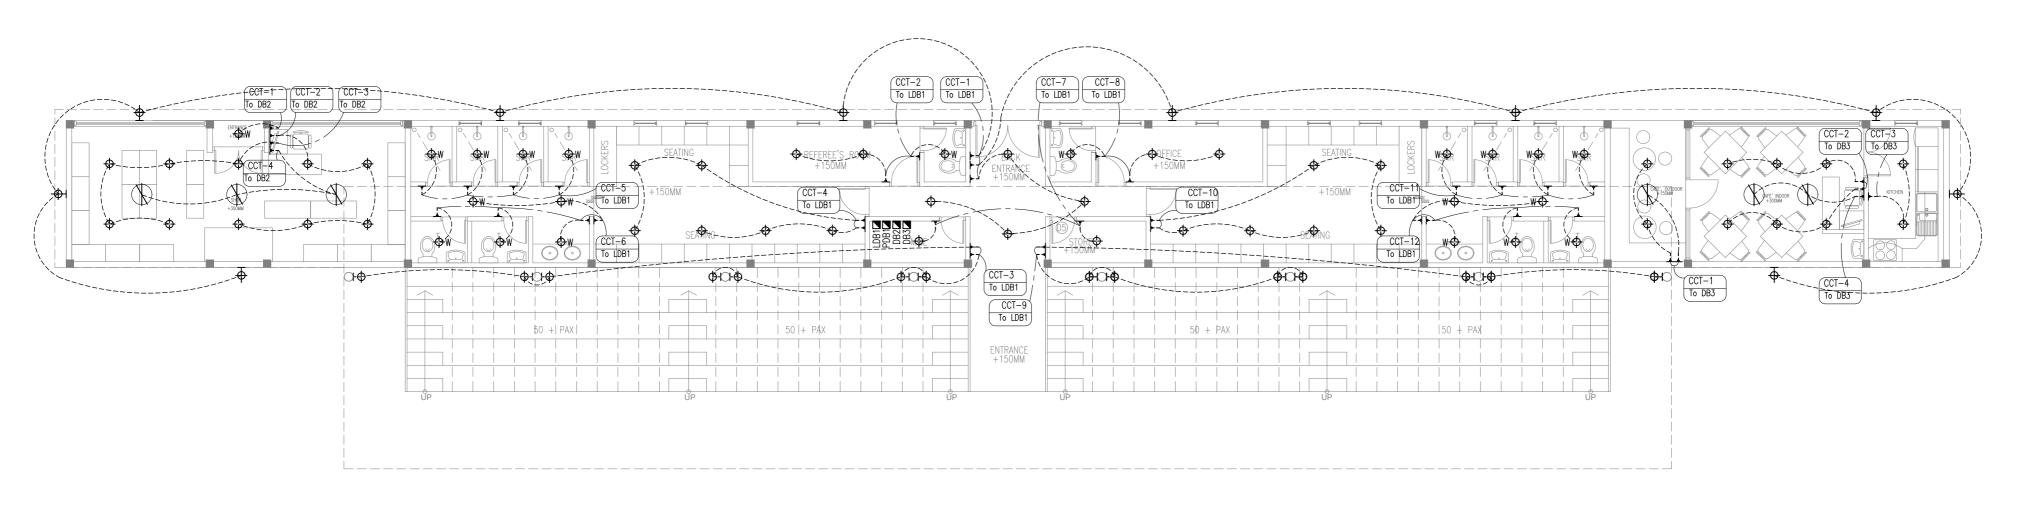

ELECTRICAL LIGHTING LAYOUT SCALE 1:100

CEILING LIGHT W WEATHERPROOF ►- ONE-WAY SWITCH /FAN CONTROL CEILING FAN DOOR PHONE MAINS **├**� SPOT LIGHT ₩EATHER PROOF OUTDOOR LIGHT 🔯 EXHAUST FAN AC | WALL SOCKET 15A (AIR-CON) ■ D-BOARD ▶ WALL SOCKET 13A (LOW LVL)

► WALL SOCKET 13A (HIGH LVL) ▶+ WALL SOCKET 15A (LOW LVL)


H← TELEPHONE/NETWORK SOCKET AC INDOOR UNIT

DA DOOR ACCESS PANEL --- STRIP LIGHT

O FLOOR LIGHT

LEGEND

THE DRAWINGS ARE SCHEMATIC. DETAILED SYSTEMS DESIGN AND CONDUITING SHALL BE DONE BY CONTRACTOR AND SUBMITTED FOR APPROVAL BEFORE INSTALLATION.

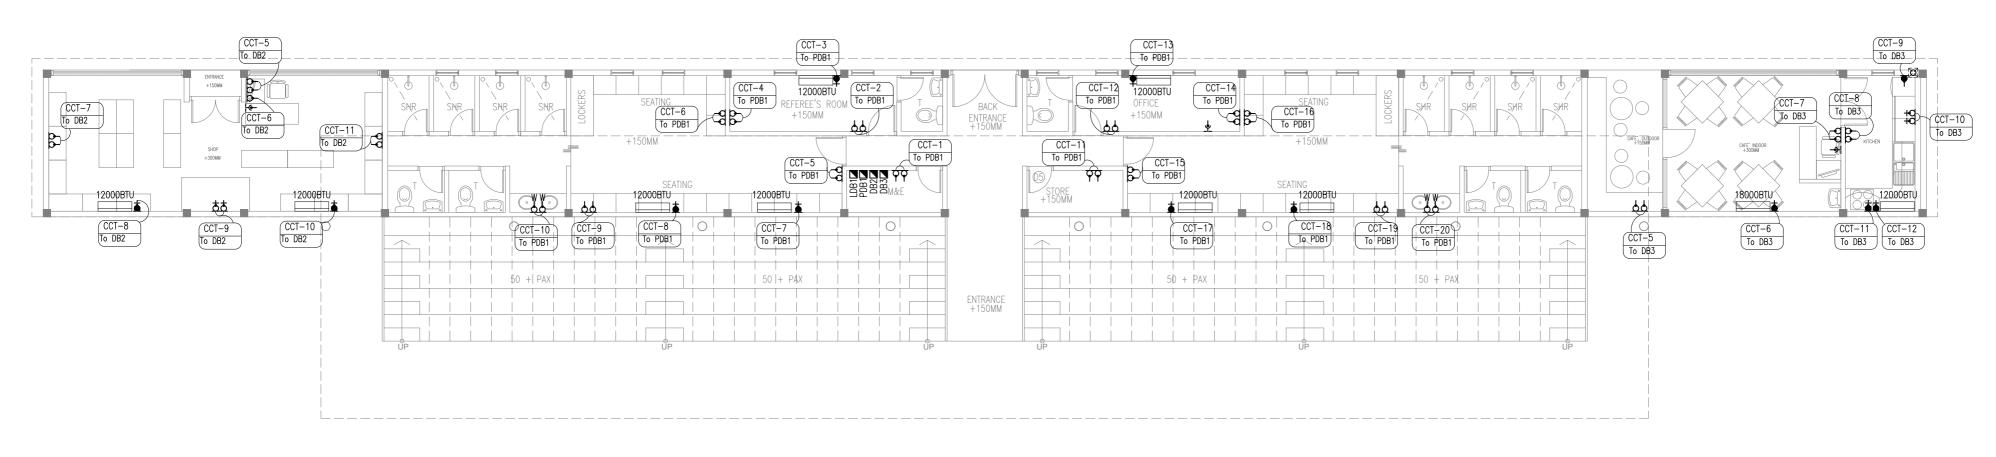

POWER SOCKETS & AC LAYOUT

SCALE 1:100

MINISTRY OF YOUTH & SPORTS

DESIGN AND CONSULTANCY: SARCH

KEY PLAN:

WARNING:

This drawing shall not be used for construction unless certified. Contractor to verify all dimensions of existing works on site before works on site before commencing any work or preparing shop drawings. Do not scale drawings, use written dimensions only.

This drawing is to be read in conjunction with the specifications and conditions of contract. This drawing and design is copyright and no portion may be reproduced without the permission of the Consultant

REVISIONS NO DESCRIPTION DATE

PROJECT:

PROPOSED STADIUM SEATING, CHANGING ROOMS, SHOP, CAFE

PHASE:

CONCEPT DESIGNDESIGN DEVELOPMENT TENDER DOCUMENT O FOR CONSTRUCTION


O AS BUILD DRAWINGS DESIGNATION NAME SIGNATURE
PROJECT MANAGER MOHAMED SIRAJ

STR. ENGINEER AHMED ZUHAL
CHIEF ARCHITECT MOHAMED SHAMIN
CHECKED MOHAMED SIRAJ
DRAWN AHUSAN.A.MUHUSIN

DWG. NAME: ELECTRICAL

ELECTRICAL LIGHTING, POWER SOCKETS & AC LAYOUT

CODE DATE DWG. NO:
COM-18 01-22-2020 ELO 1
FORMAT A1 A2 A3
SCALE - 1:100 - ISSUE A
PDF FILE NAME: COM-18_SCF_ELO1_A

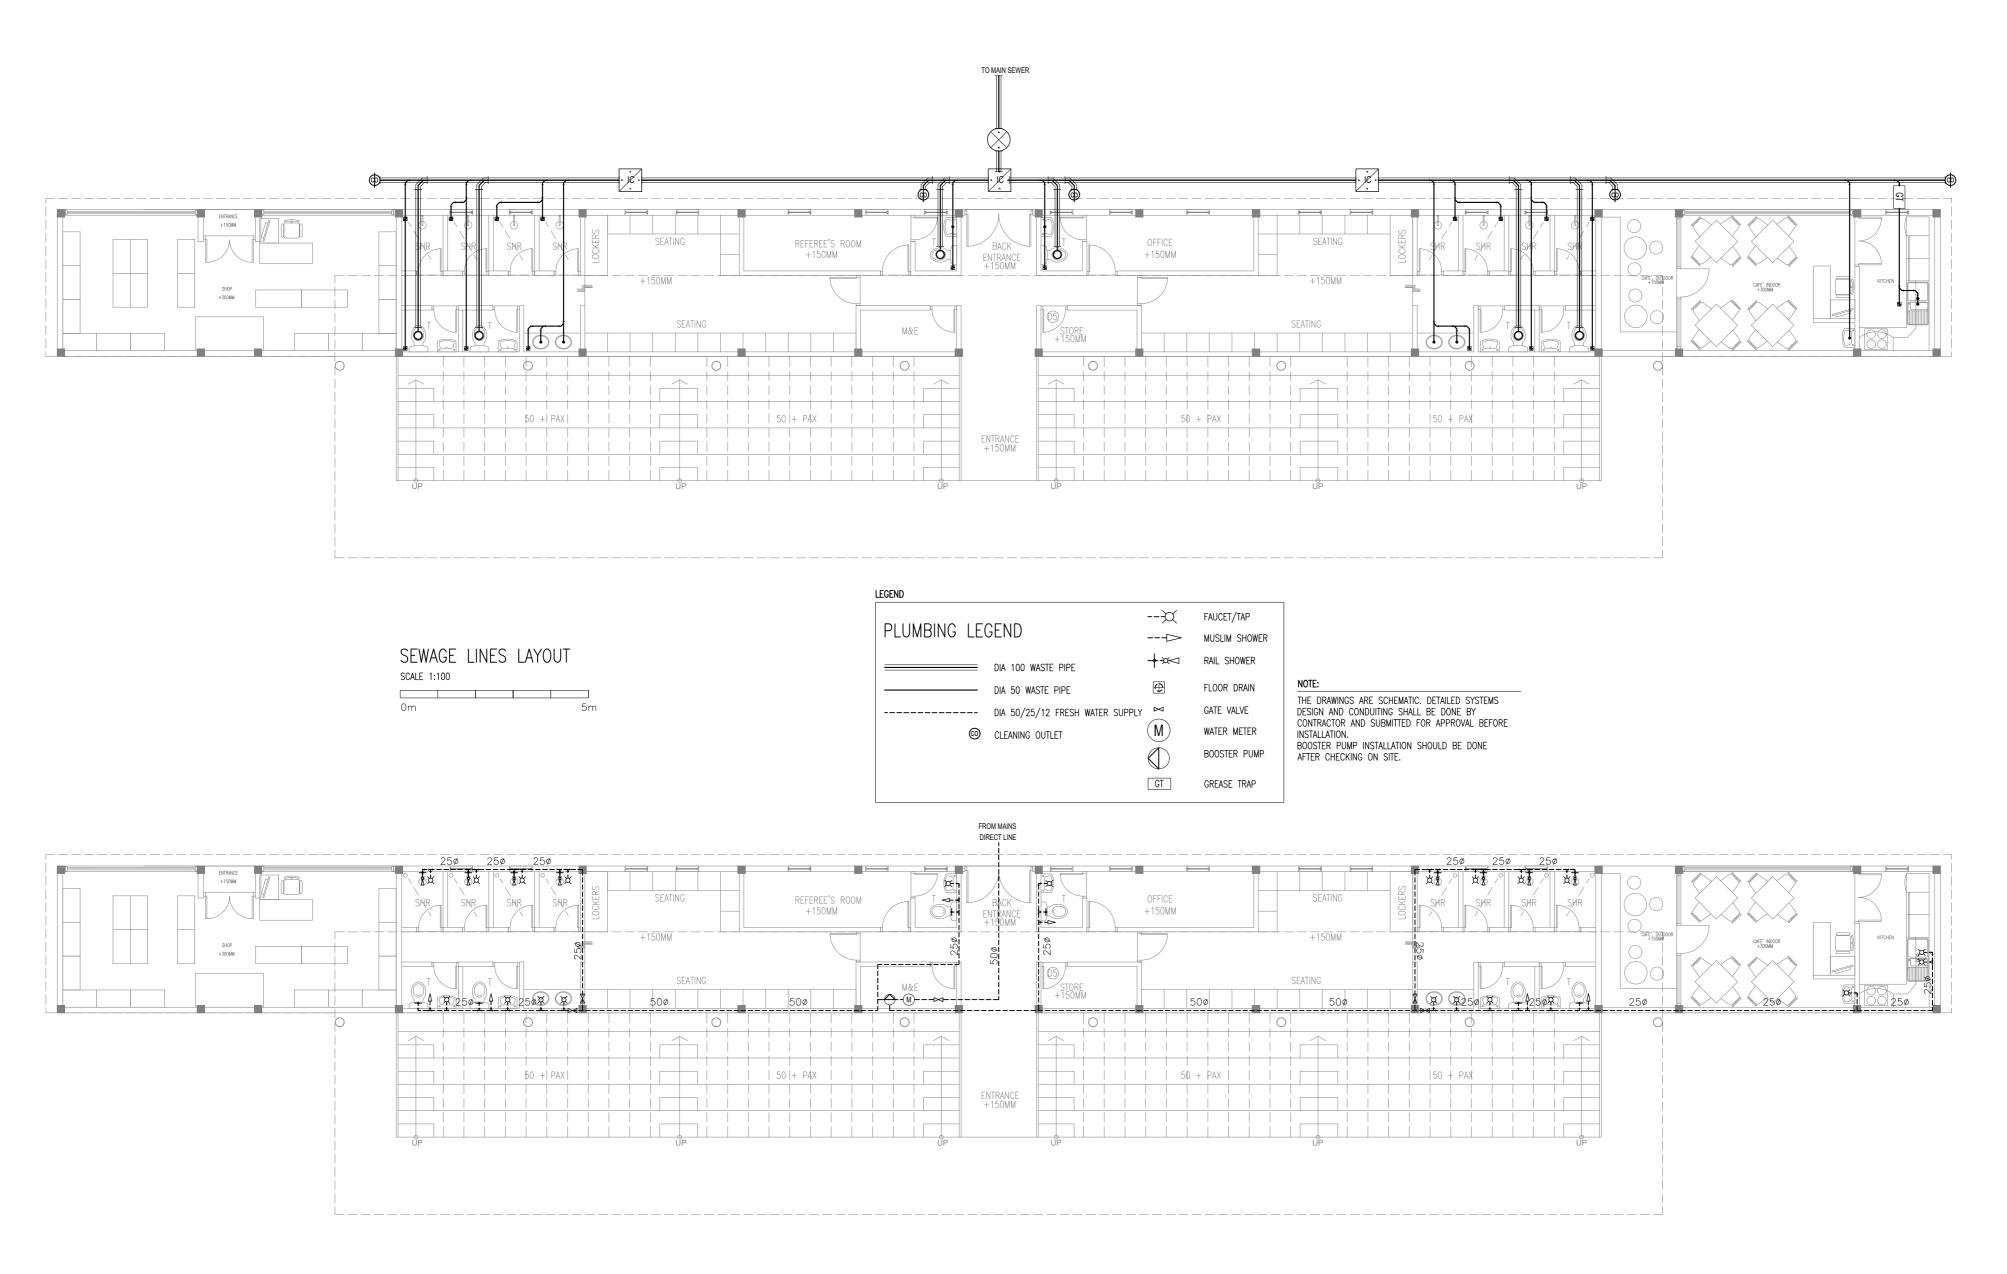

FRESH WATER LINES LAYOUT

SCALE 1:100

MINISTRY OF YOUTH & SPORTS

DESIGN AND CONSULTANCY:

SARCH

KEY PLAN:

WARNING:

This drawing shall not be used for construction unless certified. Contractor to verify all dimensions of existing works on site before works on site before commencing any work or preparing shop drawings. Do not scale drawings, use written dimensions only.

This drawing is to be read in conjunction with the specifications and conditions of contract. This drawing and design is copyright and no portion may be reproduced without the permission of the Consultant

REVISIONS NO DESCRIPTION DATE

PROJECT:

PROPOSED STADIUM SEATING, CHANGING ROOMS, SHOP, CAFE

PHASE:

CONCEPT DESIGNDESIGN DEVELOPMENT TENDER DOCUMENT O FOR CONSTRUCTION

AS BUILD DRAWINGS

DESIGNATION NAME SIGNATURE
PROJECT MANAGER MOHAMED SIRAJ
STR. ENGINEER A-MMED ZUHAL
CHIEF ARCHITECT MOHAMED SHAMIN
CHECKED MOHAMED SIRAJ
DRAWN A-HUSANLA-MUHUSIN

DWG. NAME: PLUMBING

SEWAGE LINES & FRESH WATER LINES LAYOUT

CODE DATE DWG. NO:
COM-18 01-22-2020 PLO1
FORMAT A1 A2 A3
SCALE - 1:100 - ISSUE A
PDF FILE NAME: COM-18_SCF_PLO1A