BADMINGTON COURT (3 COURTS) ARCHITECTURAL AND STRUCTURAL DRAWING 2022.03.03



PROPOSED BADMINGTON COURT (3 COURTS) DRAWING INDEX

PROJECT CODE: COM66

CLIENT: YOUTH MINISTRY

BUILDING: BOALHAGE

BUILDING CODE: BLG

DWG FILE NAME: COM-66_BLG

DRAWING TITLE

BLDG.CODE.	DISC.	NO.	FILE NAME.(DWG)	PRIMARY	SECONDARY	SCALE	FORMAT	DATE
HSC	AR	00	RSD-190-HSC-AR00_A	DRAWING INDEX		_	A3	3RD MARCH 2022
HSC	AR	01	RSD-190-HSC-AR01_A	GENERAL NOTE		=	A3	3RD MARCH 2022
HSC	AR	02	RSD-190-HSC-AR02_A	BADMINGTON COURT PLAN VIEW (2 COURTS)		1:100	A2	3RD MARCH 2022
HSC	AR	03	RSD-190-HSC-AR03_A	RETRACTABLE SEATINGS LAYOUT		1:100	A2	3RD MARCH 2022
HSC	AR	04	RSD-190-HSC-AR04_A	ROOF PLAN		1:100	A2	3RD MARCH 2022
HSC	AR	05	RSD-190-HSC-AR05_A	SECTION X-X		1:100	A3	3RD MARCH 2022
HSC	AR	06	RSD-190-HSC-AR06_A	ELEVATION - E1		1:100	A3	3RD MARCH 2022
HSC	AR	07	RSD-190-HSC-AR07_A	ELEVATION - E2		1:100	A3	3RD MARCH 2022
HSC	AR	08	RSD-190-HSC-AR08_A	ELEVATION — E3		1:100	A3	3RD MARCH 2022
HSC	AR	09	RSD-190-HSC-AR09_A	ELEVATION — E4		1:100	A3	3RD MARCH 2022
HSC	AR	10	RSD-190-HSC-AR10_A	DOOR AND WINDOW SCHEDULE - 1		1:50	A3	3RD MARCH 2022
HSC	ST	01	RSD-190-HSC-ST01_A	FOUNDATION LAYOUT		1:100	A2	3RD MARCH 2022
HSC	ST	02	RSD-190-HSC-ST02_A	ROOF BEAM LAYOUT		1:100	A2	3RD MARCH 2022
HSC	ST	03	RSD-190-HSC-ST03_A	ROOF TRUSS LAYOUT		1:100	A2	3RD MARCH 2022
HSC	ST	04	RSD-190-HSC-ST04_A	ROOF STRUCTURAL LAYOUT		1:100	A2	3RD MARCH 2022
HSC	ST	05	RSD-190-HSC-ST05_A	ROOF STRUCTURAL DETAIL		1:50 / 1:20	A2	3RD MARCH 2022
HSC	ST	06	RSD-190-HSC-ST06_A	STRUCTURAL DETAIL		1:20	A2	3RD MARCH 2022
HSC	MEP	01	RSD-190-HSC-LT01_A	LIGHTING LAYOUT		1:100	A2	3RD MARCH 2022
HSC	MEP	02	RSD-190-HSC-WS01_A	WATER SUPPLY LAYOUT		1:100	A2	3RD MARCH 2022
HSC	MEP	03	RSD-190-HSC-DR01 A	DRAINAGE LAYOUT		1:100	A2	3RD MARCH 2022

CLIENT:
MINISTRY OF YOUTH,
SPORTS & COMMUNITY
EMPOWERMENT
DESIGN AND CONSULTANCY:

PRIVATE LIMITED
LONUZIYAARAIY MAGU,MALE',20075,MALDIVES

KEY PLAN

WARNING:

- This drawing shall not be used for construction unless certified.
- Contractor to verify all dimensions of existing works on site before commencing any work or preparing shop drawings.

 Do not scale drawings, use
- Do not scale arawings, use written dimensions only.

 This drawing is to be read in conjunction with the specifications and
- conditions of contract.

 This drawing and design is copyright and no portion may be reproduced without the permission of the Consultant

REVISIONS

0	DESCRIPTION	DATE

PROJECT:

BADMINGTON COURT (3 COURTS)

PHASE:

- CONCEPT DESIGNDESIGN DEVELOPMENT
- O TENDER DOCUMENT
- O FOR CONSTRUCTION

\sim	. 01		,,,,,,,,,,,,,,,,,,,,,,,,,,,,,,,,,,,,,,,
0	AS	BUILD	DRAWING

DESIGNATION	NAME	SIGNATUR
DESIGNED BY	SIARCH.PVT.LTD	
ARCHITECT	-	
STR. ENGINEER	-	
CHECKED	MOHAMED SIRAJ	
DDAWN	SANKA SUMEDHA	

DWG. NAME:

ARCHITECTURAL

DRAWING INDEX

CODE	DATE			DWG. NO:		
RSD_190	03.03.20		190 03.03.20		022	AR00
FORMAT	A1	A2	А3	AITOO		
SCALE	-	-	NTS	ISSUE A		
PDF FILE NA	ME:	RSD-	-190	_HSC_ AROO_A		

GENERAL NOTES

GENERAL:

- ALL STRUCTURAL DRAWINGS SHALL BE READ IN CONJUNCTION WITH ALL ARCHITECTURAL AND SERVICE DRAWINGS, SPECIFICATIONS AND WRITTEN INSTRUCTIONS IF ISSUED DURING THE COURSE OF THE CONTRACT. ALL DISCREPANCIES SHALL BE REFERRED FOR DECISION BEFORE PROCEEDING WITH THE WORK.
- 2. THE DRAWINGS SHALL NOT BE SCALED. AII DIMENSIONS RELEVANT TO SETTING OUT AND OFF-SITE SHALL BE VERIFIED BY THE CONTRACTOR BEFORE CONSTRUCTION AND FABRICATION IS COMMENCED.
- 3. DURING THE CONSTRUCTION PERIOD THE CONTRACTOR SHALL BE RESPONSIBLE TO MAINTAIN THE STABILITY OF STRUCTURE AND ENSURE THAT NO STRUCTURAL ELEMENT BE OVERSTRESSED UNDER CONSTRUCTION ACTIVITIES.
- 4. WORKMANSHIP AND MATERIALS SHALL BE IN ACCORDANCE WITH THE RELEVANT RECENT BS CODES OR OTHER ACCETABLE STANDARDS.
- 5. BASED ON THE DRAWINGS AND SPECIFICATIONS THE CONTRACTOR SHALL PRODUCE STRUCTURAL SHOP DRAWINGS FOR APPROVAL IF REQUESTED.
- 6. ALL DIMENSIONS TO STRUCTURAL DRAWINGS ARE IN MILLIMETERS UNLESS STATED OTHERWISE. ALL LEVELS ARE EXPRESSED IN METRES.
- 7. THE REINFORCED CONCRETE DESIGN IS BASED ON BS 8110 'STRUCTURAL USE OF CONCRETE'
- 8. REFER TO STANDARD AND TYPICAL DETAILS AS SHOWN IN THE TYPICAL DRAWINGS FOR DETAILS NOT SHOWN SPECIFICALLY.
- 9. ALL PROPS AND FORMWORK FOR BEAMS AND SLABS SHALL BE REMOVED BEFORE CONSTRUCTION OF ANY MASONRY WALLS OR OTHER PERMANENT LOADING ON THE SLAB.
- 10. ALL NON-LOAD BEARING WALLS SHALL BE KEPT CLEAR OFF THE UNDERSIDE OF SLABS AND BEAMS BY 30mm. THE JOINT SHALL BE FILLED WITH FIBRE BOARD OR COMPRESSIBLE MATERIAL PRESSED METAL COVERING BOTH SIDES OF THE JOINT, AND THE METAL COVERING SHALL BE FIXED TO SOFFIT OF THE BEAM OR SLAB AS THE CASE MAY BE.

FOUNDATIONS:

- 1. ALL FOUNDATIONS HAS BEEN DESIGNED FOR SAFE GROUND PRESSURE OF 150 KN/m2
- 2. ALL FOOTINGS SHALL BE PLACED MINIMUM 1.2m BELOW THE NATURAL GROUND LEVEL UNLESS STATED OTHERWISE
- 3. ALL BACKFILL SHOULD BE DONE WITH APPROVED MATERIAL AND SOURCE.
 ALL BACKFILL SHOULD BE STRUCTURAL FILL, COMPACTED IN LAYERS AS SPECIFIED.
- 4. WEAK POCKETS FOUND BELOW THE ASSUMED FOUNDATION LEVELS SHALL BE REMOVED AND REPLACED BY PLAIN CONCRETE.
- 5. IN CASE OF EXCAVATIONS BELOW THE ASSUMED LEVEL OF THE FOOTING, THE SOIL SHALL BE REPLACED BY PLAIN CONCRETE.
- 6. IN CASE GROUND WATER IS PRESENT ABOVE FOUNDATION LEVEL, THE CONTRACTOR SHALL BE RESPONSIBLE FOR DEWATERING THE SITE, AND LOVERING THE GROUND WATER TO AT LEAST 70cm BELOW LEVEL OF FOUNDATIONS.
- 7. THE CONTRACTOR SHALL MAINTAIN DRY WORKING CONDITIONS THROUGHOUT THE CONSTRUCTION PERIOD. RESTORING WATER TABLE CAN BE DONE AFTER BACKFILLING AND COMPACTION UP TO THE SLAB ON GRADE LEVEL, OR AS DIRECTED BY THE ENGINEER.
- 8. NO BACKFILLING SHALL BE PLACED AGAINST WALLS RETAINING EARTH, UNLESS THE WALLS ACHIEVE SUFFICIENT STRENTGH TO PREVENT MOVEMENT OR STRUCTURAL DAMAGE.
- 9. UNLESS OTHERWISE SHOWN ALL FOOTINGS ARE CONCETRIC TO COLUMNS.

CONCRETE:

- a. ALL INSITU STRUCTURAL CONCRETE SHALL HAVE MINIMUM 28 DAYS CUBE STRENGTH OF 25 N/mm2 TO THE RELEVANT CLAUSES OF BS5328.
 - b. ALL PLAIN CONCRETE (OR BLINDING) SHALL HAVE MINIMUM 28 DAYS CUBE STRENGTH OF 15 N/mm2 (EQUIVALENT CYLINDER STRENGTH, FC = 12 N/mm2), TO THE RELEVANT CLAUSES OF BS538.
- 3. NO OPENINGS, HOLES, CHASES OR EMBEDMENT OF PIPES OTHER THAN THOSE IN THE STRUCTURAL DRAWINGS SHALL BE MADE IN CONCRETE MEMBERS WITHOUT PRIOR APPROVAL
- 4. CONSTRUCTION AND EXPANSION JOINTS SHALL BE PROPERLY FORMED AND USED ONLY WHERE SHOWN OR SPECIFICALLY APPROVED.
- 5. NO ELECTRICAL CONDUIT AND PIPES ARE TO BE CAST IN COLUMNS OR THROUGH BEAMS WITHOUT PRIOR APPROVAL UNLESS OTHERWISE SHOWN IN THE DRAWINGS
- 6. SPECIAL RULES REGARDING CONCRETING IN HOT WEATHER SHALL BE OBSERVED
- 7. OPENING IN SLABS:

FOR OPENING LESS THAN 150 x 150mm BARS SHALL BE RE—ARRANGED AROUND THE OPENING

FOR OPENINGS GREATER THAN 300 x 300mm BUT LESS THAN 600 x 600mm AND NOT SHOWN ON PLAN, PROVIDE 2Ø16 TOP AND BOTTOM ALONG EACH SIDE AND DIAGONALLY AT CORNERS OR AS OTHERWISE DETAILED. AMOUNT OF BARS GOT DISCONTINUED DUE TO THE OPENING SHALL BE PLACED AT THE RESPECTIVE SIDES.

OPENINGS GREATER THAN 600 x 600mm AND NOT SHOWN ON PLAN SHALL BE APPROVED

8. SHEAR KEY SHALL BE PROVIDED AT ALL CONSTRUCTION JOINTS.

REINFORCEMENT:

- 1. REINFORCING STEEL SHALL BE HIGH STRENGTH DEFORMED BARS CONFORMING TO BS-4449 WITH MINIMUM YIELD STRENGTH FY=410 N/mm2, GRADE 410. WELDED WIRE MESH SHALL COMPLY WITH BS-4483.
- 2. SPLICES IN REINFORCEMENT SHALL BE MADE ONLY IN THE POSITION SHOWN OR AS OTHERWISE APPROVED.
- 3. 25mm SPACER BARS SHALL BE PROVIDED AT 100cm CENTERS WHEREVER REINFORCEMENT IS PLACED IN MORE THAN ONE LAYER, UNLESS STATED OTHERWISE
- 4. WELDING OF REINFORCEMENT SHALL NOT BE PERMITTED. IF REINFORCEMENT SHOULD BE WELDED, APPROVAL IS REQUIRED.
- 5. ALL REINFORCEMENT SHALL BE SUPPORTED IN ITS CORRECT POSITION DURING CONCRETING BY APPROVED BAR CHAIRS, SPACERS, OR SUPPORT BARS.
- 6. TYPICAL DEVELOPMENT AND SPLICES OF DEFORMED BARS WITH FY = 410 N/mm2 AND Fc' = 24 N/mm2, (CYLINDER STRENGTH) SHALL BE AS FOLLOWS, UNLESS OTHERWISE MENTIONED IN DRAWINGS:
 - 6.1 BASIC TENSION DEVELOPMENT LENGTH, LD = $45 \times BAR$ DIA.
 - 6.2 FOR HORIZONTAL REINFORCEMENTS (MEMBER THICKNESS LESS THAN 300mm) TENSION DEVELOPMENT LENGTH OR SPLICE, LD = $60 \times BAR$ DIA.
 - 6.3 FOR HORIZONTAL REINFORCEMENTS (MEMBER THICKNESS MORE THAN 300mm) TENSION DEVELOPMENT LENGTH OR SPLICE, LD = 70 x BAR DIA.
 - 6.4 CLAUSES 6.1 TO 6.3 ARE APPLICABLE TO SLAB, WALL, BEAM, COLUMN, FOOTING AND RAFT.
 - 6.5 MINIMUM COMPRESSION DEVELOPMENT LENGTH, LDC = 30 x BAR DIA (OR 300mm WHICHEVER IS MORE).

CLIENT: MINISTRY OF YOUTH, SPORTS & COMMUNITY EMPOWERMENT



KEY PLAN:

WARNING:

- This drawing shall not be used for construction unless certified.
- Contractor to verify all dimensions of existing works on site before commencing any work or preparing shop drawings.
 Do not scale drawings, use
- written dimensions only.

 This drawing is to be read in conjunction with the specifications and conditions of contract.
- This drawing and design is copyright and no portion may be reproduced without the permission of the Consultant

	REVISIONS							
NO	DESCRIPTION	DATE						

PROJECT:

BADMINGTON COURT (3 COURTS)

PHASE:

- CONCEPT DESIGN
 DESIGN DEVELOPMENT
- O TENDER DOCUMENT
- FOR CONSTRUCTION
 AS BUILD DRAWINGS

DESIGNATION	NAME	SIG
DESIGNED BY	SIARCH.PVT.LTD	
ARCHITECT	-	
STR. ENGINEER	-	
CHECKED	MOHAMED SIRAJ	
DOMES	CANICA CUMEDUA	


NATURE

DWG. NAME:

ARCHITECTURAL

DRAWING INDEX

	CODE	DATE			DWG. NO:
	RSD_190	03.03.2022		022	AR01
	FORMAT	A1	A2	A3	AITOI
	SCALE	-	-	NTS	ISSUE A
PDF FILE NAME: RSD-190_HSC_ ARO					

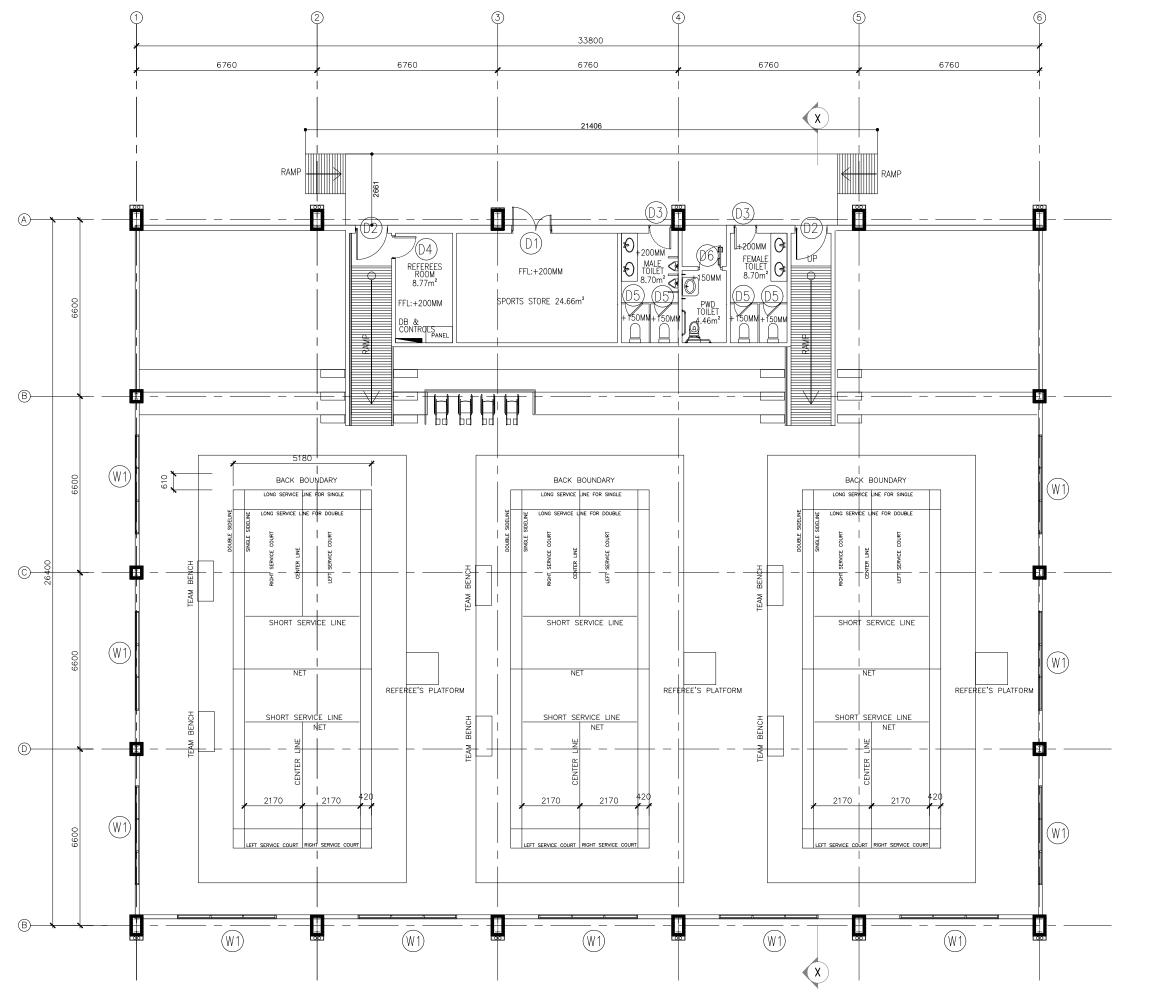


BADMINGTON COURT PLAN VIEW (3 COURTS)

CLIENT: MINISTRY OF YOUTH, SPORTS & COMMUNITY EMPOWERMENT

DESIGN AND CONSULTANCY:



 KEY PLAN:



WARNING:

- This drawing shall not be used for construction unless certified.
 Contractor to verify all dimensions of existing works.
- works on site before
 commencing any work or
 preparing shop drawings.

 Do not scale drawings, use
 written dimensions only.

 This drawing is to be read
 in conjunction with the
- specifications and conditions of contract.
- This drawing and design is copyright and no portion may be reproduced without the permission of the Consultant

	REVISIONS							
NO	DESCRIPTION	DATE						

PROJECT:

BADMINGTON COURT (3 COURTS)

- CONCEPT DESIGN
 DESIGN DEVELOPMENT
 TENDER DOCUMENT
- O FOR CONSTRUCTION O AS BUILD DRAWINGS


DESIGNATION	NAME	SIGNATU
DESIGNED BY	SIARCH.PVT.LTD	
ARCHITECT	-	
STR. ENGINEER	-	
CHECKED	MOHAMED SIRAJ	
DRAWN	SANKA SUMEDHA	

DICIPLINE:

ARCHITECTURAL

BADMINGTON COURT PLAN VIEW (3 COURTS)

(0 0001110)							
CODE	DATE			DWG. NO:			
RSD-190	03.03.2022)22	AR02			
FORMAT	A1	A2	А3	ANUZ			
SCALE	-	1:100	-	ISSUE A			
PDF FILE NA	ME:	PSD.	_100	HSC ARO2 A			

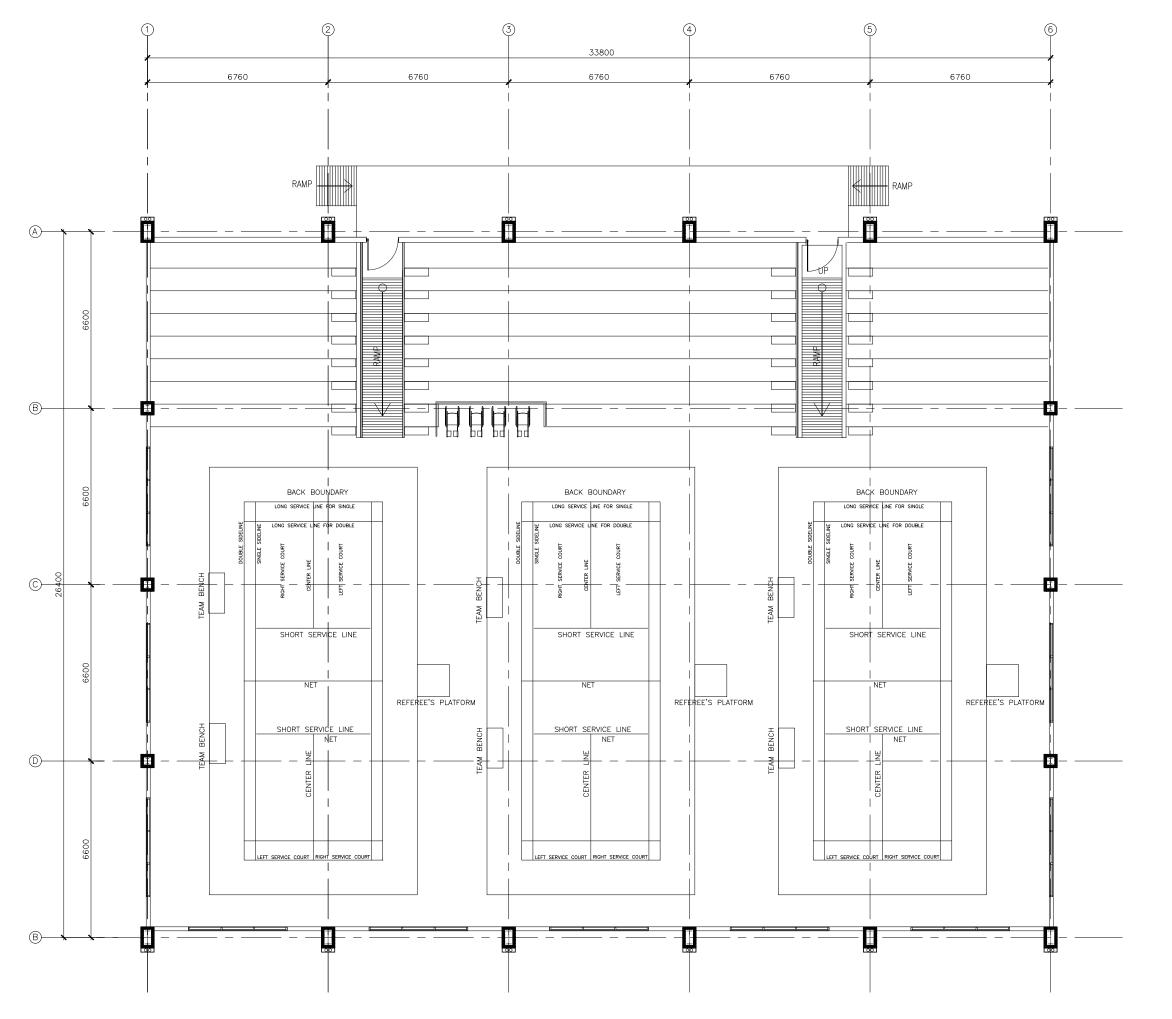


RETRACTABLE SEATINGS LAYOUT

CLIENT: MINISTRY OF YOUTH, SPORTS & COMMUNITY EMPOWERMENT

DESIGN AND CONSULTANCY:



 KEY PLAN:



WARNING:

- This drawing shall not be used for construction unless certified.
 Contractor to verify all dimensions of existing works.
- works on site before
 commencing any work or
 preparing shop drawings.

 Do not scale drawings, use
 written dimensions only.

 This drawing is to be read
 in conjunction with the
 specifications and
- specifications and conditions of contract.
- This drawing and design is copyright and no portion may be reproduced without the permission of the Consultant

	REVISIONS						
NO	DESCRIPTION	DATE					

PROJECT:

BADMINGTON COURT (3 COURTS)

- CONCEPT DESIGN
 DESIGN DEVELOPMENT
 TENDER DOCUMENT
- O FOR CONSTRUCTION O AS BUILD DRAWINGS


DESIGNATION	NAME	SIGNATU
DESIGNED BY	SIARCH.PVT.LTD	
ARCHITECT	-	
STR. ENGINEER	-	
CHECKED	MOHAMED SIRAJ	
DDAWN	CANIVA CLIMEDIJA	

DICIPLINE:

ARCHITECTURAL

RETRACTABLE SEATINGS LAYOUT


CODE	DATE			DWG. NO:	
RSD-190	03.03.2022)22	ARO3	
FORMAT	A1	A2	А3	711100	
SCALE	-	1:100	-	ISSUE A	
PDF FILE NAME: RSD-190_HSC_ AR03_A					

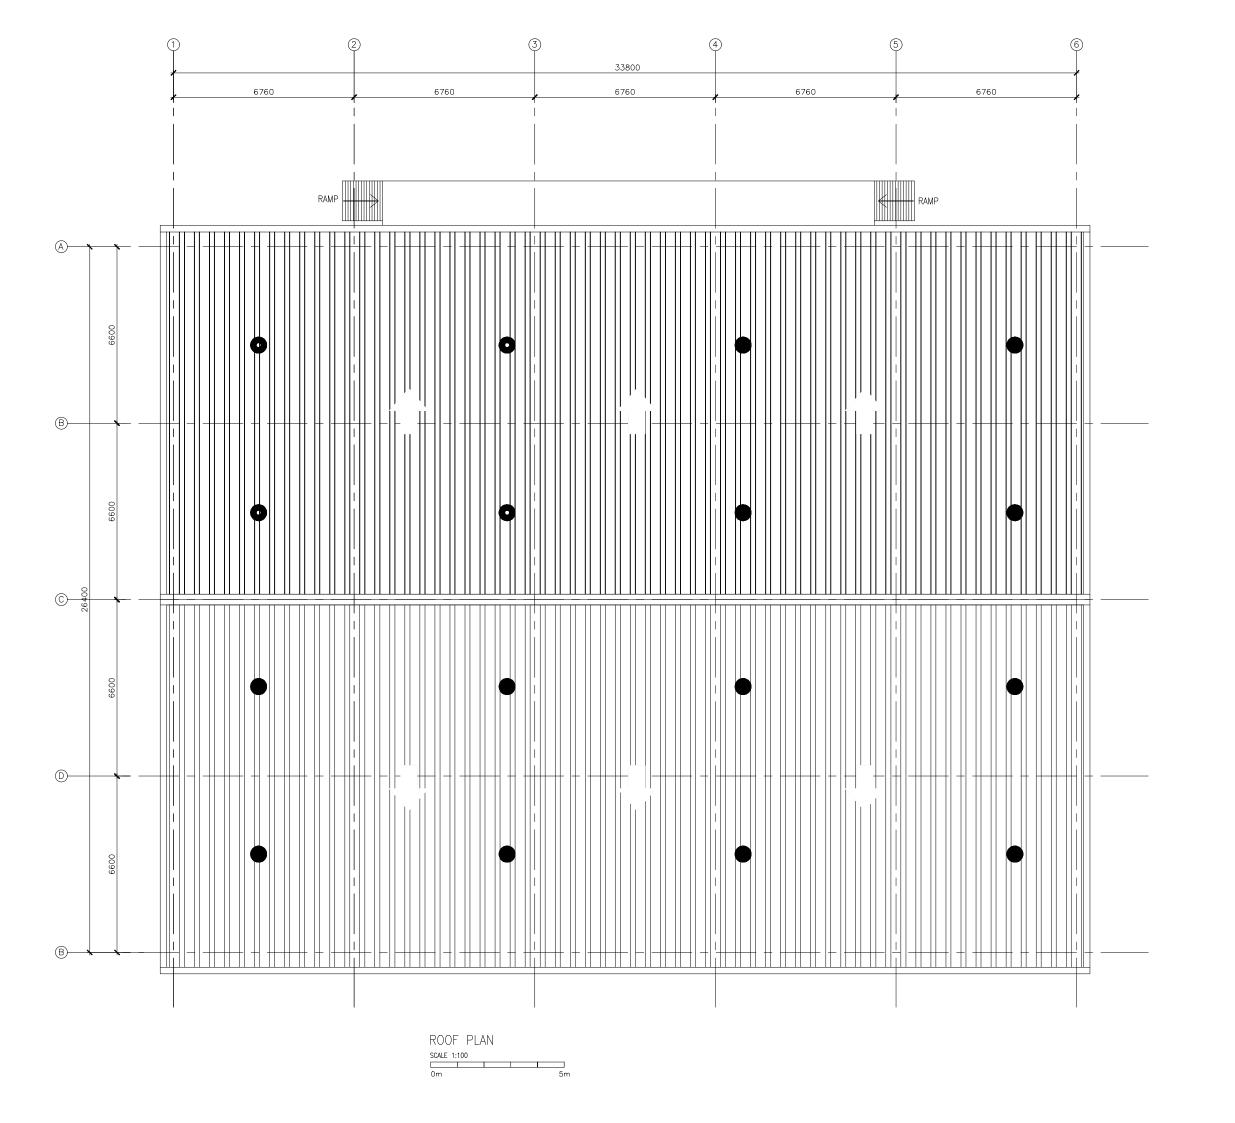

DESIGN AND CONSULTANCY:



 KEY PLAN:



WARNING:

- This drawing shall not be used for construction unless certified.
 Contractor to verify all dimensions of existing works.

- dimensions of existing works on site before commencing any work or preparing shop drawings.

 Do not scale drawings, use written dimensions only.

 This drawing is to be read in conjunction with the specifications and conditions of contract.

 This drawing and design is copyright and no portion may be reproduced without the permission of the Consultant

	REVISIONS	
NO	DESCRIPTION	DATE

PROJECT:

BADMINGTON COURT (3 COURTS)

- CONCEPT DESIGN
 DESIGN DEVELOPMENT
 TENDER DOCUMENT
- O FOR CONSTRUCTION
- O AS BUILD DRAWINGS


DESIGNATION	NAME	SIGNATUR
DESIGNED BY	SIARCH.PVT.LTD	
ARCHITECT	-	
STR. ENGINEER	-	
CHECKED	MOHAMED SIRAJ	
DRAWN	SANKA SUMEDHA	

DICIPLINE:

ARCHITECTURAL

ROOF PLAN

CODE		DATE			DWG. NO:
RSD-1	190	03.03.2022)22	ARO4
FORMA	ΑT	A1	A2	А3	711101
SCALE	Ε	-	1:100	ı	ISSUE A
PDF FILE NAME: RSD-190_HSC_ AR04_A					

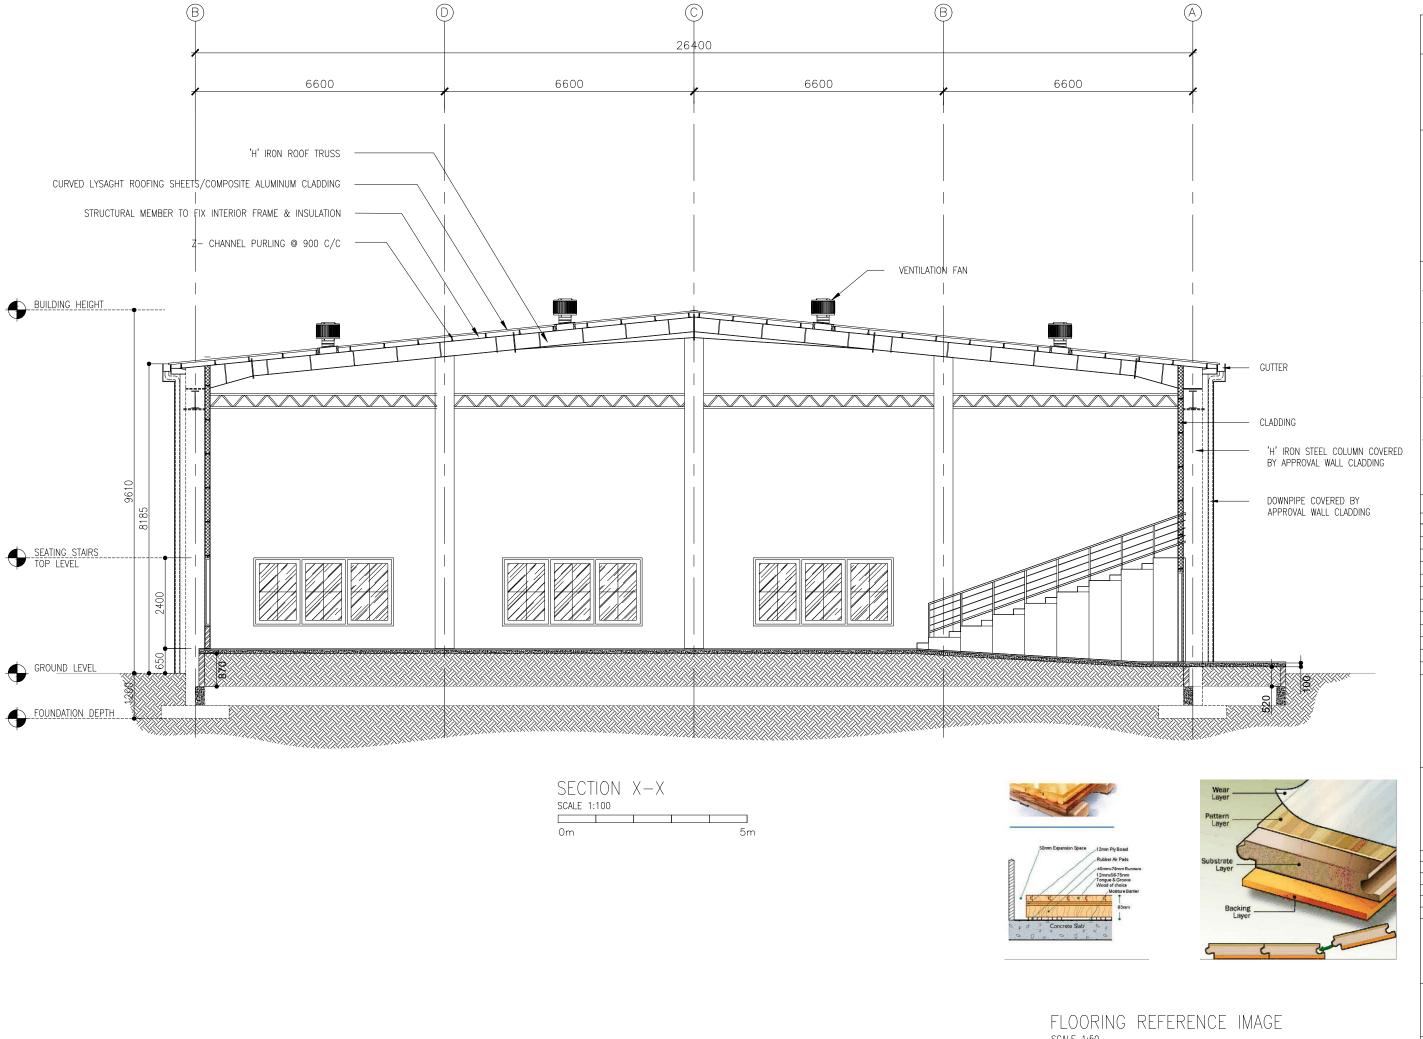


SCALE 1:50

CLIENT: MINISTRY OF YOUTH, SPORTS & COMMUNITY EMPOWERMENT

DESIGN AND CONSULTANCY:



 KEY PLAN:



WARNING:

- This drawing shall not be used for construction unless certified.
 Contractor to verify all dimensions of existing works on site before commencing any work or preparing shop drawings.
 Do not scale drawings, use written dimensions only.
- written dimensions only.
 This drawing is to be read in conjunction with the specifications and conditions of contract.
- This drawing and design is copyright and no portion may be reproduced without the permission of the Consultant

REVISIONS	
ECODIDION	

	TIE TIGIOTIS						
NO	DESCRIPTION	DATE					

PROJECT:

SINGLE VOLLEY BALL COURT INDOOR

PHASE:

- CONCEPT DESIGN
 DESIGN DEVELOPMENT O TENDER DOCUMENT O FOR CONSTRUCTION
- O AS BUILD DRAWINGS


DESIGNED BY	SIARCH.PVT.LTD	
ARCHITECT	-	
STR. ENGINEER	-	
CHECKED	MOHAMED SIRAJ	
DRAWN	SANKA SUMEDHA	

DICIPLINE:

ARCHITECTURAL

SECTION X-X

	CODE	DATE			DWG. NO:
	RSD-190	03.03.2022			AR05
	FORMAT	A1	A2	A3	ANOS
	SCALE	-	-	1:100	ISSUE A
PDF FILE NAME: RSD-190_HSC_ AR05_A					

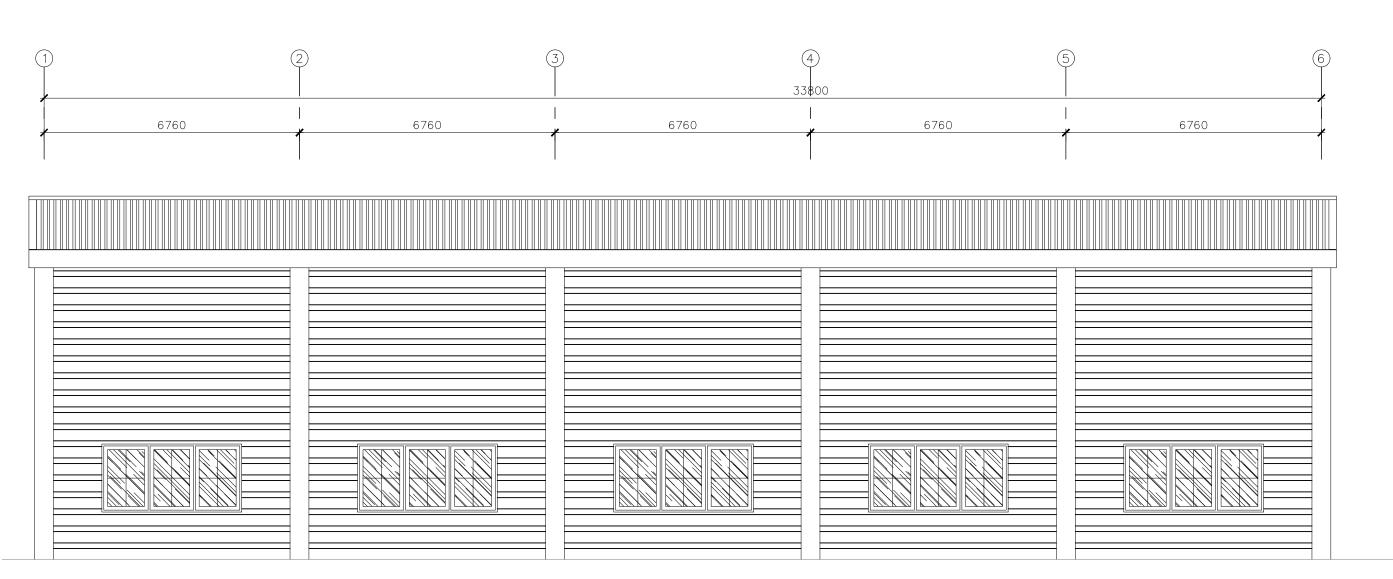

ELEVATION - E1 SCALE 1:100

CLIENT: MINISTRY OF YOUTH, SPORTS & COMMUNITY EMPOWERMENT

DESIGN AND CONSULTANCY:



KEY PLAN:



WARNING:

- This drawing shall not be used for construction unless certified.
 Contractor to verify all dimensions of existing works on site before commencing any work or preparing shop drawings.
 Do not scale drawings, use written dimensions only.
 This drawing is to be read in conjunction with the specifications and conditions of contract.
 This drawing and design is copyright and no portion may be reproduced without the permission of the Consultant

REVISIONS

NO	DESCRIPTION	DATE

PROJECT:

SINGLE VOLLEY BALL COURT INDOOR

PHASE:


- CONCEPT DESIGN
 DESIGN DEVELOPMENT
 TENDER DOCUMENT
- O FOR CONSTRUCTION AS BUILD DRAWINGS

DESIGNATION	NAME	SIGNA
DESIGNED BY	SIARCH.PVT.LTD	
ARCHITECT	-	
STR. ENGINEER	-	
CHECKED	MOHAMED SIRAJ	
DRAWN	SANKA SUMEDHA	

DICIPLINE:

ARCHITECTURAL

CODE	DATE			DWG. NO:
RSD-190	03.03.2022			AR06
FORMAT	A1	A2	A3	/11100
SCALE	-	-	1:100	ISSUE A
PDF FILE NA	ME:	PSD.	_100	HSC AROS A

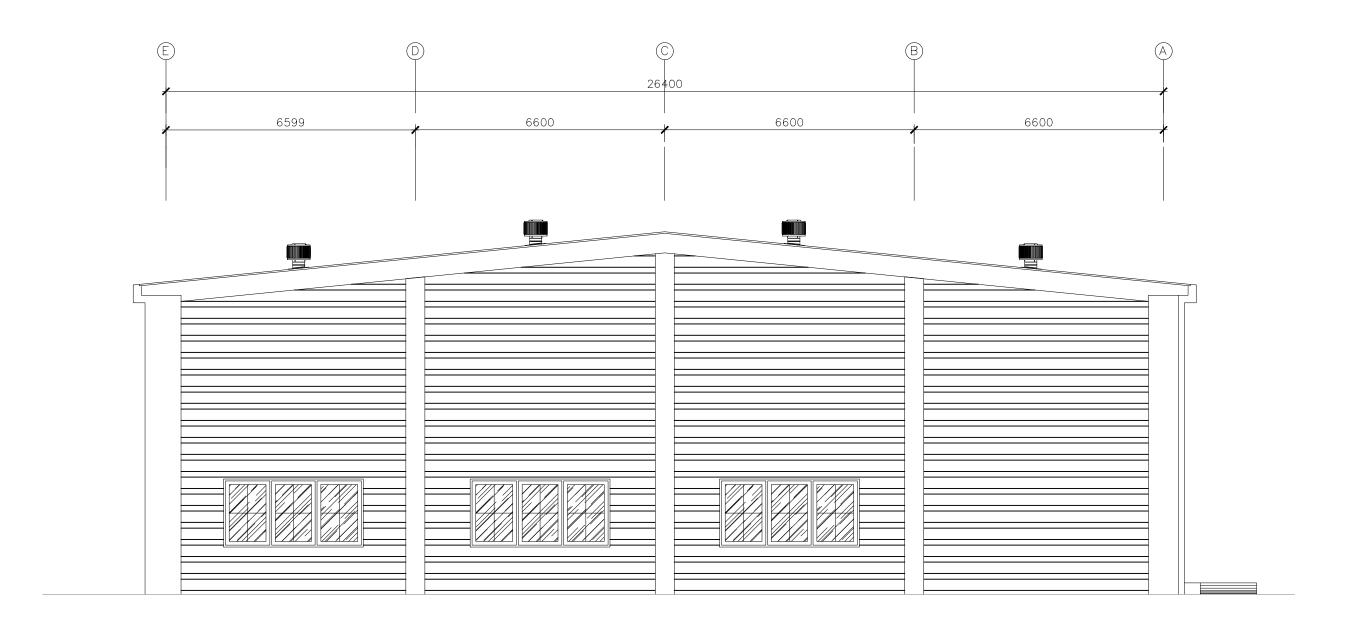




DESIGN AND CONSULTANCY:



 KEY PLAN:



WARNING:

- This drawing shall not be used for construction unless certified.
 Contractor to verify all dimensions of existing works on site before commencing any work or preparing shop drawings.
 Do not scale drawings, use written dimensions only.
 This drawing is to be read in conjunction with the specifications and conditions of contract.
 This drawing and design is copyright and no portion may be reproduced without the permission of the Consultant

REVISIONS

NO	DESCRIPTION	DATE

PROJECT:

SINGLE VOLLEY BALL COURT INDOOR

PHASE:


- CONCEPT DESIGN
 DESIGN DEVELOPMENT
 TENDER DOCUMENT
- O FOR CONSTRUCTION AS BUILD DRAWINGS


DESIGNATION	NAME	SIGNATU
DESIGNED BY	SIARCH.PVT.LTD	
ARCHITECT	-	
STR. ENGINEER	-	
CHECKED	MOHAMED SIRAJ	
DRAWN	SANKA SUMEDHA	

DICIPLINE:

ARCHITECTURAL

CODE		DATE		DWG. NO:
RSD-190	03.	03.2	022	AR07
FORMAT	A1	A2	A3	/11/0/
SCALE	-	-	1:100	ISSUE A
PDF FILE NA	ME:	RSD	-190	HSC AR07 A

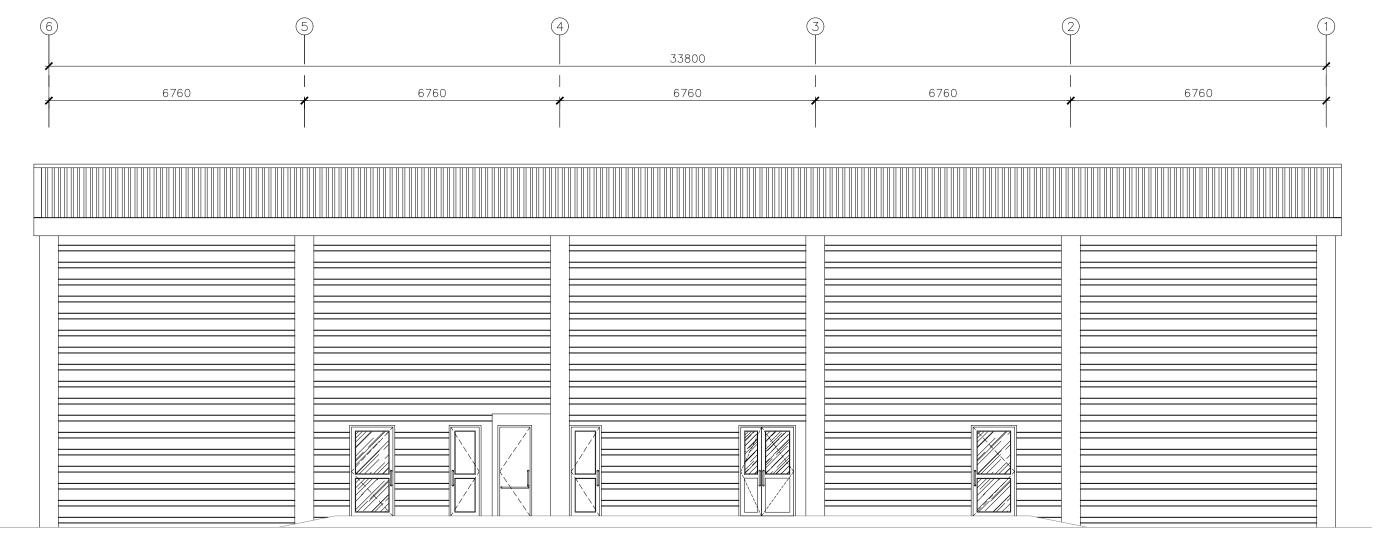


 

DESIGN AND CONSULTANCY:



 KEY PLAN:



WARNING:

- This drawing shall not be used for construction unless certified.
 Contractor to verify all dimensions of existing works on site before commencing any work or preparing shop drawings.
 Do not scale drawings, use written dimensions only.
 This drawing is to be read in conjunction with the specifications and conditions of contract.
 This drawing and design is copyright and no portion may be reproduced without the permission of the Consultant

REVISIONS

Г	NO	DESCRIPTION	DATE
Γ			
ľ			
L			

PROJECT:

SINGLE VOLLEY BALL COURT INDOOR

PHASE:

- CONCEPT DESIGN
 DESIGN DEVELOPMENT
 TENDER DOCUMENT


ı	\circ	rur	CONS	INOCIION
	0	AS	BUILD	DRAWING

DESIGNATION	NAME	SIGNATI
DESIGNED BY	SIARCH.PVT.LTD	
ARCHITECT	-	
STR. ENGINEER	-	
CHECKED	MOHAMED SIRAJ	
DDAWN	CANICA CLIMEDIA	

DICIPLINE:

ARCHITECTURAL

CODE		DATE		DWG. NO:
RSD-190	03.	03.2	022	AR08
FORMAT	A1	A2	A3	/11100
SCALE	-	-	1:100	ISSUE A
PDF FILE NA	ME:	RSD	_190	HSC AROS A

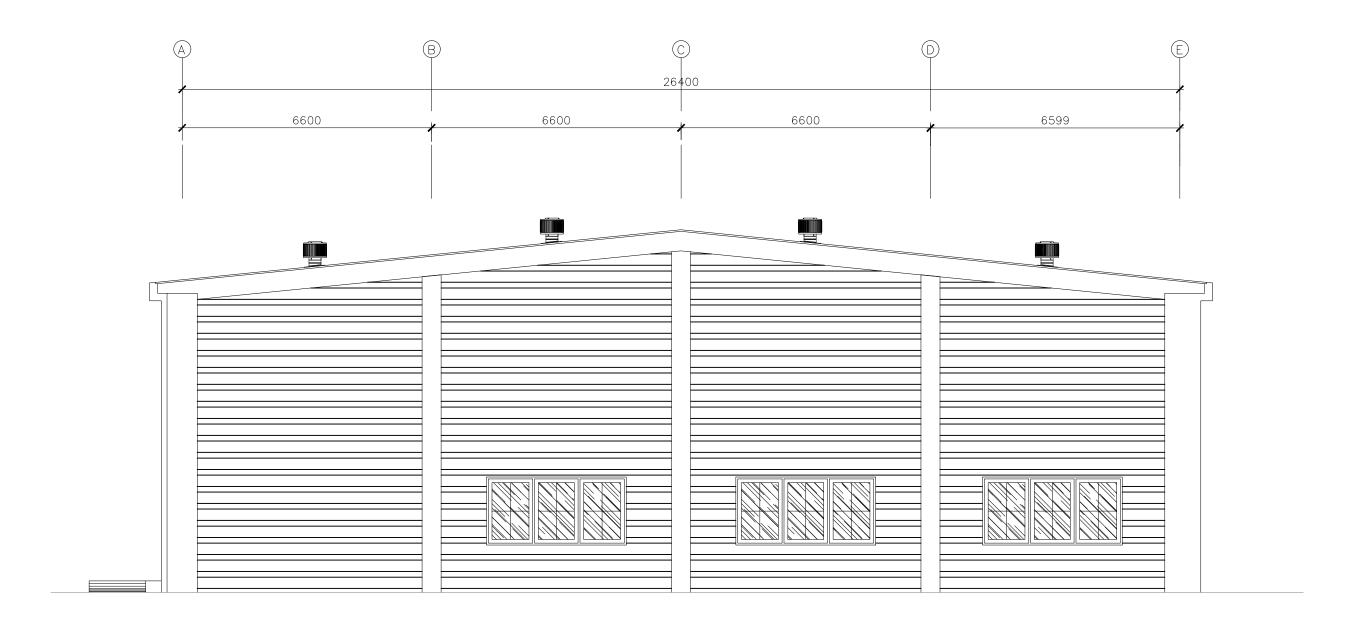




DESIGN AND CONSULTANCY:



 KEY PLAN:



WARNING:

- This drawing shall not be used for construction unless certified.

 Contractor to verify all dimensions of existing works on site before commencing any work or preparing shop drawings.

 Do not scale drawings, use written dimensions only.

 This drawing is to be read in conjunction with the specifications and conditions of contract.

 This drawing and design is copyright and no portion may be reproduced without the permission of the Consultant

REVISIONS

NO	DESCRIPTION	DATE

PROJECT:

SINGLE VOLLEY BALL COURT INDOOR

PHASE:


- CONCEPT DESIGN
 DESIGN DEVELOPMENT
 TENDER DOCUMENT
- O FOR CONSTRUCTION AS BUILD DRAWINGS


DESIGNATION	NAME	SIGNATU
DESIGNED BY	SIARCH.PVT.LTD	
ARCHITECT	-	
STR. ENGINEER	-	
CHECKED	MOHAMED SIRAJ	
DRAWN	SANKA SUMEDHA	

DICIPLINE:

ARCHITECTURAL


CODE		DATE		DWG. NO:
RSD-190	03.	03.20	022	AR09
FORMAT	A1	A2	A3	/11103
SCALE	-	-	1:100	ISSUE A
PDF FILE NA	ME:	RSD.	_190	HSC ARO9 A

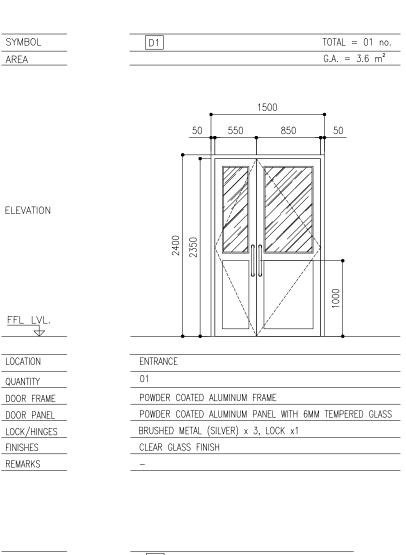

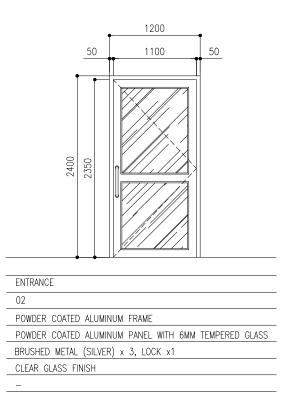

TOTAL = 02 no.


 $G.A. = 2.88 \text{ m}^2$

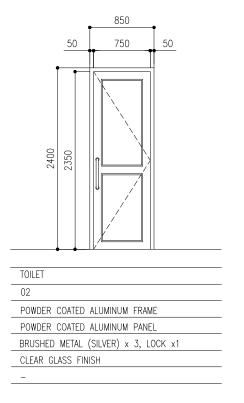

D3

TOTAL = 02 no.

 $G.A. = 1.82 \text{ m}^2$

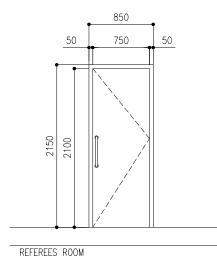

D4

TOTAL = 01 no.

G.A. = 1.82 m^2

REFEREES ROOM
01
POWDER COATED ALUMINUM FRAME
POWDER COATED ALUMINUM PANEL
BRUSHED METAL (SILVER) x 3, LOCK x1
CLEAR GLASS FINISH

	SYMBOL
AREA	AREA

ELEVATION

D5	TOTAL = 04 no.
	G.A. = 1.3 m^2

[D6]	TOTAL = 01 no.
	G.A. = 1.93 m^2


900

D2

W1	TOTAL = 11 no.
	G.A. = 6.66 m^2


3700 1150


1175

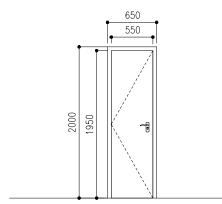


=L	LVL.	
	\downarrow	
CAT	ION	

LOCATION
QUANTITY
DOOR FRAME
DOOR PANEL
LOCK/HINGES
FINISHES
REMARKS

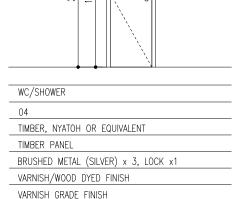

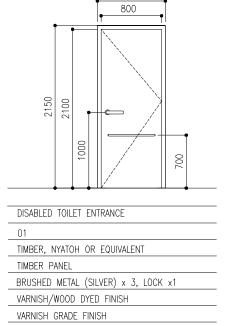

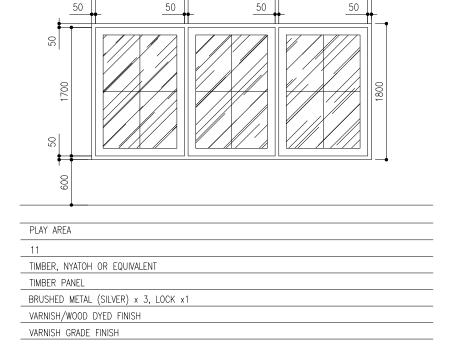


CLIENT: MINISTRY OF YOUTH,
SPORTS & COMMUNITY EMPOWERMENT

DESIGN AND CONSULTANCY:



 KEY PLAN:



WARNING:

- This drawing shall not be used for construction unless certified.
- Contractor to verify all dimensions of existing works on site before commencing any work or preparing shop drawings. Do not scale drawings, use
- written dimensions only.
 This drawing is to be read in conjunction with the specifications and conditions of contract.
- This drawing and design is copyright and no portion may be reproduced without the permission of the Consultant

REVISIONS

NO	DESCRIPTION	DATE

PROJECT:

SINGLE VOLLEY BALL COURT INDOOR

PHASE:

- CONCEPT DESIGN O DESIGN DEVELOPMENT O TENDER DOCUMENT
- O FOR CONSTRUCTION O AS BUILD DRAWINGS


DESIGNATION	NAME	SIGNATU
DESIGNED BY	SIARCH.PVT.LTD	
ARCHITECT	-	
STR. ENGINEER	-	
CHECKED	MOHAMED SIRAJ	

DICIPLINE:

ARCHITECTURAL

DOOR AND WINDOW SCHEDULE - 1

CODE	DATE			DWG. NO:
RSD-190	03.03.2022		022	AR10
FORMAT	A1	A2	A3	ANTO
SCALE	-	-	1:50	ISSUE A
PDF FILE NA	ME:	RSD.	-190	HSC AR10 A

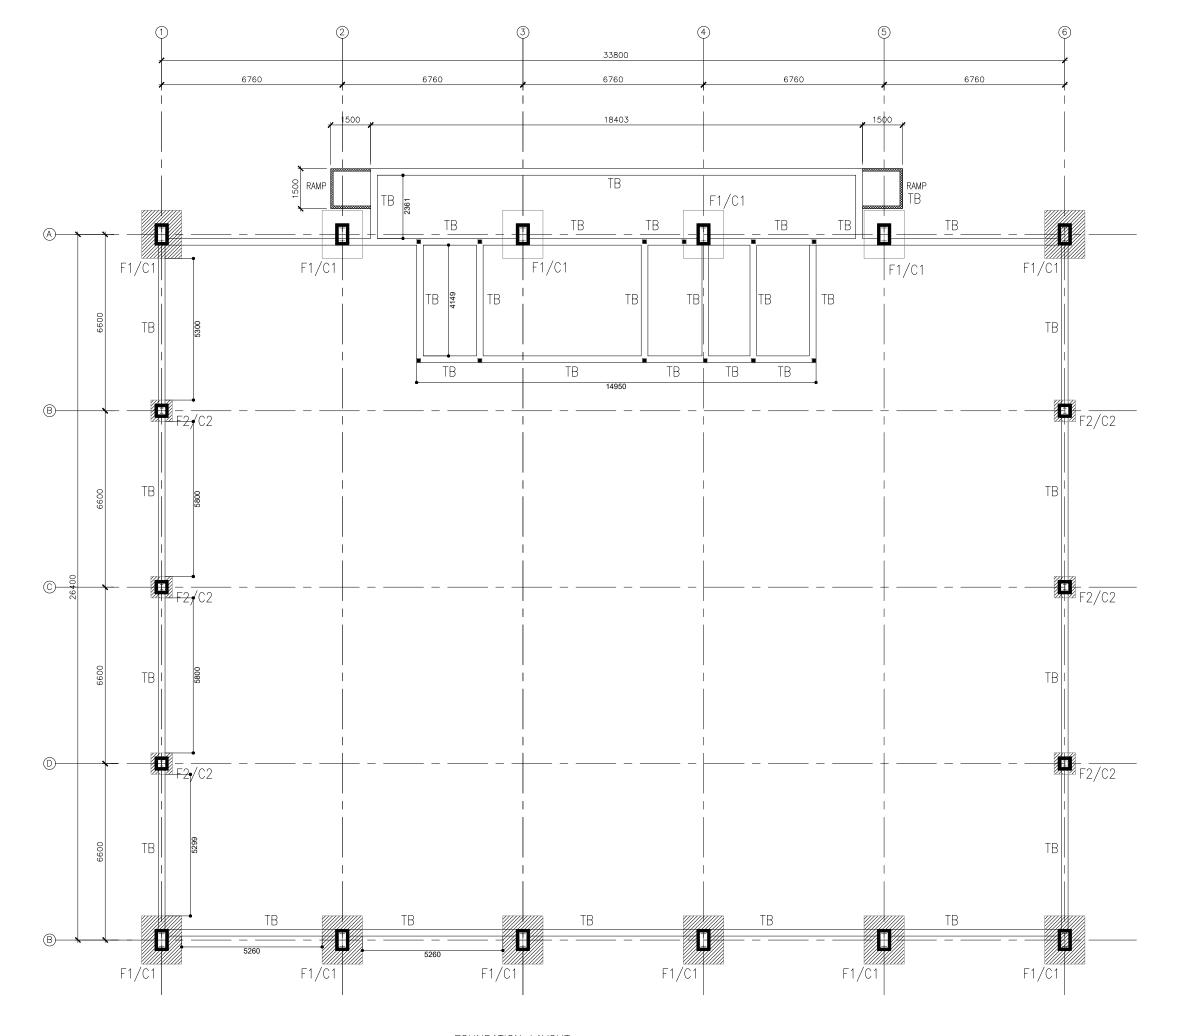

FOUNDATION LAYOUT

FOUNDATION DEPTH :


1200 m	im BELOW NATURAL GR	OUND LEVEL
TYPE	DIMENSION	REINFORCEMENT
F1	1500 X 1800 X 350	T12@150 B/W (B)
F2	800 X 800 X 350	T12@150 B/W (B)

CLIENT: MINISTRY OF YOUTH, SPORTS & COMMUNITY EMPOWERMENT

DESIGN AND CONSULTANCY:



 KEY PLAN:



WARNING:

- This drawing shall not be used for construction unless certified.
 Contractor to verify all dimensions of existing works.
- works on site before
 commencing any work or
 preparing shop drawings.

 Do not scale drawings, use
 written dimensions only.

 This drawing is to be read
 in conjunction with the
 specifications and
- specifications and
- conditions of contract.

 This drawing and design is copyright and no portion may be reproduced without the permission of the Consultant

	REVISIONS		
NO	DESCRIPTION	DATE	

PROJECT:

BADMINGTON COURT (3 COURTS)

PHASE:

- CONCEPT DESIGN
 DESIGN DEVELOPMENT
 TENDER DOCUMENT

- O FOR CONSTRUCTION O AS BUILD DRAWINGS


DESIGNATION	NAME	SIGNATURE
DESIGNED BY	SIARCH.PVT.LTD	
ARCHITECT	-	
STR. ENGINEER	-	
CHECKED	MOHAMED SIRAJ	
DRAWN	SANKA SUMEDHA	

DICIPLINE:

STRUCTURAL

FOUNDATION LAYOUT

CODE	DATE			DWG. NO:
RSD-190	03.03.2022)22	ST01
FORMAT	A1	A2	А3	3101
SCALE	-	1:100	-	ISSUE A
PDF FILE NAME: RSD-190_HSC_ ST01 _A				

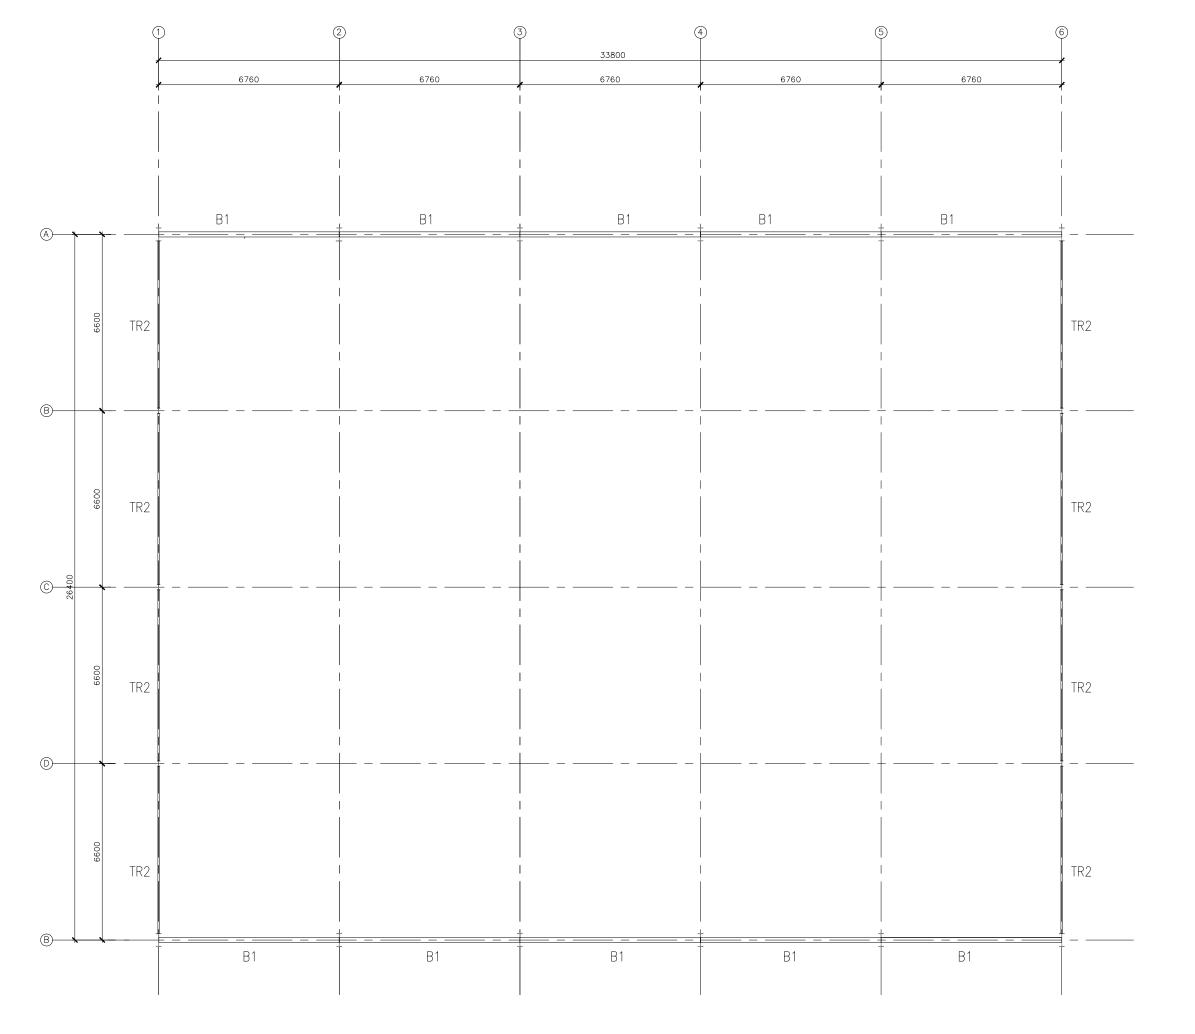


ROOF BEAM LAYOUT

CLIENT: MINISTRY OF YOUTH, SPORTS & COMMUNITY EMPOWERMENT

DESIGN AND CONSULTANCY:



 KEY PLAN:



WARNING:

- This drawing shall not be used for construction unless certified.
 Contractor to verify all dimensions of existing works.

- dimensions of existing works on site before commencing any work or preparing shop drawings.

 Do not scale drawings, use written dimensions only.

 This drawing is to be read in conjunction with the specifications and conditions of contract.

 This drawing and design is copyright and no portion may be reproduced without the permission of the Consultant Consultant

	REVISIONS	
N0	DESCRIPTION	DATE

PROJECT:

BADMINGTON COURT (3 COURTS)

- CONCEPT DESIGN
 DESIGN DEVELOPMENT
 TENDER DOCUMENT
- O FOR CONSTRUCTION O AS BUILD DRAWINGS


DESIGNATION	NAME	SIGNATURE
DESIGNED BY	SIARCH.PVT.LTD	
ARCHITECT	-	
STR. ENGINEER	-	
CHECKED	MOHAMED SIRAJ	
DRAWN	SANKA SUMEDHA	

DICIPLINE:

STRUCTURAL

ROOF BEAM LAYOUT

CODE	DATE			DWG. NO:		
RSD-190	03.03.2022)22	ST02		
FORMAT	A1	A2	А3	3102		
SCALE	-	1:100	-	ISSUE A		
PDF FILE NAME: RSD-190_HSC_ ST02 _A						

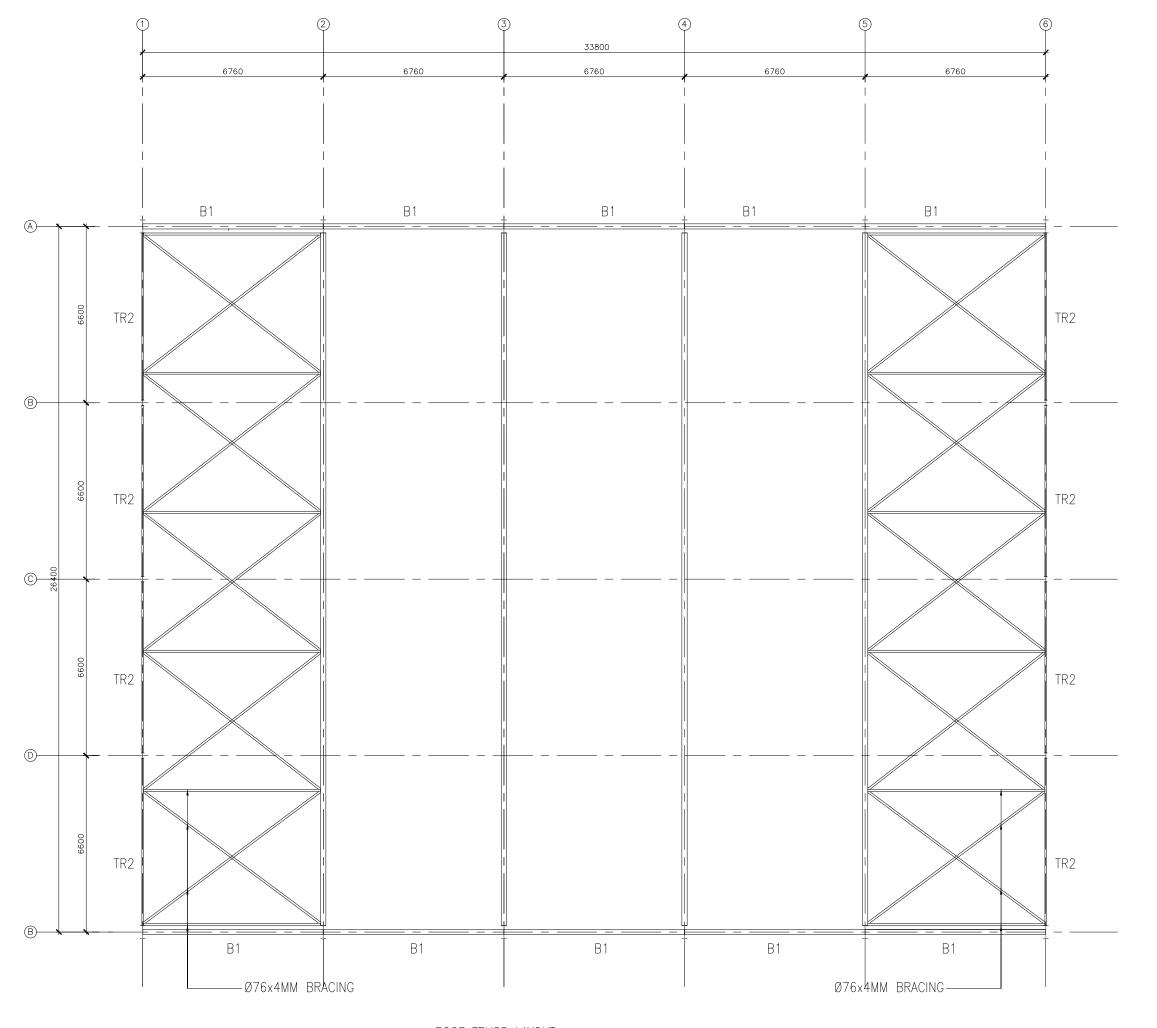


ROOF TRUSS LAYOUT

CLIENT: MINISTRY OF YOUTH, SPORTS & COMMUNITY EMPOWERMENT

DESIGN AND CONSULTANCY:



 KEY PLAN:



WARNING:

- This drawing shall not be used for construction unless certified.
 Contractor to verify all dimensions of existing works.

- dimensions of existing works on site before commencing any work or preparing shop drawings.

 Do not scale drawings, use written dimensions only.

 This drawing is to be read in conjunction with the specifications and conditions of contract.

 This drawing and design is copyright and no portion may be reproduced without the permission of the Consultant

	REVISIONS	
NO	DESCRIPTION	DATE

PROJECT:

BADMINGTON COURT (3 COURTS)

- CONCEPT DESIGN
 DESIGN DEVELOPMENT
 TENDER DOCUMENT
- O FOR CONSTRUCTION O AS BUILD DRAWINGS


DE	SIGNATION	NAME	SIGNATURE
DE	SIGNED BY	SIARCH.PVT.LTD	
AR	CHITECT	-	
ST	R. ENGINEER	-	
CH	ECKED	MOHAMED SIRAJ	
DR	AWN	SANKA SUMEDHA	

DICIPLINE:

STRUCTURAL

ROOF TRUSS LAYOUT

CODE	DATE			DWG. NO:
RSD-190	03.03.2022)22	ST03
FORMAT	A1	A2	А3	3103
SCALE	-	1:100	-	ISSUE A
PDF FILE NA	ME:	RSD-	-190	_HSC_ ST03 _A

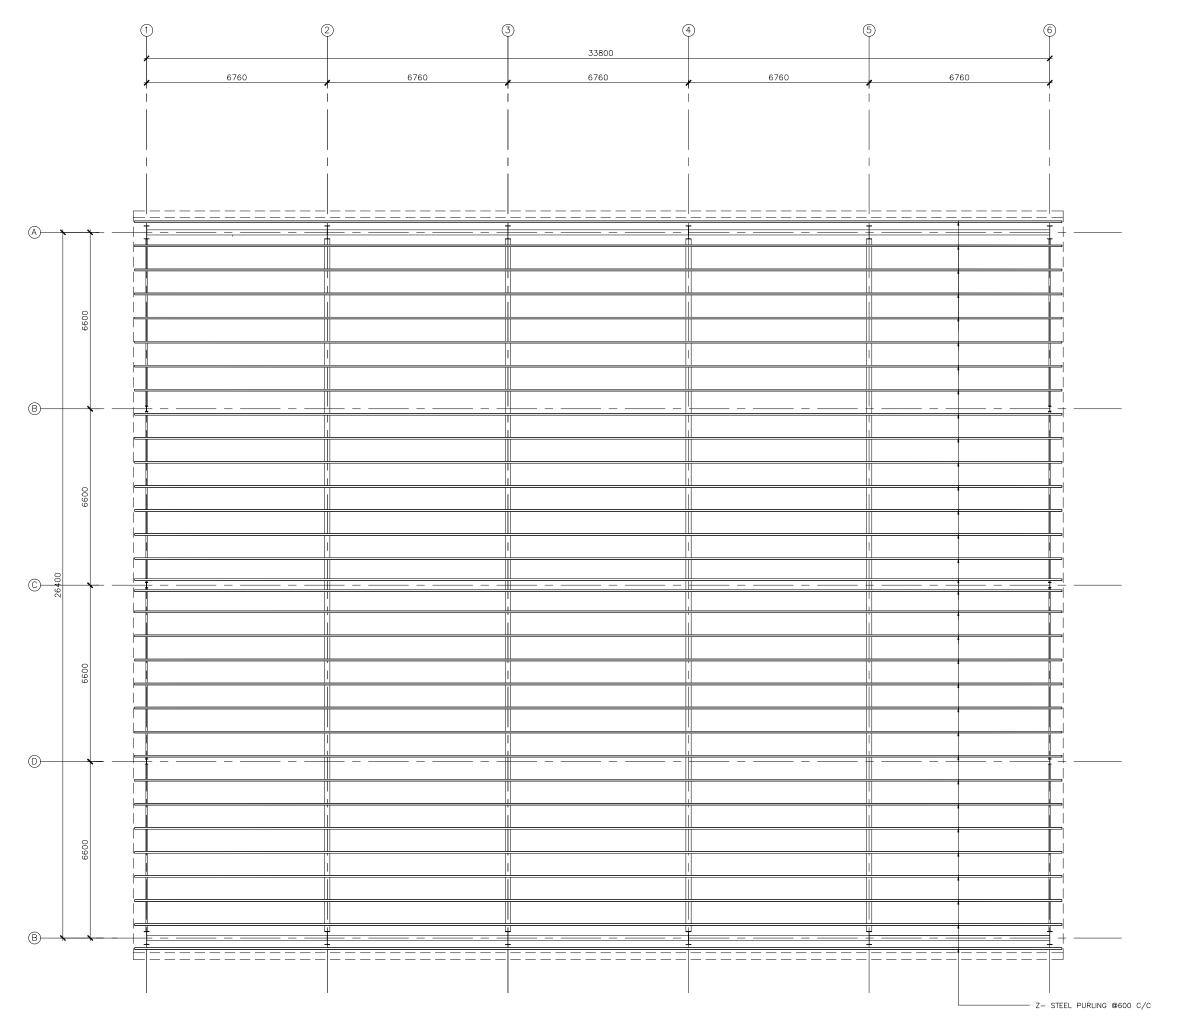


ROOF STRUCTURAL LAYOUT

CLIENT: MINISTRY OF YOUTH, SPORTS & COMMUNITY EMPOWERMENT

DESIGN AND CONSULTANCY:



 KEY PLAN:



WARNING:

- This drawing shall not be used for construction unless certified.
- Contractor to verify all dimensions of existing works on site before commencing any work or preparing shop drawings.
- Do not scale drawings, use written dimensions only.

 This drawing is to be read in conjunction with the specifications and conditions of contract.
- This drawing and design is copyright and no portion may be reproduced without the permission of the Consultant

	REVISIONS	
NO	DESCRIPTION	DATE
		"

PROJECT:

BADMINGTON COURT (3 COURTS)

- CONCEPT DESIGN
 DESIGN DEVELOPMENT
 TENDER DOCUMENT
- O FOR CONSTRUCTION O AS BUILD DRAWINGS


DESIGNATION	NAME	SIGNATURE
DESIGNED BY	SIARCH.PVT.LTD	
ARCHITECT	-	
STR. ENGINEER	-	
CHECKED	MOHAMED SIRAJ	
DRAWN	SANKA SUMEDHA	


DICIPLINE:


STRUCTURAL


ROOF STRUCTURAL LAYOUT


CODE	DATE			DWG. NO:	
RSD-190	03.03.2022)22	ST04	
FORMAT	A1	A2	А3	3107	
SCALE	-	1:100	ı	ISSUE A	
PDF FILE NAME: RSD-190_HSC_ ST04 _A					

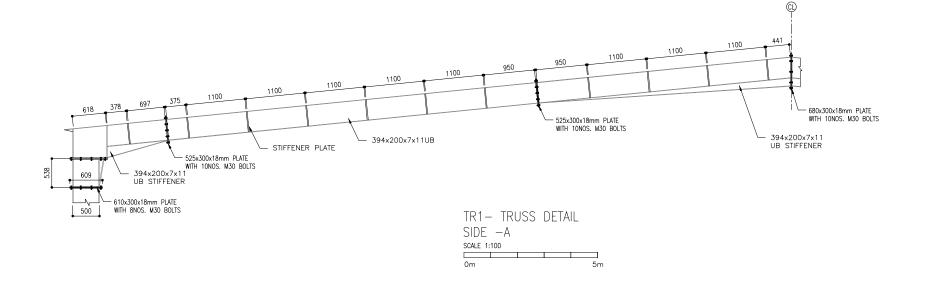


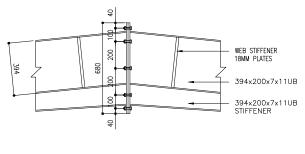


 


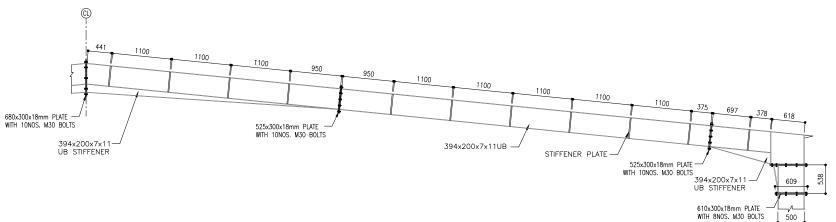

  

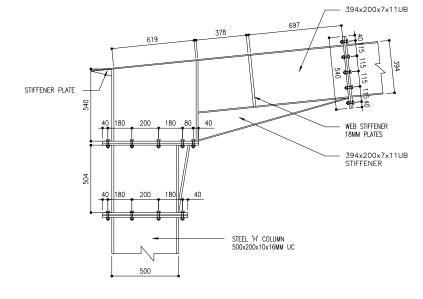




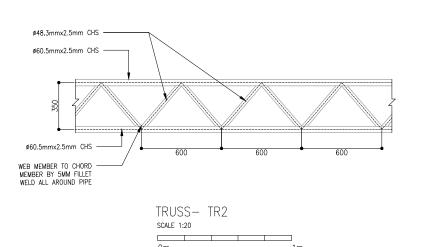

DESIGN AND CONSULTANCY:



 KEY PLAN:



WARNING:

- This drawing shall not be used for construction unless certified.
 Contractor to verify all dimensions of existing
- works on site before works on site before commencing any work or preparing shop drawings.

 Do not scale drawings, use written dimensions only.

 This drawing is to be read in conjunction with the
- specifications and
- conditions of contract.

 This drawing and design is copyright and no portion may be reproduced without the permission of the Consultant

	REVISIONS						
NO	DESCRIPTION	DATE					

PROJECT:

BADMINGTON COURT (3 COURTS)

- CONCEPT DESIGN
 DESIGN DEVELOPMENT
 TENDER DOCUMENT
- O FOR CONSTRUCTION O AS BUILD DRAWINGS

DESIGNATION	NAME	SIGNATU
ESIGNED BY	SIARCH.PVT.LTD	
RCHITECT	-	
TR. ENGINEER	-	
CHECKED	MOHAMED SIRAJ	


SANKA SUMEDHA

DICIPLINE:

STRUCTURAL

ROOF STRUCTURAL DETAIL


CODE	DATE			DWG. NO:			
RSD-190	03.03.2022)22	ST05			
FORMAT	A1	A2	А3	3103			
SCALE	-	1:50 1:20	-	ISSUE A			
PDF FILE NAME: RSD-190_HSC_ ST05 _A							

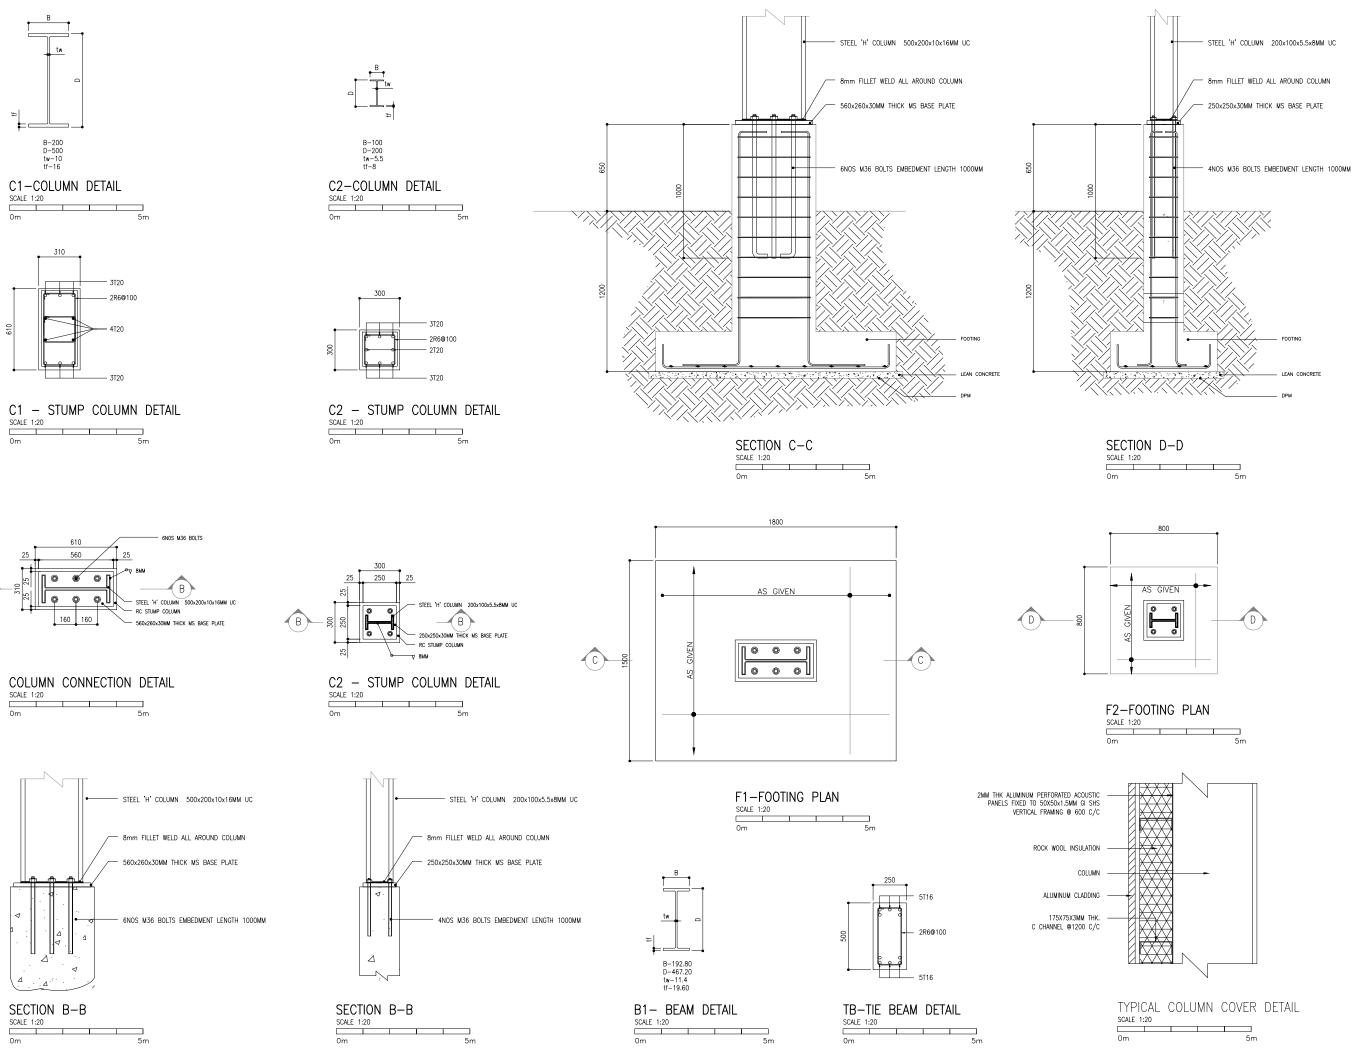

DESIGN AND CONSULTANCY:



 KEY PLAN:



WARNING:

- This drawing shall not be used for construction unless certified. Contractor to verify all dimensions of existing
- works on site before commencing any work or preparing shop drawings. Do not scale drawings, use written dimensions only.
- This drawing is to be read in conjunction with the specifications and conditions of contract.
- This drawing and design is copyright and no portion may be reproduced without the permission of the Consultant

	REVISIONS							
NO	DESCRIPTION	DATE						
		1						

PROJECT:

BADMINGTON COURT (3 COURTS)

- CONCEPT DESIGNDESIGN DEVELOPMENT
- O TENDER DOCUMENT
- O FOR CONSTRUCTION

DECIC	MATIC	INI	NAME
0	AS	BUILD	DRAWING
	1 01		31110011011


DESIGNATION	NAME	SIGNATUR
DESIGNED BY	SIARCH.PVT.LTD	
ARCHITECT	-	
STR. ENGINEER	-	
CHECKED	MOHAMED SIRAJ	
DRAWN	SANKA SUMEDHA	

DICIPLINE:

STRUCTURAL

STRUCTURAL DETAIL

CODE	DATE			DWG. NO:		
RSD-190	03.03.2022			ST06		
FORMAT	A1	A2	А3	3100		
SCALE	-	1:20	-	ISSUE A		
PDF FILE NAME: RSD-190_HSC_ ST06 _A						

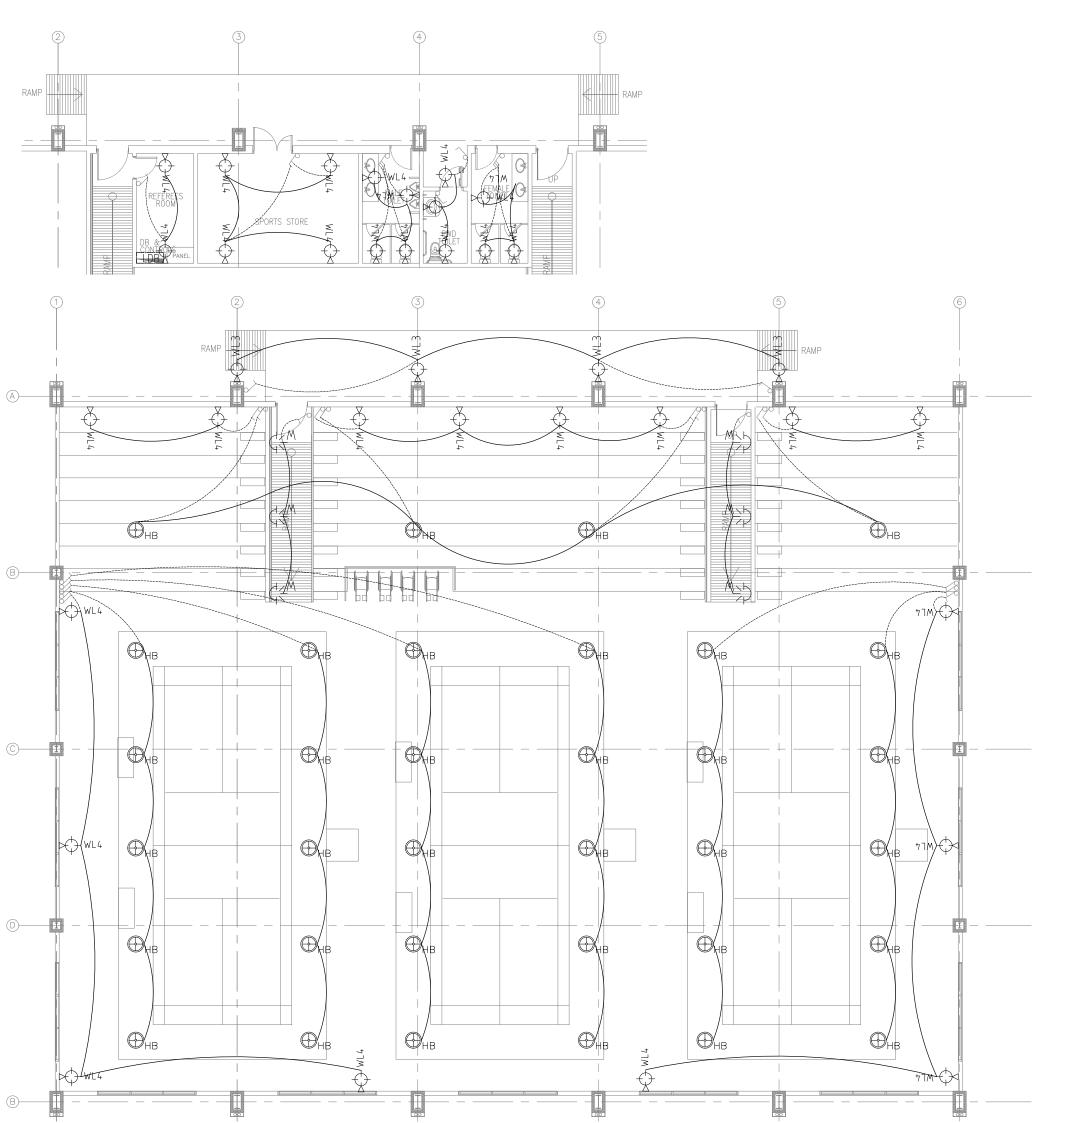

LEGEND:


SYMBOLS	B DESCRIPTION
<u> </u>	LIGHT D BOARD
	LED Light Panel 300x300mm
Ç≤M	FOOT LIGHT WEATHERPROOF
⊕нв	HIGH BAY LIGHT
⊳⇒ WL3	WALL MOUNT LIGHT WEATHERPROOF
₩L4	WALL MOUNT LIGHT INDOOR LIGHT
\rightarrow	01 GANG SWITCH
\frac{1}{2}	02 GANG SWITCH
O'JII	03 GANG SWITCH

CLIENT: MINISTRY OF YOUTH,
SPORTS & COMMUNITY EMPOWERMENT

DESIGN AND CONSULTANCY:



 KEY PLAN:



WARNING:

- This drawing shall not be used for construction unless certified.
 Contractor to verify all dimensions of existing
- works on site before works on site before commencing any work or preparing shop drawings.

 Do not scale drowings, use written dimensions only.

 This drawing is to be read in conjunction with the

specifications and

specifications and conditions of contract.

This drawing and design is copyright and no portion may be reproduced without the permission of the Consultant

	REVISIONS							
10	DESCRIPTION	DATE						

PROJECT:

BADMINGTON COURT (3 COURTS)

PHASE:

- CONCEPT DESIGN
 DESIGN DEVELOPMENT
 TENDER DOCUMENT
- O FOR CONSTRUCTION
- O AS BUILD DRAWINGS

DESIGNATION	NAME	SIGNATUR
DESIGNED BY	SIARCH.PVT.LTD	
ARCHITECT	-	
STR. ENGINEER	-	
CHECKED	MOHAMED SIRAJ	
DRAWN	SANKA SUMEDHA	

DICIPLINE:

MEP


LIGHTING LAYOUT

CODE		DATE		DWG. NO:		
RSD-190	03.03.2022		022	LT01		
FORMAT	A1	A2	А3	LIUI		
SCALE	-	1:100	-	ISSUE A		
PDF FILE NAME: PSD_100 HSC LT01 A						

LIGHTING PLAN

SCALE 1:200

Ωm			5,

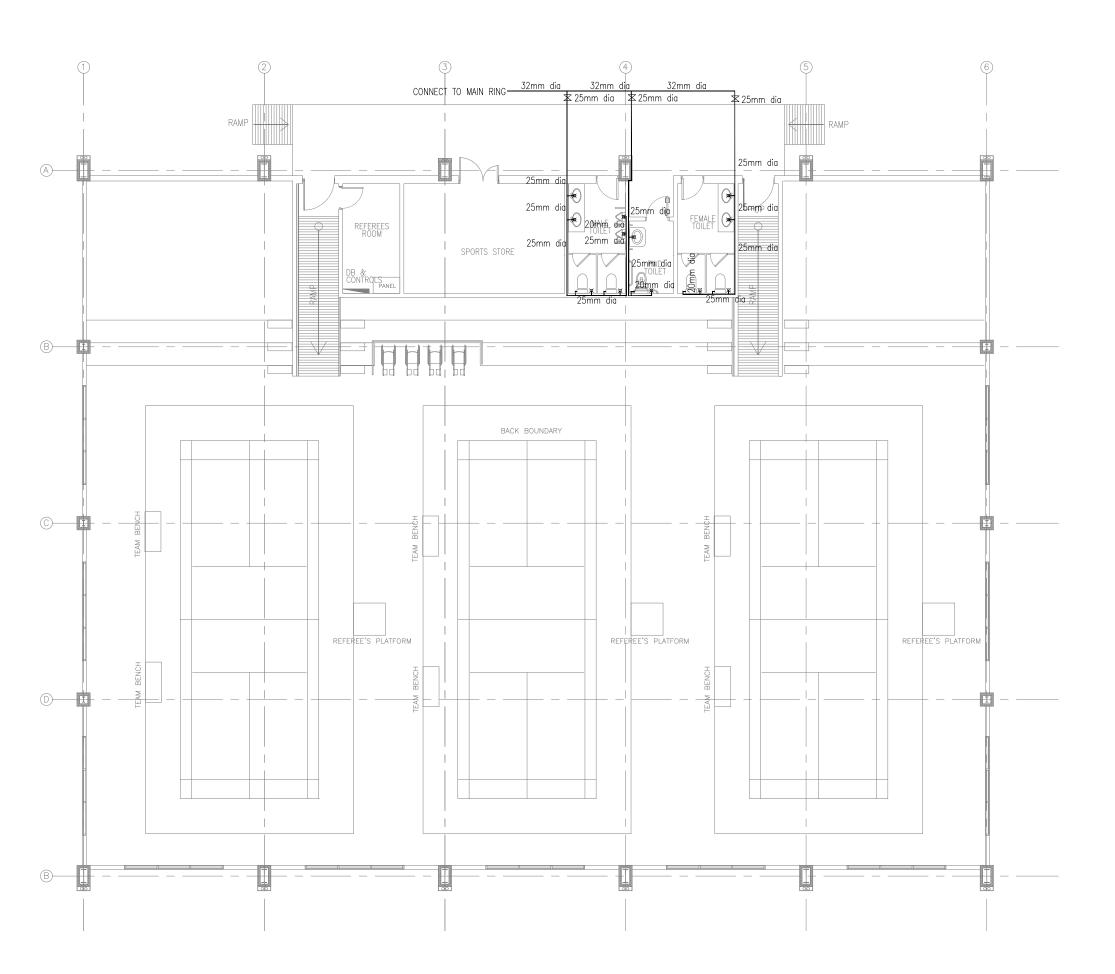

WATER SUPPLY PLAN

SCALE 1:200



LEGEND TABLE

Water Taps

¤∫¤ Water Mixer

Butterfly valve

PPR Pipes



CLIENT: MINISTRY OF YOUTH, SPORTS & COMMUNITY

EMPOWERMENT

KEY PLAN:



WARNING:

- This drawing shall not be used for construction unless certified.
 Contractor to verify all dimensions of existing
- works on site before works on site before commencing any work or preparing shop drawings.

 Do not scale drowings, use written dimensions only.

 This drawing is to be read in conjunction with the
- specifications and
- specifications and conditions of contract.

 This drawing and design is copyright and no portion may be reproduced without the permission of the Consultant

REVISIONS								
NO	DESCRIPTION	DATE						

PROJECT:

BADMINGTON COURT (3 COURTS)

PHASE:

- CONCEPT DESIGN
 DESIGN DEVELOPMENT
 TENDER DOCUMENT
- O FOR CONSTRUCTION
- O AS BUILD DRAWINGS


DESIGNATION	NAME	SIGNATUR
DESIGNED BY	SIARCH.PVT.LTD	
ARCHITECT	-	
STR. ENGINEER	-	
CHECKED	MOHAMED SIRAJ	
DRAWN	SANKA SUMEDHA	

DICIPLINE:

MEP

WATER SUPPLY LAYOUT


CODE	DATE			DWG. NO:		
RSD-190	03.03.2022)22	WS01		
FORMAT	A1	A2	А3	11301		
SCALE	-	1:100	-	ISSUE A		
PDF FILE NAME: RSD-190_HSC_ WS01_A						

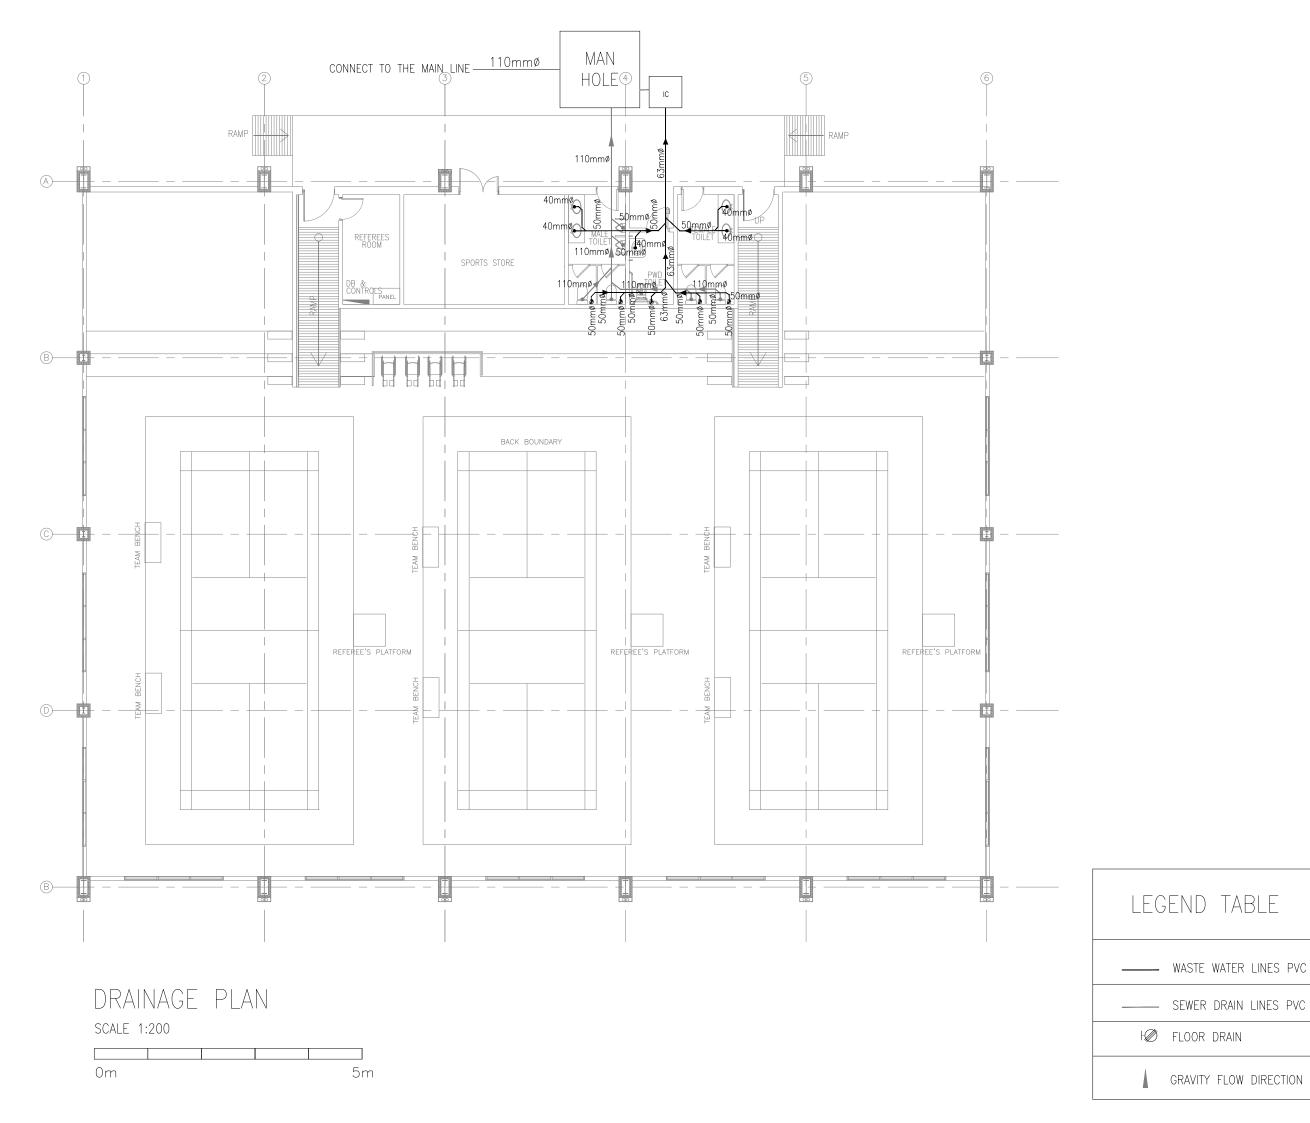

DESIGN AND CONSULTANCY:



 KEY PLAN:



WARNING:

- This drawing shall not be used for construction unless certified.
 Contractor to verify all dimensions of existing
- works on site before works on site before commencing any work or preparing shop drawings.

 Do not scale drawings, use written dimensions only.

 This drawing is to be read in conjunction with the
- specifications and
- specifications and conditions of contract.

 This drawing and design is copyright and no portion may be reproduced without the permission of the Consultant

	REVISIONS		
NO	DESCRIPTION	DATE	

PROJECT:

BADMINGTON COURT (3 COURTS)

PHASE:

- CONCEPT DESIGN
 DESIGN DEVELOPMENT
 TENDER DOCUMENT
- O FOR CONSTRUCTION
- AS BUILD DRAWINGS

DESIGNATION	NAME	SIGNATU
DESIGNED BY	SIARCH.PVT.LTD	
ARCHITECT	-	
STR. ENGINEER	-	
CHECKED	MOHAMED SIRAJ	
DRAWN	SANKA SUMEDHA	

DICIPLINE:

MEP

DRAINAGE LAYOUT

CODE	DATE			DWG. NO:	
RSD-190	03.03.2022)22	DR01	
FORMAT	A1	A2	А3	DIVOT	
SCALE	-	1:100	-	ISSUE A	
DE FILE NAME: DOD 100 HOC DR01 A					