


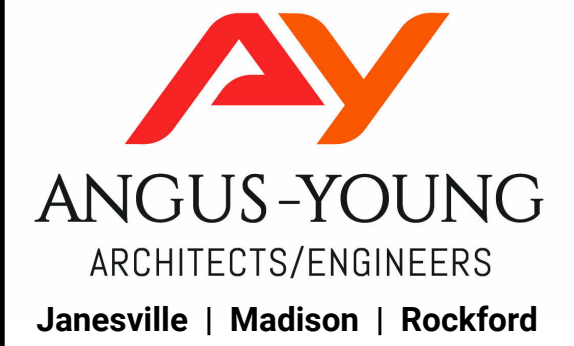

TOWN OF OREGON

TOWN HALL HVAC UPGRADES

1138 UNION ROAD
OREGON, WI 53575

[illegible]

Due to electronic distribution, this drawing may not be printed to the scale indicated on the drawings. Do NOT use scale to determine dimensions or sizes.

No part of this drawing may be used or reproduced in any form or by any means, or stored in a database or retrieval system, without prior written permission.

ANGUS - YOUNG ASSOCIATES, INC.
Copyright © 2026 All Rights Reserved

PROJECT NUMBER
83390

APPROVED BY
SJG

REVIEWED BY
SJG

DRAWN BY
GAA

FIRST FLOOR HYDRONIC PLAN



M201

KEYNOTES

- | | |
|----|---|
| 01 | MECHANICAL CONTRACTOR SHALL SIZE ALL REFRIGERANT PIPING PER MANUFACTURERS REQUIREMENTS. MAINTAIN MANUFACTURER REQUIRED CLEARANCES FOR ALL UNITS. |
| 02 | MECHANICAL CONTRACTOR SHALL ROUTE CONDENSATE TO NEAREST OPEN SITE OR FLOOR DRAIN. PROVIDE CONDENSATE PUMP AS NECESSARY. |
| 03 | LINE SET COVER, RECTORSEAL OR SIMILAR, SHALL BE PROVIDED FOR ALL REFRIGERANT PIPING ROUTED ON EXTERIOR OF THE BUILDING OR EXPOSED WITHIN FINISHED SPACES. |

SHEET NOTES:

1. PROVIDE OWNER WITH OPERATION AND MAINTENANCE MANUALS, TESTING AND BALANCING REPORTS UPON JOB COMPLETION. THE AGENCY RESPONSIBLE FOR BALANCING AND THE VERIFICATION OF THE COMPLETION OF THE PROJECT SHALL BE THE SAME. THE AGENCY SHALL BE PROVIDED AND DISTRIBUTED AND SHALL RETAIN A COPY OF THE DOCUMENT ON SITE, AND SHALL BE MADE AVAILABLE TO THE STATE DEPT. OF SAFETY UPON REQUEST.
02. RECTANGULAR DUCTWORK SHALL BE CONSTRUCTED TO MEET ALL FUNCTIONAL CRITERIA DEFINED IN SECTION VII OF THE SMACNA HVAC DUCT CONSTRUCTION STANDARDS MATERIAL AND FLEXIBLE; LATEST EDITION, AND COMPLY WITH ALL LOCAL, STATE AND FEDERAL CODE REQUIREMENTS.
03. ROUND DUCTWORK SHALL BE UNITED SHEET METAL SPIRAL, UNSEAL DUCT MANUFACTURED FROM GALVANIZED STEEL, MEETING ASTM A-577-71, AND REMOVABLE HIGH PRESSURE REQUIREMENTS. CONSTRUCTED PER SMACNA HVAC DUCT CONSTRUCTION STANDARDS, SECTION III, SPIRAL SEAM CONSTRUCTION, GAUGES AND FITTINGS PER SMACNA DUCT CONSTRUCTION STANDARDS.
04. RETURN DUCT AND TRANSFER DUCT TO MEET OPERATING PRESSURE CRITERIA OF 2 "W.G. MAXIMUM PRESSURE. MAIN DUCT RUNS SHALL MEET OPERATING PRESSURE CRITERIA OF 4 " W.G. MAXIMUM PRESSURE.
05. DUCTWORK INCLUDING SUPPLY, EXHAUST AND RETURN, SHALL BE SEALED PER SMACNA "CLASS A OR B" REQUIREMENTS.
06. FLEXIBLE DUCT FOR AIR CONDITIONING SHALL BE FACTORY PRE-INSULATED WITH 3/4" POUND DENSITY FIBERGLASS SHEATHING IN A VINYL VAPOR BARRIER, CLASS 1 UL-RATED. FLEXIBLE DUCT TO MEET SMACNA FORM NM-H. FLEXIBLE DUCT NOT TO EXCEED 3' IN LENGTH.
07. DUCT DIMENSIONS SHOWN ARE SHEET METAL DIMENSIONS.
08. ACTUAL LOCATION OF GRILLES AND DIFFUSERS SHALL BE COORDINATED WITH REFLECTED CEILING PLAN, IF THERE ARE ANY DISCREPANCIES VERIFY FINAL LOCATION WITH ARCHITECT/ENGINEER.
09. ALL CONCEALED SUPPLY DUCTWORK SHALL BE INSULATED WITH A MIN. OF 2 " INSULATION (R-6) DUCT WRAP.
10. ALL EQUIPMENT TO COMPLY WITH APPLICABLE ASTM/UL/NFPA/ANSI STANDARDS.
11. CONTRACTOR TO COORDINATE WITH ALL TRADES.
12. INSTALL THERMOSTATS/SENSORS NEXT TO AND AT SAME HEIGHT AS LIGHT SWITCHES, UNLESS OTHERWISE NOTED.
13. A QUALIFIED THIRD-PARTY AGENT MUST BALANCE SYSTEM UPON COMPLETION OF PROJECT TO 10% OF THE DESIGNED AIRFLOW.
14. REFRIGERANT PIPING SHALL BE SEAMLESS COPPER TYPE "K", CONFORMING TO ANSI STANDARD B36.10 AND B31.1. REFRIGERANT SUCTION PIPING SHALL BE INSULATED WITH FLEXIBLE ELASTOMERIC FOAM INSULATION, MANUFACTURED IN ACCORDANCE WITH ASTM C-434, TYPE (T) TUBING, TYPE II (SHEETS), AND SHALL HAVE A FLAME AND SMOKE RESISTANT 2550, THICKNESS SHALL BE 1/2" INCH UNLESS OTHERWISE NOTED. APPROVED PRODUCTS ARE ARMAFLEX AND RUBATEX.
15. 2 " RIGID INSULATION SHALL BE PROVIDED AT THE PLENUM OF LOUVERS, PROVIDE SIXTEEN GAUGE 12 X 12 MESH BIR SCREEN WITH A REMOVABLE FRAME INSTALLED AT THE INNER FACE OF THE LOUVER.

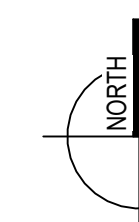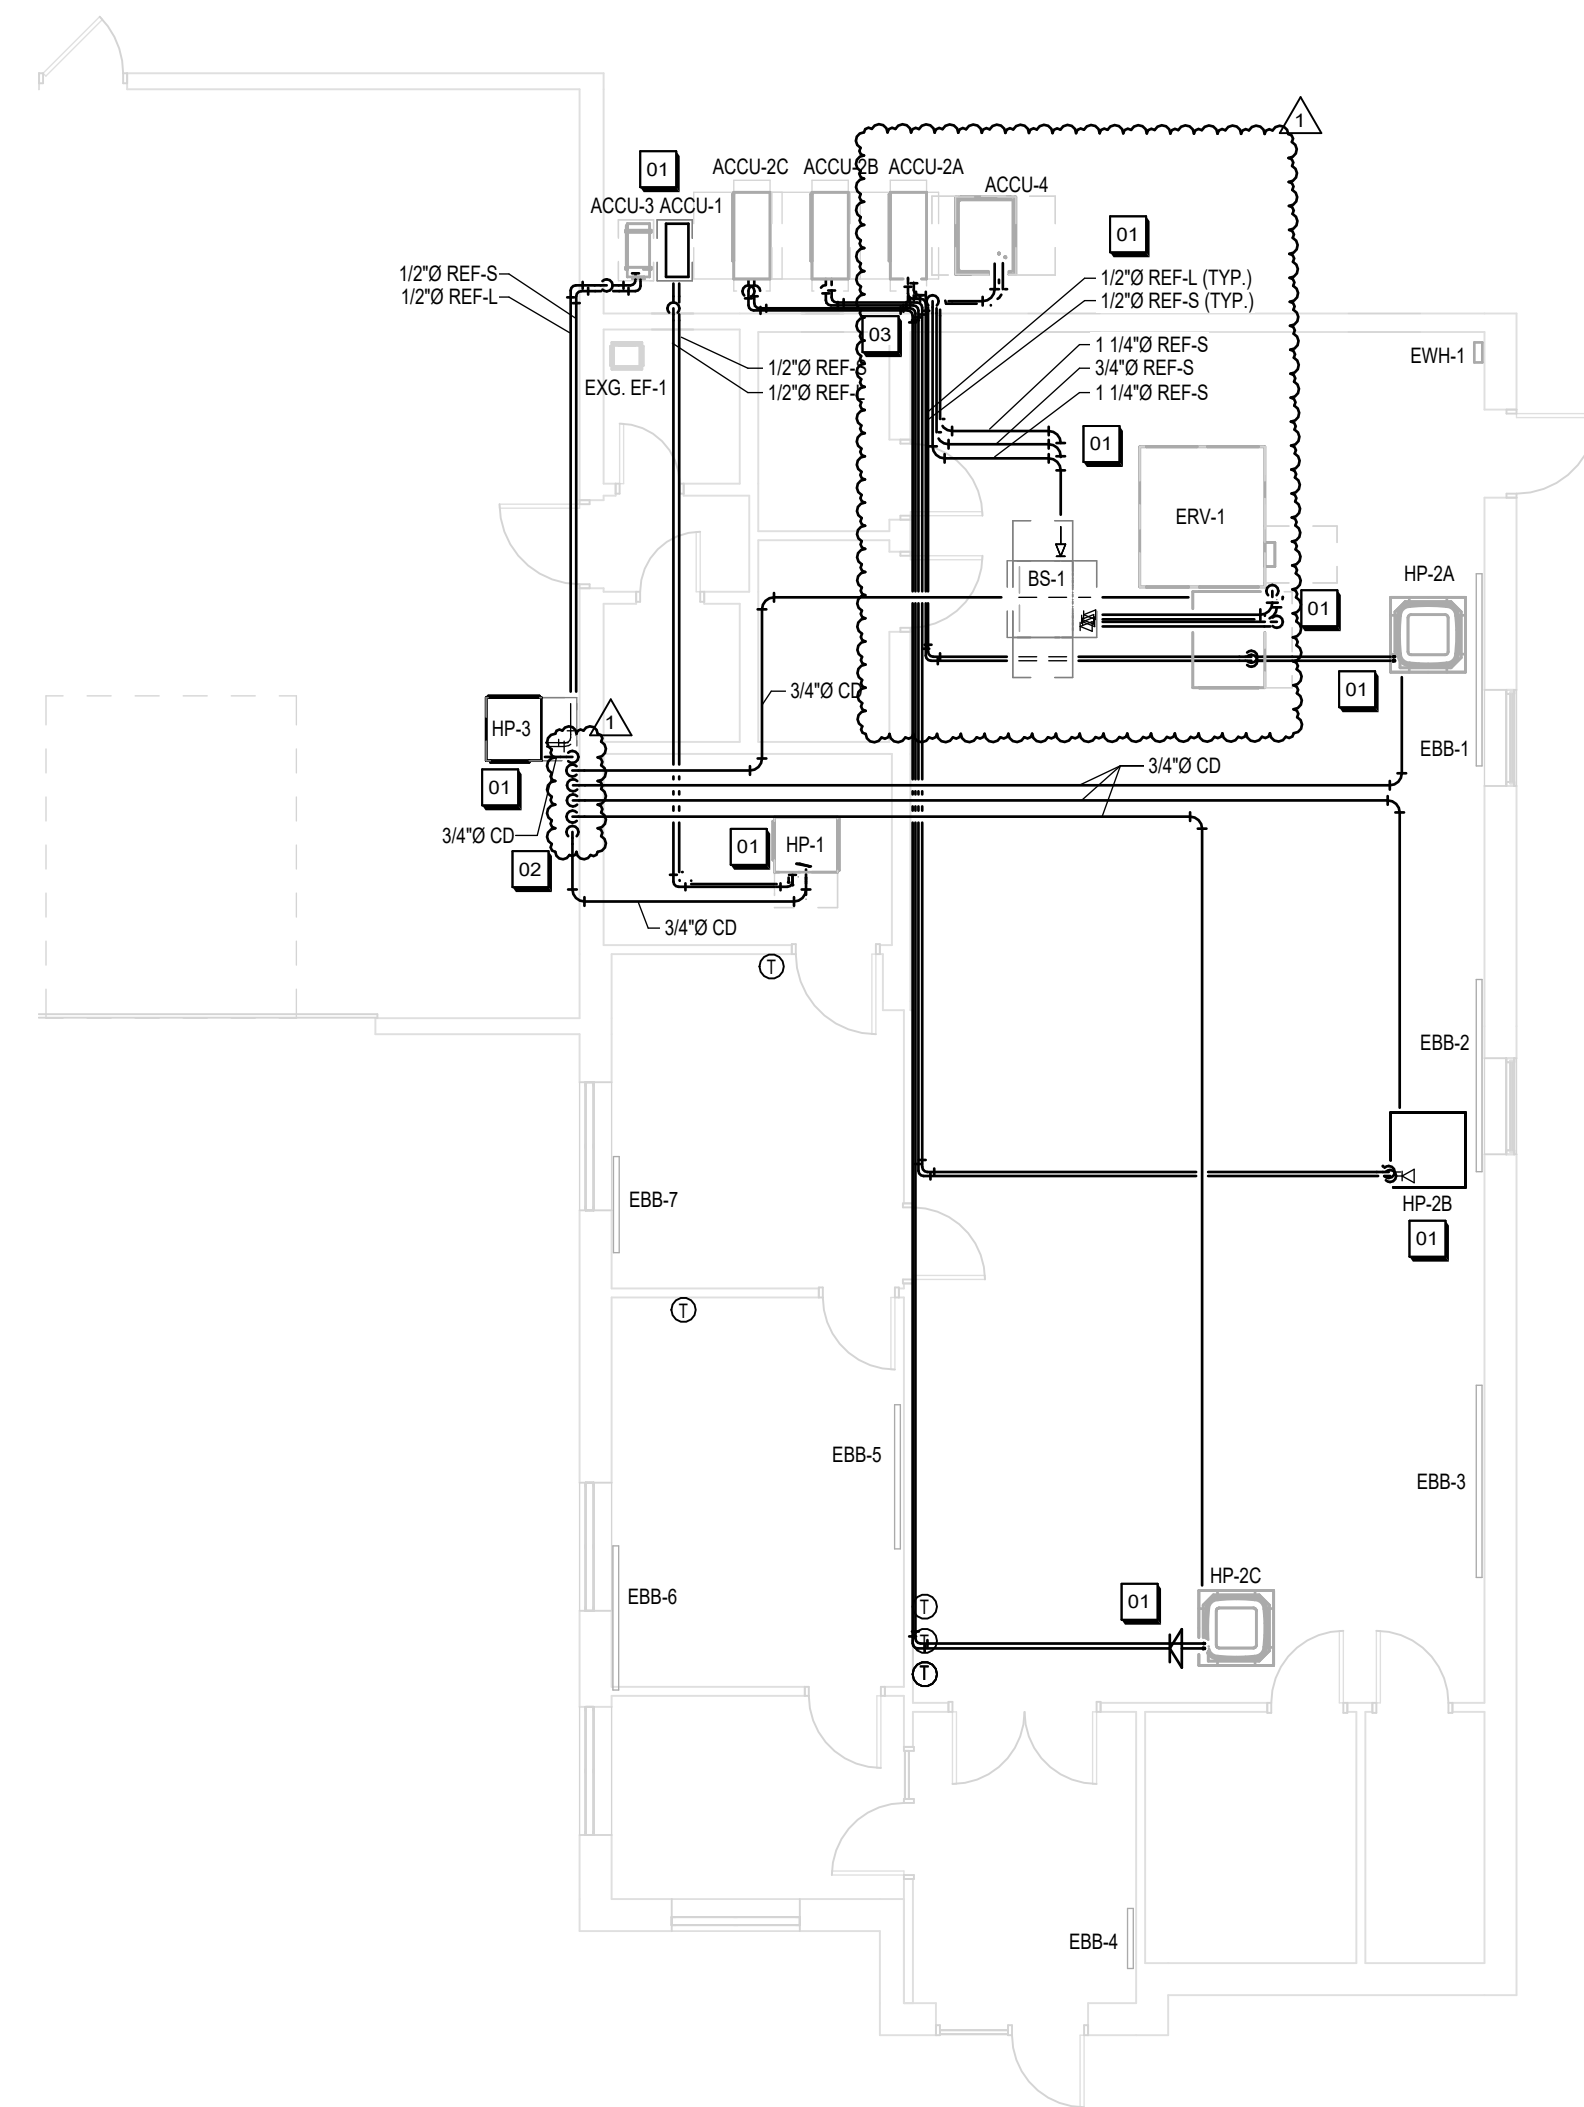

FIRST FLOOR NEW MECHANICAL PIPING PLAN

SCALE: 1/8" = 1'-0"

C:\Revit\Local\Projects\83390\MM-V2025_ay_galliamm.rvt

Sheet Size: 24" x 36" (Arch D)

ENERGY RECOVERY VENTILATOR				
TAG		ERV-1		
MANUFACTURER		Oxygen8		
MODEL NUMBER		H101N-ERV		
DESIGN CONDITIONS	SUMMER, OUTDOOR		87 / 75	DB/WB
	SUMMER, INDOOR		75 / 50	DB/HUMIDITY %
	WINTER, OUTDOOR		-15 / -16	DB/WB
	WINTER, INDOOR		68 / 20	DB/HUMIDITY %
SUPPLY AIRFLOW RATE		750	CFM	
EXHAUST AIR FLOW RATE		550	CFM	
WHEEL LEAVING AIR CONDITIONS	SUMMER		79.4	DB
			67.6	WB
	WINTER		37.1	DB
			29.7	WB
ELECTRICAL	MINIMUM CIRCUIT AMPS		8.8	A
	MAX. OVER CURRENT PROTECTION		15	A
	MOTOR VOLTAGE		208 / 60 / 1	VOLTS/HERTZ/PHASE
UNIT WEIGHT		224.2	LB	

NOTE: 1. FURNISH BASE VIBRATION ISOLATORS
2. ERV SHALL BE PROVIDED WITH COOLING COIL WITH HOT GAS REHEAT. SEE COIL SCHEDULE.

VARIABLE REFRIGERANT FLOW (VRF) SELECTOR											
TAG	ASSOCIATED OUTDOOR UNIT	# OF PORTS	VOLTS	MCA	MOP	SIZE (H" x W" x D")	REFRIGERANT				MANUFACTURER & MODEL NUMBER
							HI / LO GAS (IN)	LIQUID LINE (IN)	SUCTION LINE (IN)	TYPE	
BS-1	ACCU-4	4	208/1	1.2	15	9.5 x 19.3 x 28.2	1 1/8	5/8	1 1/8	R-32	68 DAIKIN BSF4A54AAVJ

ERV COIL SCHEDULE											
TAG	COIL TYPE	REFRIGERANT COIL						MAX. AIR FRICTION	MANUFACTURER & MODEL NUMBER		
		EAT (DB/WB)	LAT (DB/WB)	MBH							
ERV COOLING COIL	REFRIGERANT	R-32	79.4 / 67.6	52.37 / 51.25	36.16	0.24			DAIKIN 3DX-04-12.0		
ERV HOT GAS REHEAT COIL	REFRIGERANT	R-32	52.37	70.35	14.09	0.1			DAIKIN 3DC-01-12.0		

AIR COOLED CONDENSING UNIT SCHEDULE											
TAG	SERVING	RATED TONS	EER2	AIRFLOW CFM	NO. OF FANS	AMBIENT TEMP. (DB)	VOLTAGE @ 60HZ	MOP (A)	MIN. CIRCUIT AMPACITY	MANUFACTURER & MODEL NUMBER	
ACCU-1	HP-1	0.75	11.1	1,126	1	95	208 / 1	15	11.6	DAIKIN RXP09AVJU9	
ACCU-2A	HP-2A	3	12.2	3,000	1	95	208 / 1	35	34.6	DAIKIN RZA36AAVJU	
ACCU-2B	HP-2B	3	12.2	3,000	1	95	208 / 1	35	34.6	DAIKIN RZA36AAVJU	
ACCU-2C	HP-2B	3	12.2	3,000	1	95	208 / 1	35	34.6	DAIKIN RZA36AAVJU	
ACCU-3	HP-3	1.5	11.6	2,383	1	95	208 / 1	25	21.4	DAIKIN RXP18AVJU9	
ACCU-4	ERV COIL	6	12.4	6,200	1	95	208 / 3	35	33.0	DAIKIN REYAT2AATJA	

NOTES: 1. EC TO PROVIDE AND INSTALL FUSIBLE DISCONNECT AT UNITS

TAG	SERVES	CFM	SUMMER OUTSIDE AIR (CFM)	COOLING OPERATING RANGE (F)	HEATING OPERATING RANGE (F)	COOLING CAPACITY (MBH)	HEATING CAPACITY (MBH)	REFRIGERANT	ELECTRICAL (VOLTS / PHASE / HERTZ)	MANUFACTURER & MODEL #
HP-1	BACK OFFICE / STORAGE	375	75	50-115	-14-64	9	10.9	R-32	208 / 1 / 60	DAIKIN FDMA09AVJU9
HP-2A	HALL	800	125	23-122	-4-60	36	40	R-32	208 / 1 / 60	DAIKIN FCA36AAVJU
HP-2B	HALL	800	125	23-122	-4-60	36	40	R-32	208 / 1 / 60	DAIKIN FCA36AAVJU
HP-2C	HALL	800	125	23-122	-4-60	36	40	R-32	208 / 1 / 60	DAIKIN FCA36AAVJU
HP-3	FRONT OFFICE / STORAGE	625	15	50-115	-14-64	17.6	21.6	R-32	208 / 1 / 60	DAIKIN FDM18AVJU9

NOTES: 1. ALL UNITS SHALL BE PROVIDED WITH FACTORY INSTALLED DISCONNECT SWITCH.

GRILLE, REGISTER & DIFFUSER SCHEDULE			
TAG	DESCRIPTION	NECK	MANUFACTURER & MODEL NUMBER
R-1	24" x 24" STEEL LAY-IN LOUVERED GRILLE WITH SQUARE NECK	SEE DRAWING	TITUS MODEL 350RL
E-1	12" x 12" STEEL LAY-IN LOUVERED GRILLE WITH SQUARE NECK	SEE DRAWING	TITUS MODEL 350RL
E-2	24" x 24" STEEL LAY-IN LOUVERED GRILLE WITH SQUARE NECK	SEE DRAWING	TITUS MODEL 350RL
S-1	6" ROUND NECK IN 12" x 12" ALL-ALUMINUM PLAQUE FACE DIFFUSER	SEE DRAWING	TITUS MODEL OMNI-AA
S-2	8" ROUND NECK IN 24" x 24" ALL-ALUMINUM PLAQUE FACE DIFFUSER	SEE DRAWING	TITUS MODEL OMNI-AA
S-3	6" ROUND NECK IN 24" x 24" ALL-ALUMINUM PLAQUE FACE DIFFUSER	SEE DRAWING	TITUS MODEL OMNI-AA
S-4	24" x 24" STEEL LAY-IN LOUVERED GRILLE WITH SQUARE NECK	SEE DRAWING	TITUS MODEL 350RL

WALL HEATER SCHEDULE (ELECTRICAL)					
TAG	ROOM LOCATION	WATTS	VOLTS	AMPS	BTU / HR OUTPUT
EVH-1	ATTIC	1,000	240	4.2	3410


NOTES: EQUIPMENT SHALL BE PROVIDED WITH INTEGRAL THERMOSTAT AND LOCAL DISCONNECT SWITCH

BASEBOARD SCHEDULE (ELECTRICAL)					
TAG	ROOM LOCATION	WATTS	VOLTS	LENGTH (FT)	BTU / HR OUTPUT
EBB-1	105 - HALL	2,000	240	8.00	6,824
EBB-2	105 - HALL	2,000	240	8.00	6,824
EBB-3	105 - HALL	2,000	240	8.00	6,824
EBB-4	100 - VESTIBULE	500	240	2.50	1,706
EBB-5	102 - FRONT OFFICE	1500	240	6.00	5,118
EBB-6	102 - FRONT OFFICE	1500	240	6.00	5,118
EBB-7	103 - CLERKS OFFICE	1000	240	4.00	3,412

NOTES: EQUIPMENT SHALL BE PROVIDED WITH INTEGRAL THERMOSTAT


LOUVER SCHEDULE					
TAG	EQUIPMENT SERVED	SIZE W" X H"	FREE AREA (FT ²)	TYPE	CONSTRUCTION
L-1	ERV-1 INTAKE	20" X 20"	1.10	STATIONARY	EXTRUDED ALUMINIUM
L-2	ERV-1 EXHAUST	20" X 20"	1.10	STATIONARY	EXTRUDED ALUMINIUM

NOTES: PROVIDE BACKDRAFT DAMPER WITH EACH LOUVER

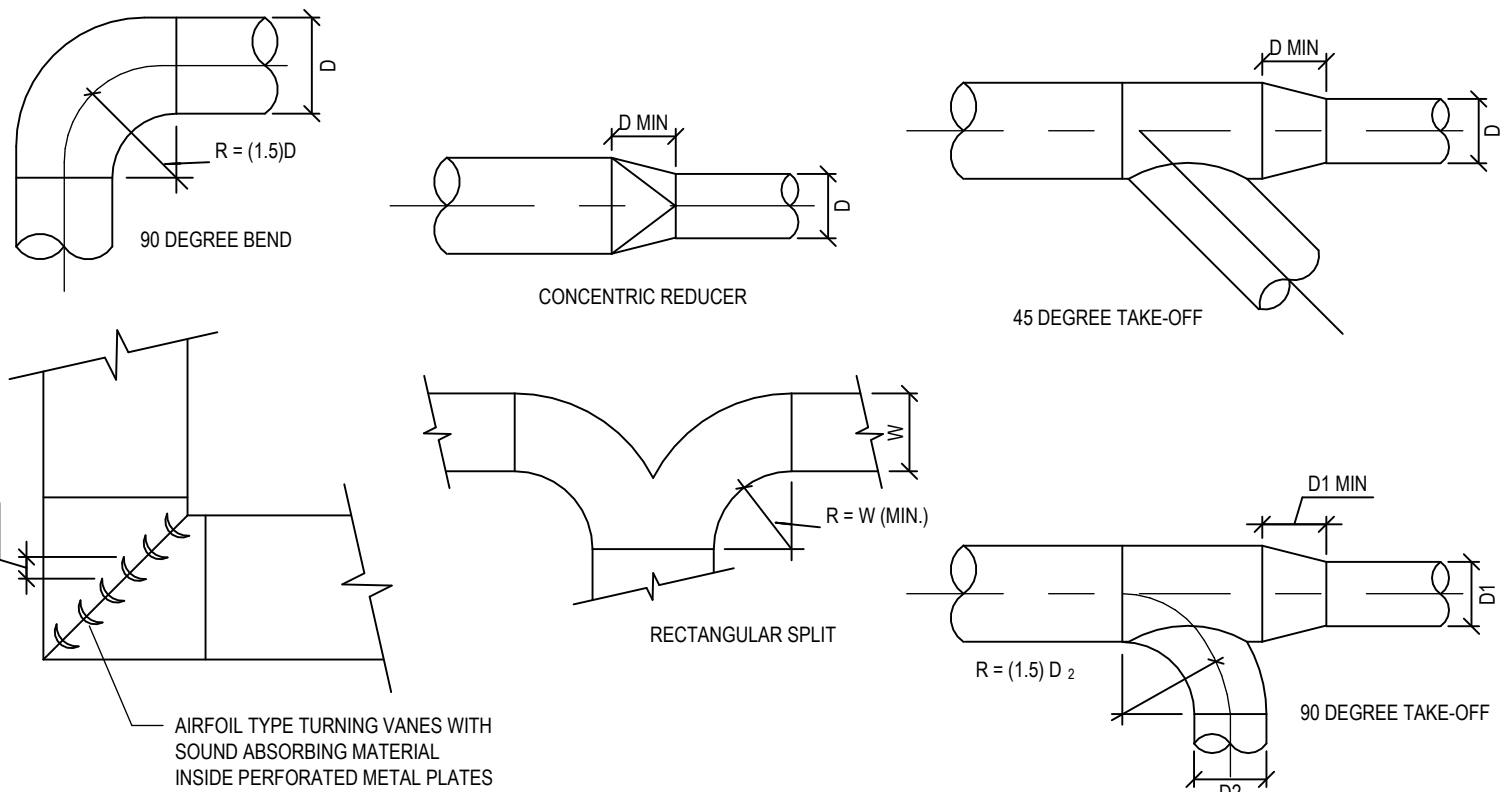

14 M801 TYPICAL DUCT FITTINGS

SCALE: NOT TO SCALE

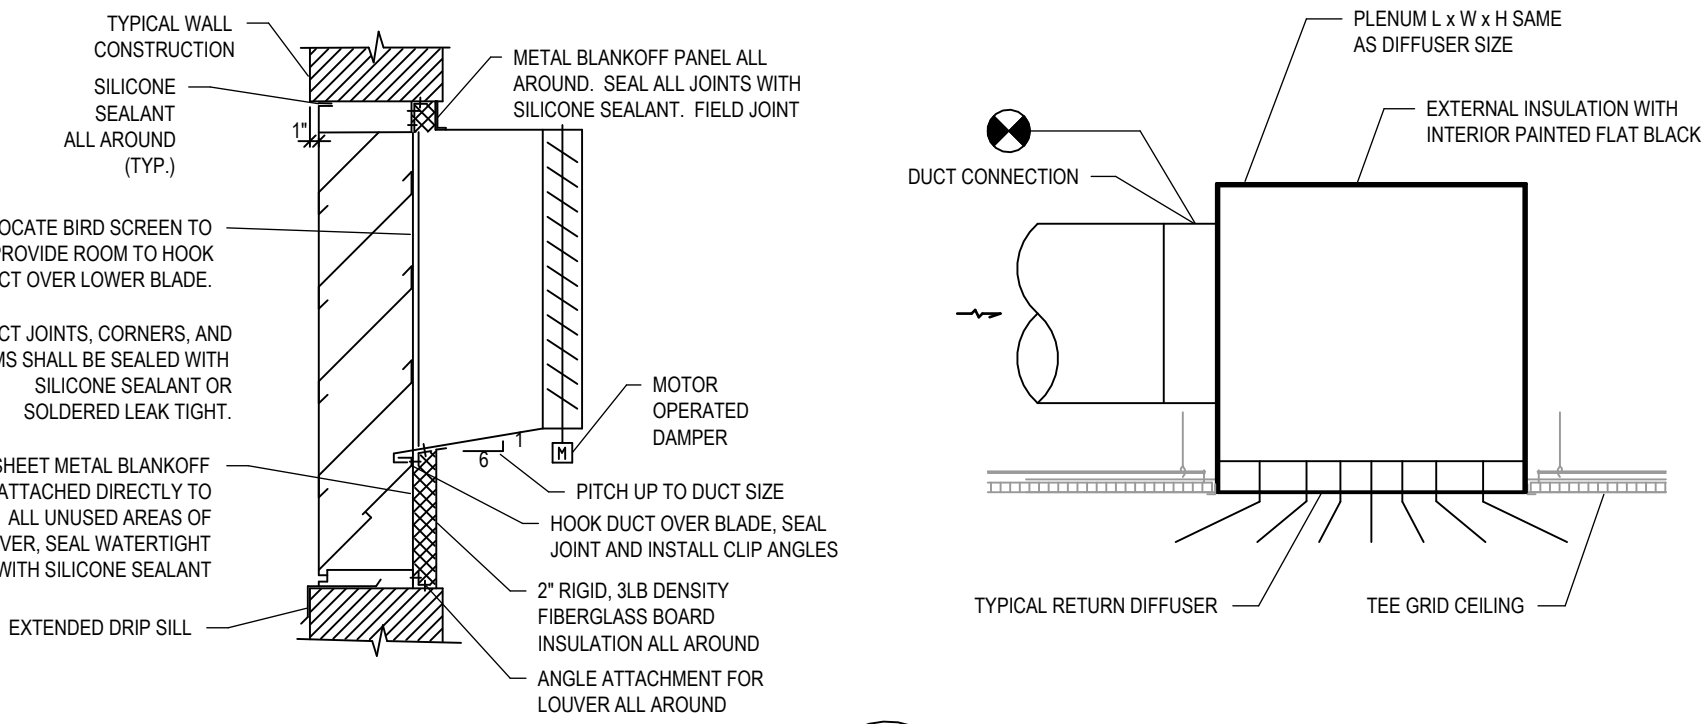


13 M801 LOUVER INSTALLATION DETAIL

SCALE: NOT TO SCALE


09 M801 RETURN DIFFUSER PLENUM DETAIL

SCALE: NOT TO SCALE

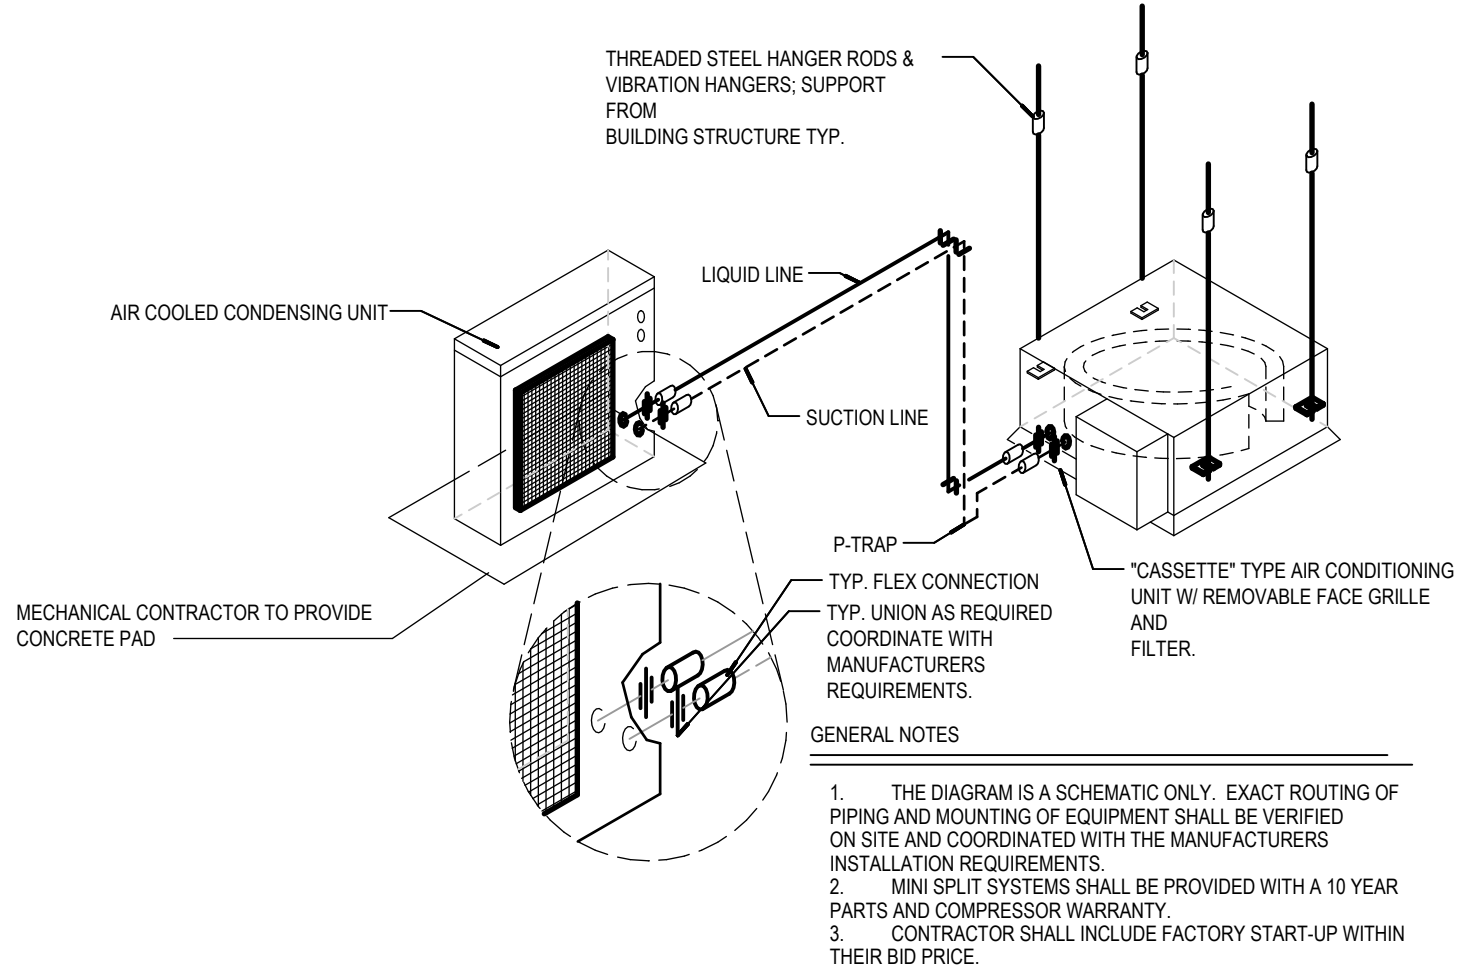

08 M801 MINI SPLIT DETAIL

SCALE: NOT TO SCALE

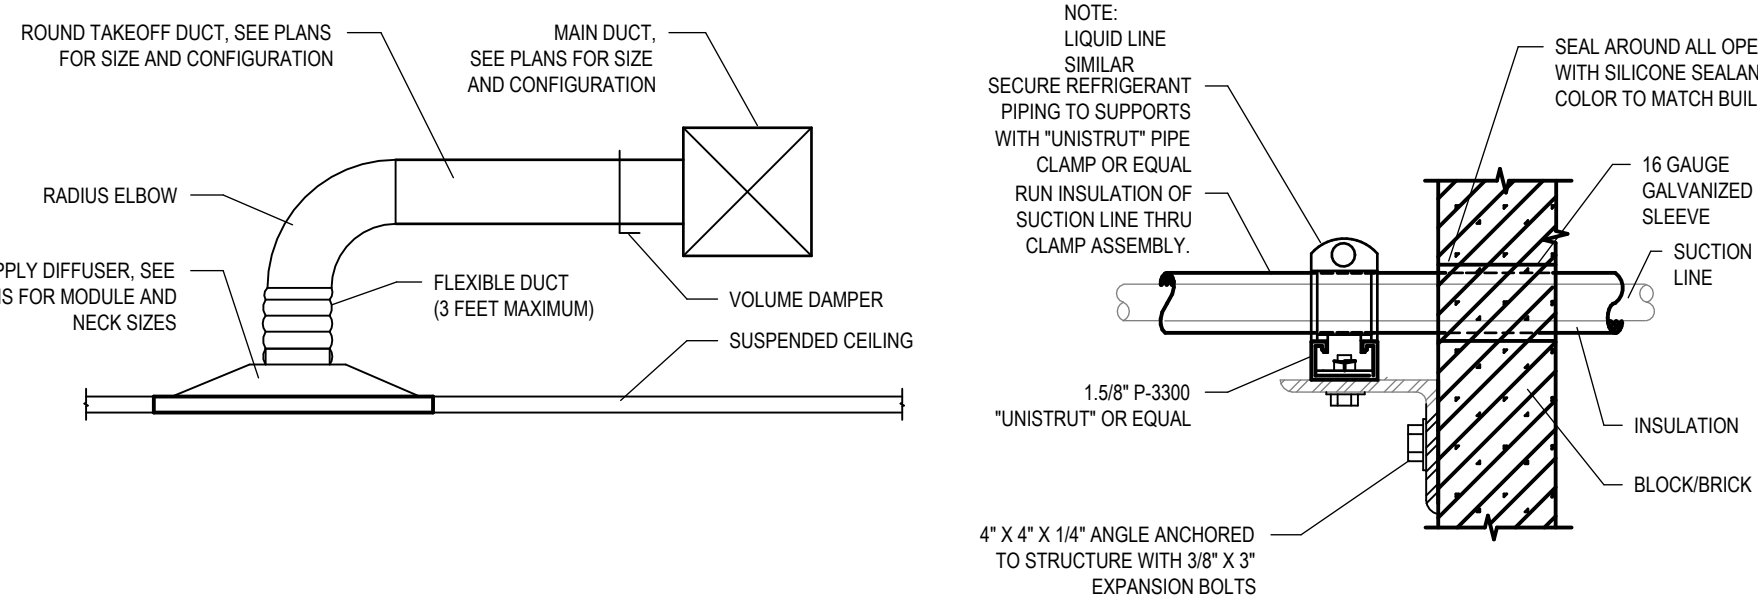


07 M801 TYPICAL SUPPLY DIFFUSER TAKEOFF

SCALE: NOT TO SCALE

03 M801 REFRIGERANT PIPE EXT. WALL PENETRATION

SCALE: NOT TO SCALE

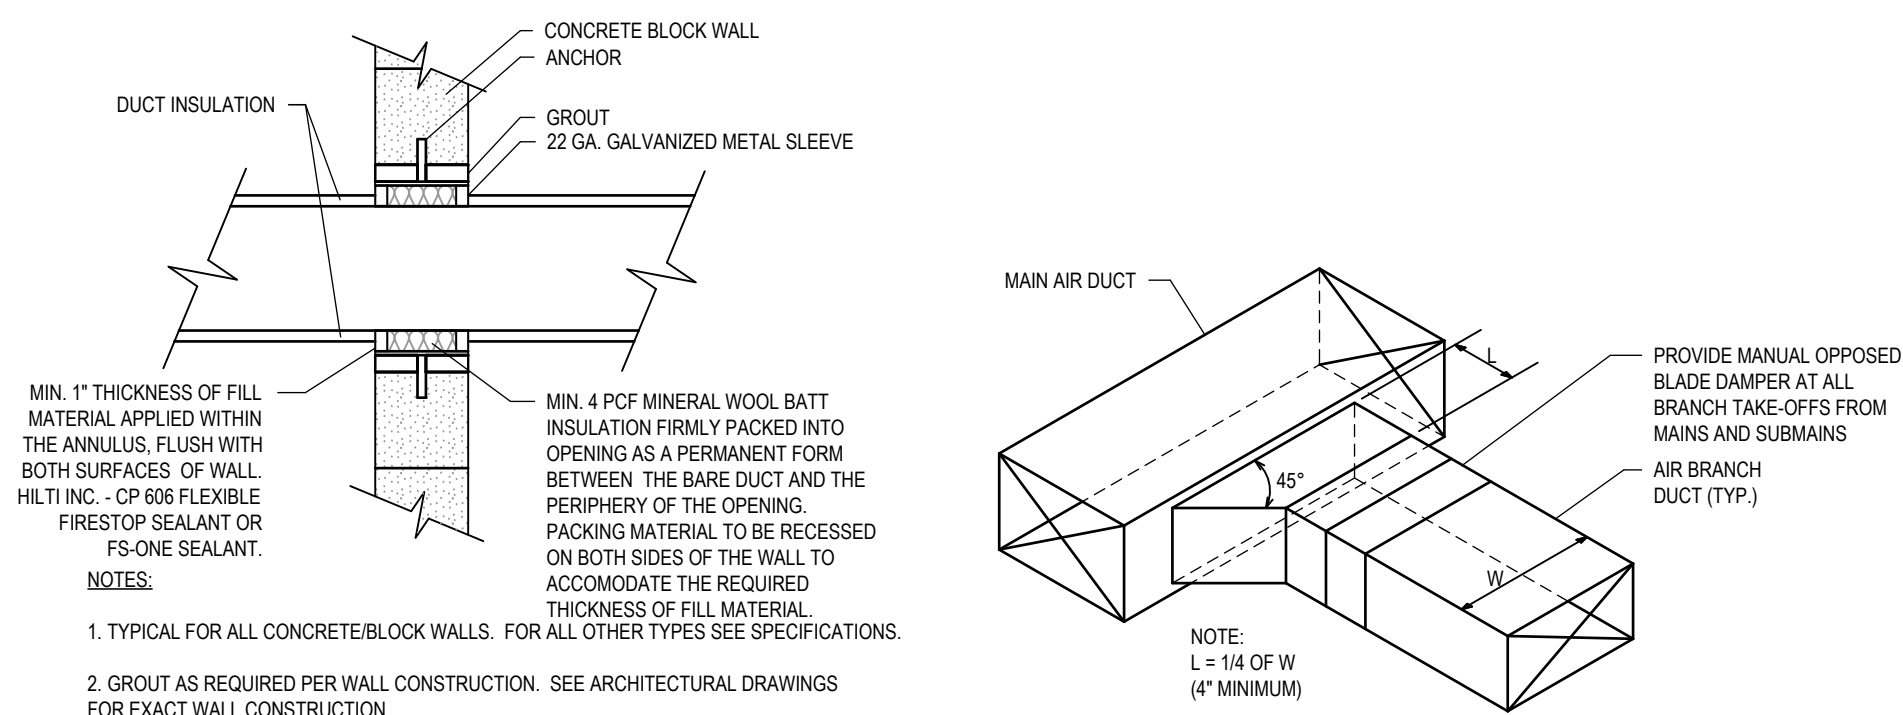


06 M801 DUCT PASSING THROUGH WALL

SCALE: NOT TO SCALE

02 M801 SUPPLY-RETURN AIR DUCT CONNECTION

SCALE: NOT TO SCALE

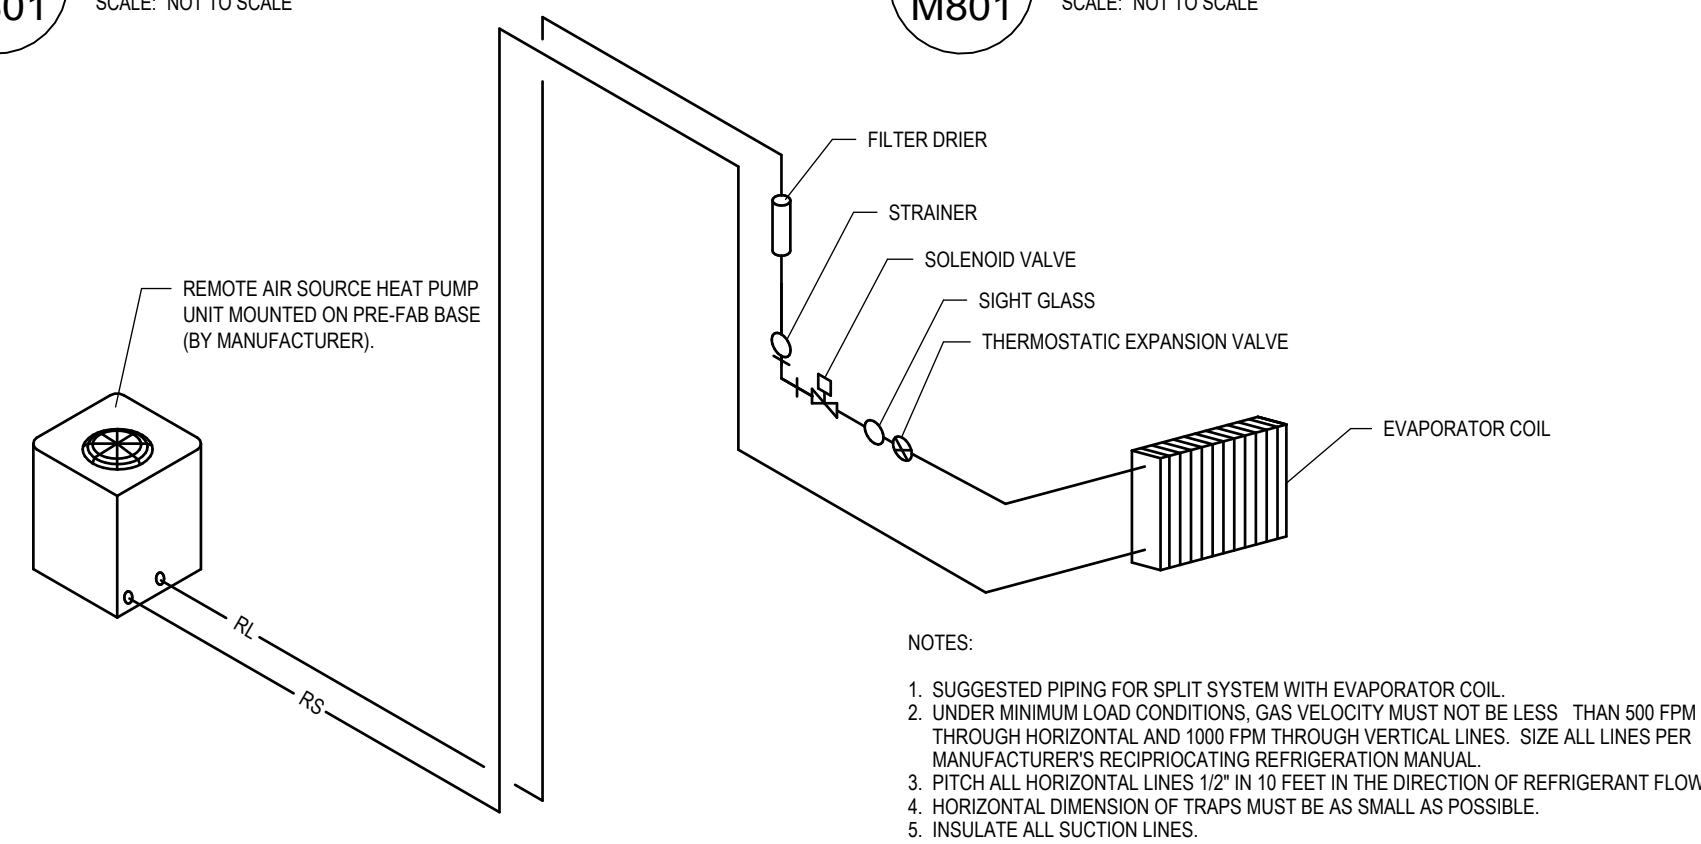

05 M801 REFRIGERANT PIPING DETAIL

SCALE: NOT TO SCALE

TOWN OF OREGON

TOWN HALL HVAC
UPGRADES

1138 UNION ROAD
OREGON, WI 53575

ISSUANCES / REVISIONS		
NO.	DESCRIPTION:	DATE:
	100% OWNER REVIEW	7/21/2026
	BID DRAWINGS	7/21/2026
	ADDENDUM 01	09/01/2026
1	ADDENDUM 02	09/10/2026


Due to electronic distribution, this drawing may not be printed to the scale indicated on the drawings. Do NOT use scale to determine dimensions or sizes.

No part of this drawing may be used or reproduced in any form or by any means, or stored in a database or retrieval system, without prior written permission.

ANGUS - YOUNG ASSOCIATES, INC.
Copyright © 2026 All Rights Reserved


PROJECT NUMBER	83390
APPROVED BY	SJG
REVIEWED BY	SJG
DRAWN BY	AEM
MECHANICAL SCHEDULES AND DETAILS	

 M801

[illegible]

ANGUS - YOUNG ASSOCIATES, INC.
Copyright © 2026 All Rights Reserved

- ## SHEET NOTES:
1. THE BUILDING WILL REMAIN OCCUPIED AND IN USE DURING THE RENOVATION PROCESS. SCHEDULE THE WORK TO MINIMIZE DISRUPTION AND COORDINATE ANY NECESSARY DISRUPTIONS WITH THE OWNER.
 2. THE INFORMATION SHOWN ON THESE DRAWINGS WAS OBTAINED FROM THE ORIGINAL CONSTRUCTION DRAWINGS WHERE AVAILABLE, AND FROM LIMITED FIELD REVIEW OF THE BUILDING AND ITS SYSTEMS. PRIOR TO BIDDING, EACH CONTRACTOR SHALL INVESTIGATE THE EXISTING SYSTEMS TO THE EXTENT NECESSARY TO ACCURATELY DETERMINE THE EXACT EXTENT OF THE REQUIRED WORK.
 3. THE CONTRACTOR'S BID PRICE SHALL INCLUDE THE RESOLUTION OF MINOR DISCREPANCIES AT NO ADDITIONAL COST TO THE OWNER. PRIOR TO BIDDING, EACH CONTRACTOR SHALL REVIEW AND VERIFY ALL EXISTING ELECTRICAL SYSTEMS AND THEIR COMPONENTS AND REPORT ANY SIGNIFICANT DISCREPANCIES FOUND TO THE A/E FOR RESOLUTION. ANY CONTROLLED EQUIPMENT OR COMPONENTS NOT NOTED IN THE PLANS OR SPECS BUT FOUND PRIOR TO OR DURING COMPLETION OF THE NEW WORK SHALL ALSO BE REPORTED TO THE A/E.
 4. THE CONTRACTOR SHALL FIELD VERIFY ACTUAL LOCATION, SIZE, AND CONDITION OF EXISTING BRANCH CIRCUIT RACEWAYS, WIRING, PANEL CAPACITY, BREAKERS, AND DEVICES.
 5. CONTRACTOR SHALL PROTECT ALL WALLS, CEILINGS, FLOORS, LIGHTS AND OTHER FINISHED SURFACES. IF DAMAGED, CONTRACTOR SHALL REPAIR OR REPLACE TO MATCH EXISTING CONDITIONS AT ADDITIONAL COST TO THE OWNER. VERIFY LOCATIONS OF AND PROTECT EXISTING INTERIOR ELECTRICAL AND MECHANICAL UTILITIES AND SERVICES.
 6. DEMOLITION OF AN ITEM SHALL INCLUDE REMOVAL OF ALL RELATED WIRING, HANGERS, SUPPORTS, CONDUIT, AND ACCESSORIES UNLESS NOTED OTHERWISE.
 7. ALL MATERIALS AND EQUIPMENT REMOVED AND NOT REUSED SHALL BECOME THE PROPERTY OF THE CONTRACTOR AND SHALL BE REMOVED FROM THE SITE UNLESS NOTED OTHERWISE. THE OWNER RESERVES THE RIGHT TO SALVAGE PARTS FROM ANY ELECTRICAL EQUIPMENT BEFORE REMOVAL FROM THE SITE.
 8. ANY ELECTRICAL EQUIPMENT FOUND TO BE NON-FUNCTIONAL, OR IN NEED OF REPAIR OR MAINTENANCE WORK SHALL BE REPORTED TO THE A/E AND THE OWNER.
 9. ALL RACEWAY TO BE CONCEALED IN WALLS OR ABOVE CEILING UNLESS APPROVED BY THE A/E PRIOR TO INSTALLATION. IN EXPOSED CEILING AREAS, CONDUIT IS TO BE PAINTED TO MATCH.
 10. LABEL "7" AND DASHED LINE INDICATES DISCONNECT AND REMOVE, UNLESS NOTED OTHERWISE. "E" OR "ET" INDICATES REQUIRED TO REMAIN. DEVICES SHOWN AS HALFTONE ARE EXISTING TO BE REMAIN UNLESS NOTED OTHERWISE.
 11. ELECTRICAL CONTRACTOR TO CALCULATE VOLTAGE DROP OF ALL BRANCH CIRCUITS EXCEEDING 100' AND INCREASE CONDUCTOR AND GROUND SIZES AS REQUIRED TO MAINTAIN LESS THAN 5% COMBINED FEEDERBRANCH VOLTAGE DROP AT THE FARTHEST LOAD.
 12. EC SHALL INCLUDE ANY SITE WORK ASSOCIATED WITH ELECTRICAL SERVICE UPGRADE AND ALLIANT ENERGY, ETC. IS RESPONSIBLE FOR LOCATING EXISTING UNDERGROUND SYSTEMS WITHIN AREA OF SCOPE.

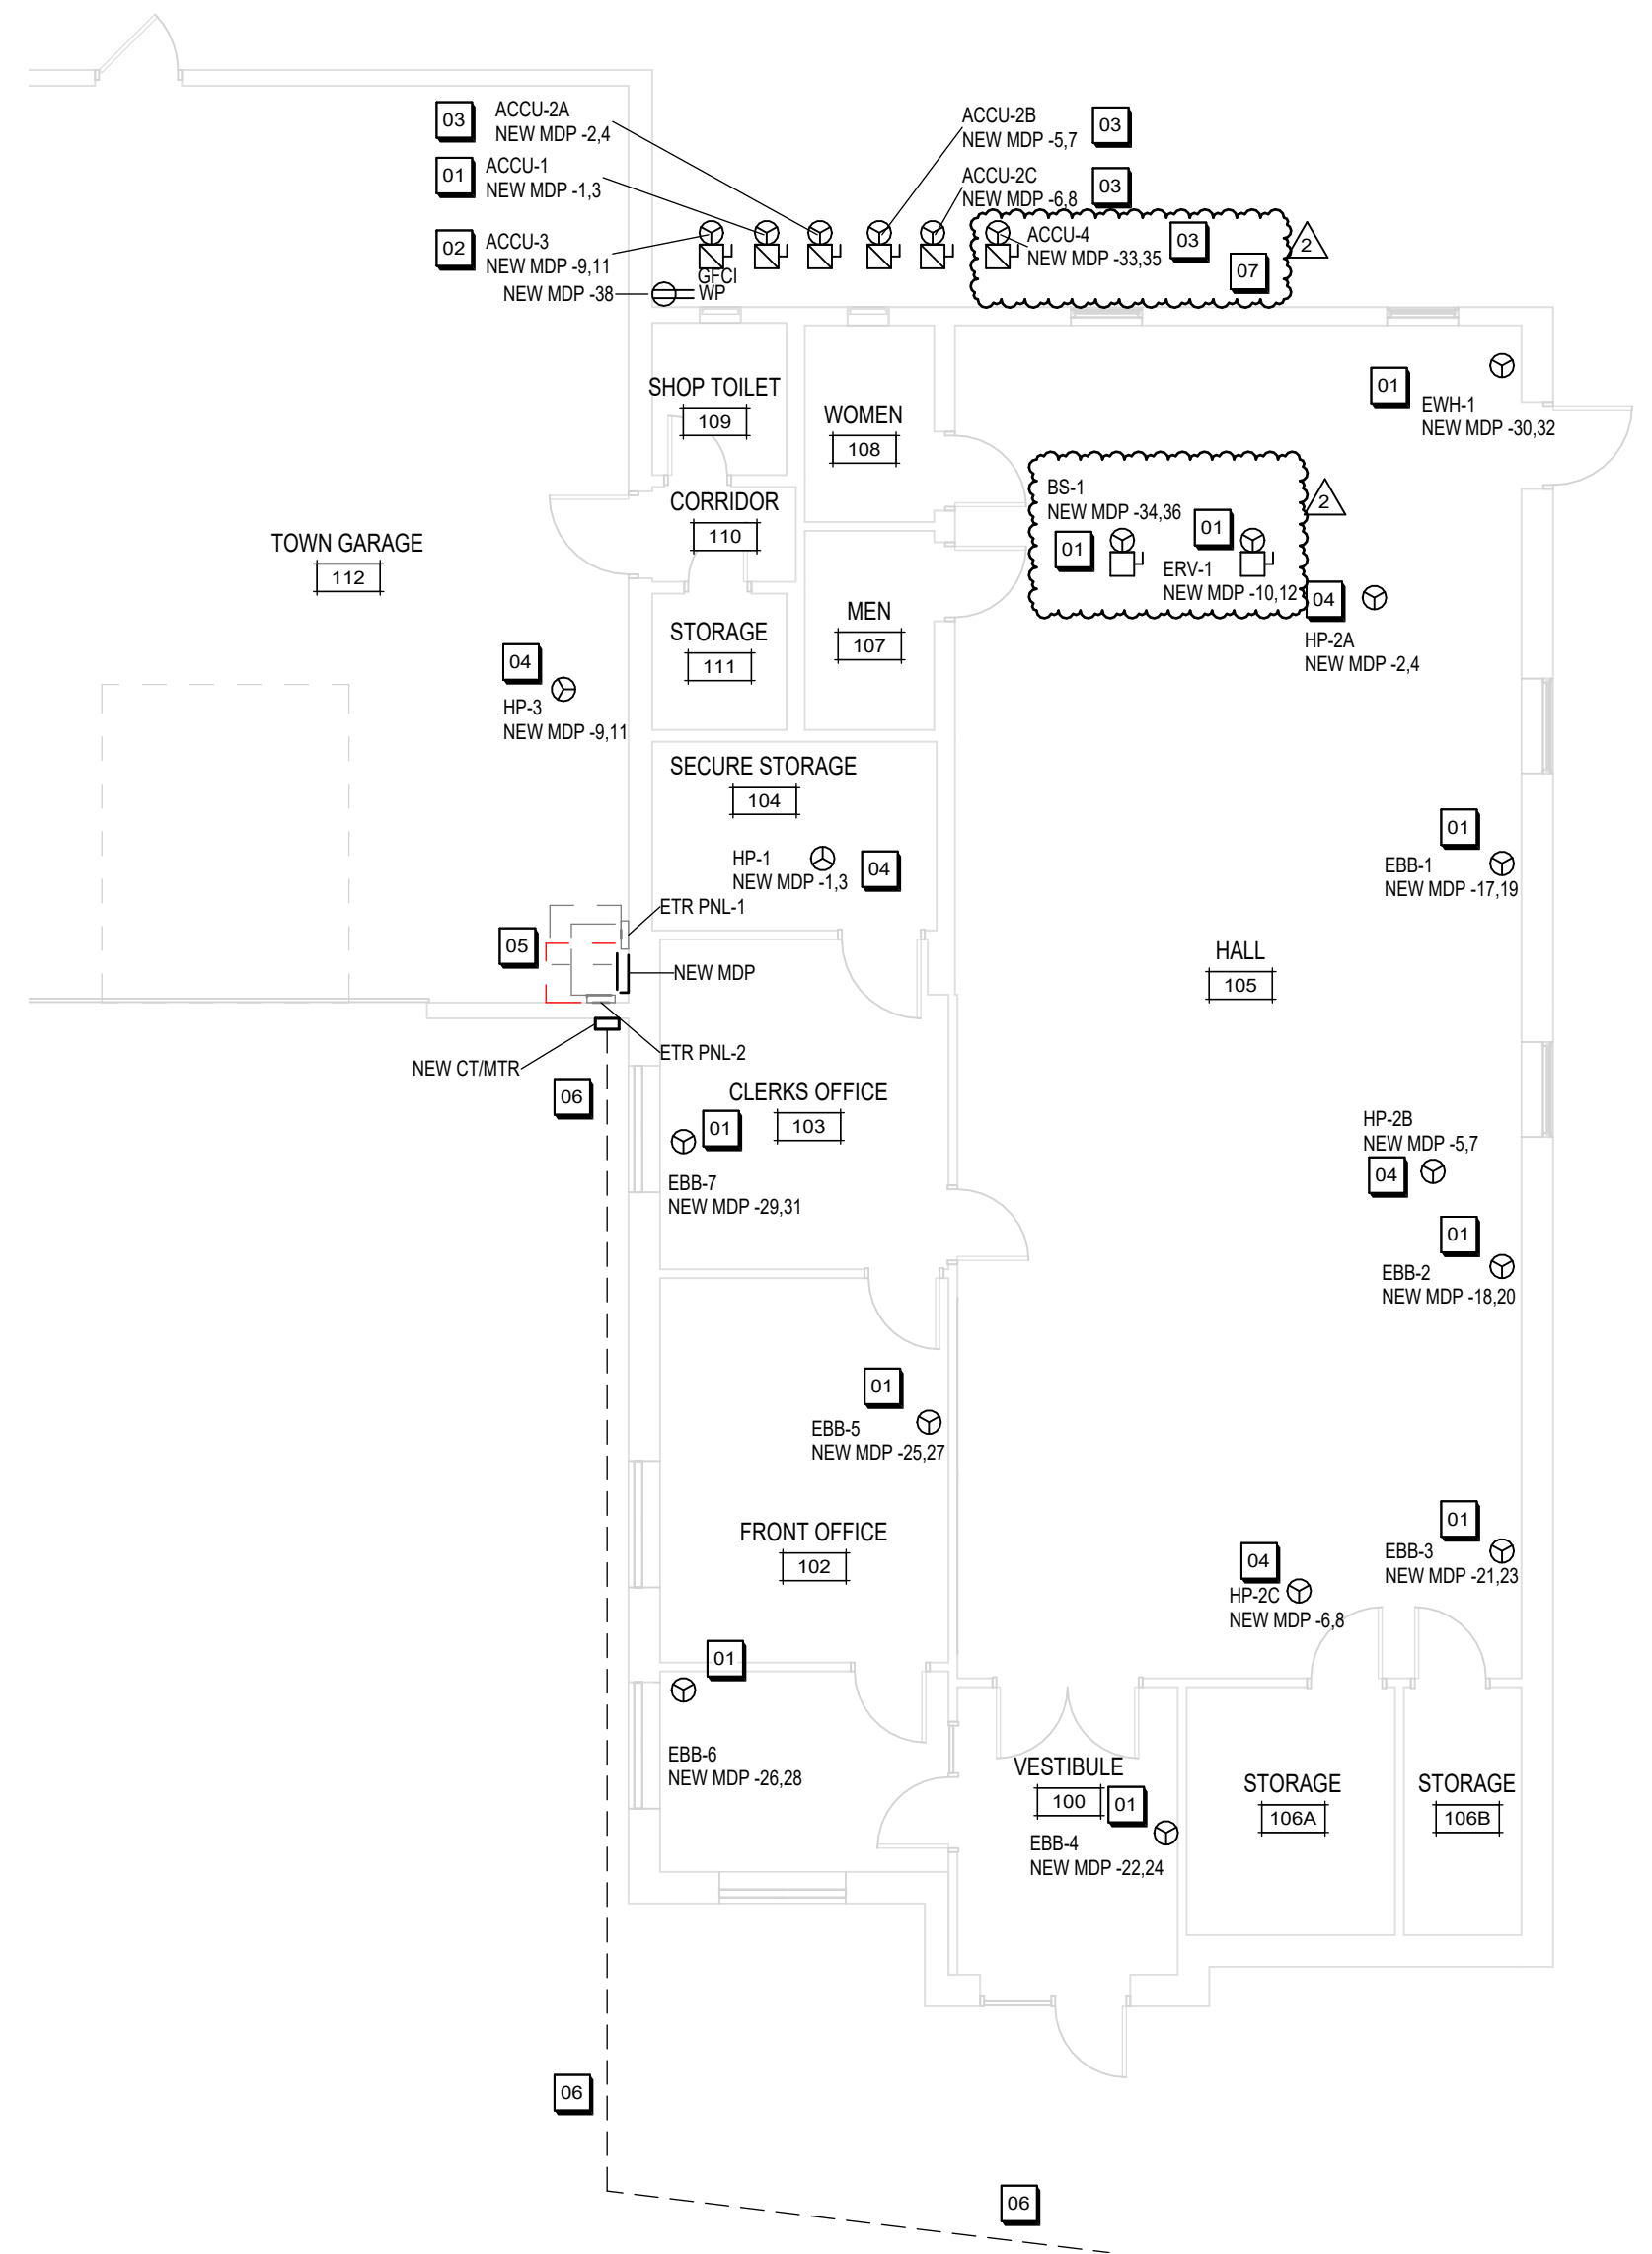

FIRST FLOOR POWER AND SYSTEMS PLAN

SCALE: 1/8" = 1'-0"

PRELIMINARY - NOT FOR CONSTRUCTION

LOCATION: TOWN GARAGE 112	VOLTAGE: 120/240 V. 1 Ø 3 W.
MOUNTING: SURFACE NEMA 1	A.I.C. RATING: 42,000 AMPS SYMMETRICAL
MAIN DEVICE: 400.0 A MAIN CB	SPECIAL:
BUS AMPS: 400 AMPS	

RECEPTACLE SCHEDULE						
DESCRIPTION	SYMBOL	VOLTAGE	MOUNTING	NOTE 1	NOTE 2	NOTE 3
WEATHERPROOF GFCI DUPLEX	WP GFCI 	120 V	MOUNT AT 16" TO BOTTOM AFF, UNLESS NOTED OTHERWISE.	PROVIDE WITH IN-USE WEATHERPROOF COVER.		

CALLOUT	SYMBOL	DESCRIPTION	DISCONNECT		STARTER/VFD		VOLTAGE	PHASE	HORSEPOWER	MOCp	MCA	FLA	NOTES
			TYPE	FURN/INST BY	TYPE	FURN/INST BY							
ACCU-1		CONDENSING UNIT	FUSIBLE	EC	--	--	240 V	1	0.00 hp	15.0 A	11.6 A	9.3 A	FEED HEAT PUMP
ACCU-2A		CONDENSING UNIT	FUSIBLE	EC	--	--	240 V	1	0.00 hp	35.0 A	34.6 A	27.7 A	FEED HEAT PUMP
ACCU-2B		CONDENSING UNIT	FUSIBLE	EC	--	--	240 V	1	0.00 hp	35.0 A	34.6 A	27.7 A	FEED HEAT PUMP
ACCU-2C		CONDENSING UNIT	FUSIBLE	EC	--	--	240 V	1	0.00 hp	35.0 A	34.6 A	27.7 A	FEED HEAT PUMP
ACCU-3		CONDENSING UNIT	FUSIBLE	EC	--	--	240 V	1	0.00 hp	25.0 A	21.4 A	17.1 A	FEED HEAT PUMP
ACCU-4		CONDENSING UNIT	FUSIBLE	EC	--	--	240 V	1	0.00 hp	35.0 A	33.0 A	26.4 A	
BS-1		BRANCH SELECTOR	NON-FUSIBLE	EC	--	--	240 V	1	0.00 hp	15.0 A	1.2 A	0.9 A	
EBB-1		ELECTRIC BASEBOARD HEATER	--	FACTORY	--	--	240 V	1	0.00 hp	15.0 A	8.3 A	8.3 A	LOCKOUT TAGOUT PROVISION
EBB-2		ELECTRIC BASEBOARD HEATER	--	FACTORY	--	--	240 V	1	0.00 hp	15.0 A	8.3 A	8.3 A	LOCKOUT TAGOUT PROVISION
EBB-3		ELECTRIC BASEBOARD HEATER	--	FACTORY	--	--	240 V	1	0.00 hp	15.0 A	8.3 A	8.3 A	LOCKOUT TAGOUT PROVISION
EBB-4		ELECTRIC BASEBOARD HEATER	--	FACTORY	--	--	240 V	1	0.00 hp	15.0 A	2.1 A	2.1 A	LOCKOUT TAGOUT PROVISION
EBB-5		ELECTRIC BASEBOARD HEATER	--	FACTORY	--	--	240 V	1	0.00 hp	15.0 A	6.3 A	6.3 A	LOCKOUT TAGOUT PROVISION
EBB-6		ELECTRIC BASEBOARD HEATER	--	FACTORY	--	--	240 V	1	0.00 hp	15.0 A	6.3 A	6.3 A	LOCKOUT TAGOUT PROVISION
EBB-7		ELECTRIC BASEBOARD HEATER	--	FACTORY	--	--	240 V	1	0.00 hp	15.0 A	4.2 A	4.2 A	LOCKOUT TAGOUT PROVISION
ERV-1		ENERGY RECOVERY VENTILATOR	NON-FUSIBLE	EC	--	--	240 V	1	0.00 hp	15.0 A	9.2 A	8.8 A	PROVIDE LINE VOLTAGE WIRING REQUIRED
EW-1		ELECTRIC WALL HEATER	--	FACTORY	--	--	240 V	1	0.00 hp	15.0 A	4.2 A	4.2 A	LOCKOUT TAGOUT PROVISION
HP-1		HEAT PUMP	--	FACTORY	--	--	240 V	1	0.00 hp	15.0 A	0.0 A	0.0 A	FED FROM CONDENSING UNIT
HP-2A		HEAT PUMP	--	FACTORY	--	--	240 V	1	0.00 hp	15.0 A	0.0 A	0.0 A	FED FROM CONDENSING UNIT
HP-2B		HEAT PUMP	--	FACTORY	--	--	240 V	1	0.00 hp	15.0 A	0.0 A	0.0 A	FED FROM CONDENSING UNIT
HP-2C		HEAT PUMP	--	FACTORY	--	--	240 V	1	0.00 hp	15.0 A	0.0 A	0.0 A	FED FROM CONDENSING UNIT
HP-3		HEAT PUMP	--	FACTORY	--	--	240 V	1	0.00 hp	15.0 A	0.0 A	0.0 A	FED FROM CONDENSING UNIT



TOWN HALL HVAC UPGRADES

1138 UNION ROAD
OREGON, WI 53575

ISSUANCES / REVISIONS

NO:	DESCRIPTION:	DATE:
1	BID DRAWINGS	07/27/2026
2	ADDENDUM 02	09/10/2026

9/10/2006 10:22:16 AM

Due to electronic distribution, this drawing may not be printed to the scale indicated on the drawings. Do NOT use scale to determine dimensions or sizes.

No part of this drawing may be used or reproduced in any form or by any means, or stored in a database or retrieval system, without prior written permission.

ANGUS - YOUNG ASSOCIATES, INC.
Copyright © 2026 All Rights Reserved

PROJECT NUMBER
83390

APPROVED BY
SJG

REVIEWED BY
SJG

DRAWN BY
CTK

ELECTRICAL SCHEDULES,
PANELBOARD SCHEDULE,
ONELINE DIAGRAM, & DETAILS

E301