



# HOTEL PROJECT SONOMA

## KENWOOD INVESTMENTS, LLC

### HOTEL PROJECT SONOMA

Sonoma, CA

**Kenwood Investments LLC**

REVISIONS

No.	Description	Date

### USE PERMIT AUGUST 2021

Sheet Title

### COVER SHEET

Drawn By Author      Checked By Checker

Scale:

Date:  
08/05/2021

Project No.    Project Number

**A0.00**

Drawing No.

If this drawing is not 24" x 36", it is a reduced print - scale accordingly. All rights reserved. Material may not be reproduced in any form without permission from RossDrulisCusenbery Architecture, Inc.

Not For Construction

#### PROJECT DIRECTORY

**DEVELOPER**

KENWOOD INVESTMENTS LLC, SONOMA, CA

**ARCHITECT**

ROSS DRULIS CUSENBERY ARCHITECTURE, INC., SONOMA, CA

**DESIGN COLLABORATOR**

KEITH WICKS, ARTIST, SONOMA, CA

**CIVIL ENGINEER**

HUFFMAN ENGINEERING & SURVEYING, SANTA ROSA, CA

**STRUCTURAL ENGINEER**

WALTER P. MOORE AND ASSOCIATES, SAN FRANCISCO, CA

**PRECONSTRUCTION SERVICES**

MIDSTATE CONSTRUCTION CORPORATION, PETALUMA, CA

**MECHANICAL / PLUMBING ENGINEER:**

15000 INC, SANTA ROSA, CA

**ELECTRICAL ENGINEER:**

SILVERMAN & LIGHT INC, EMERYVILLE, CA

**BUILDING ENCLOSURE ENGINEER:**

SIMPSON GUMPERTZ & HEGER INC, SAN FRANCISCO, CA

**PARKING CONSULTANTS:**

AMPCO SYSTEM PARKING, SAN FRANCISCO, CA

**WATER CONSERVATION CONSULTANTS**

J CROWLEY GROUP, SACRAMENTO, CA


**GEO TECHNICAL ENGINEER**

PJC AND ASSOCIATES, INC., ROHNERT PARK, CA

#### DRAWING INDEX

A0.00	COVER SHEET	A2.02	SECOND FLOOR PLAN
A0.01	CODE ANALYSIS AND FAR CALCULATIONS	A2.03	THIRD FLOOR PLAN
A1.00	PROJECT SITE LOCATION	A3.00	CONCEPTUAL RENDERINGS
A1.01	SITE TOPOGRAPHIC SURVEY	A3.01	EXTERIOR ELEVATIONS - NORTH / EAST
A1.02	EXISTING SITE PLAN	A3.02	EXTERIOR ELEVATIONS - SOUTH / WEST
A1.03	GROSS BUILDING AREA SUMMARY	A3.03	VISUAL SIMULATIONS
A1.04	SITE COVERAGE CALCULATION	A3.04	VISUAL SIMULATIONS
A1.05	PROPOSED SITE ROOF PLAN	A3.51	BUILDING SECTIONS
A2.00	BASEMENT PLAN	A3.52	BUILDING SECTIONS
A2.01	FIRST FLOOR PLAN		

#### REGIONAL LOCATION MAP

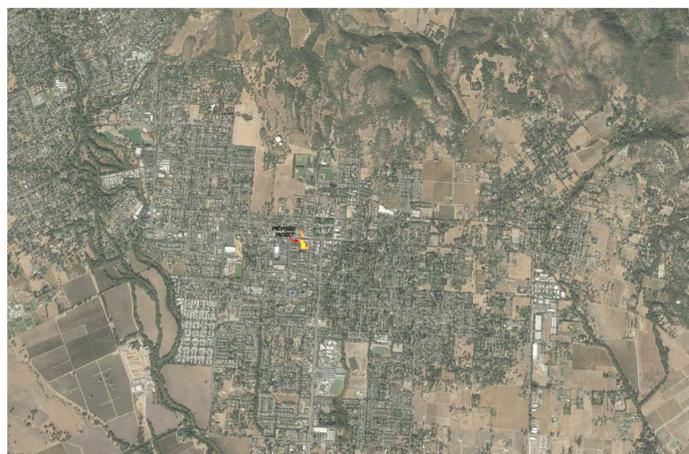

**HOTEL PROJECT SONOMA**

Sonoma, CA

**Kenwood Investments LLC**

REVISIONS

No.	Description	Date

**USE PERMIT AUGUST 2021**

Sheet Title

**CODE ANALYSIS AND FAR CALCULATIONS**

Drawn By Author      Checked By Checker

Scale:  
**As indicated**

Date:  
**08/05/2021**

Project No.    Project Number

**A0.01**  
Drawing No.

If this drawing is not 24" x 36", it is a reduced print - scale accordingly. All rights reserved. Material may not be reproduced in any form without permission from RossDrulisCusenbery Architecture, Inc.

**CODE ANALYSIS - Hotel Project Sonoma - New Construction**

**SUMMARY:**

**TOTAL LOT AREA:** 54,000 SF  
**TOTAL SITE COVERAGE AREA:** 40,031 SF (REFER TO SHEET A1.04)  
**ALLOWABLE LOT COVERAGE:** 100 %  
**ACTUAL LOT COVERAGE:** 74.1 %  
**ALLOWABLE FAR:** Lot Area x 2.0 = 108,000 SF  
**ACTUAL BUILDING AREA:** 86,509 SF (Excludes Basement Areas) = FAR Compliant

**BUILDING AREA PER STORY (EXCLUDES BASEMENT AREA)**

First Floor: 29,770 SF  
 Second Floor: 29,050 SF  
 Third Floor: 27,689 SF  
**Total: 86,509 SF**

**OPEN SPACE:** Exterior Courtyards and Patio Areas: 21,976SF (Approx. 41% of Site Area)

**BASEMENT PARKING GARAGE:** 46,356 SF

**GUEST ROOM COUNT**

**1st Floor**  
 ADA Guest Rooms: 3  
**2nd Floor**  
 Standard Guest Rooms: 23  
 Suites: 4  
 Double Queen: 3  
 Sub Total: 30  
**3rd Floor**  
 Standard Guest Rooms: 22  
 Suites: 4  
 Double Queen: 3  
 Sub Total: 29  
**TOTAL GUESTROOMS: 62**

**RESIDENTIAL UNITS**

1st Floor: 0  
 2nd Floor: 5  
 3rd Floor: 3  
**TOTAL RESIDENTIAL UNITS: 8**

**PARKING**

**Basement**  
 Standard Spaces: 69  
 Valet Spaces: 36  
 Van Spaces: 2  
 Auxiliary Spaces: 6  
 Sub Total: 113  
**1st Floor Surface Parking**  
 Residential Spaces: 8  
 Staff Spaces: 1  
 Valet Spaces: 8  
 Sub Total: 17  
**TOTAL PARKING: 130**

**APPLICABLE REGULATIONS**

City of Sonoma Development Code, 2020  
 2019 CALIFORNIA BUILDING CODE  
 2019 CALIFORNIA MECHANICAL CODE  
 2019 CALIFORNIA PLUMBING CODE  
 2019 CALIFORNIA ELECTRIC CODE  
 2019 CALIFORNIA ENERGY CODE  
 2019 CALIFORNIA FIRE CODE

**APPLICABLE STANDARDS**

SMACNA - FIRE, SMOKE & RADIATION DAMPER INSTALLATION GUIDE FOR HVAC

**TYPE OF CONSTRUCTION:**

Podium: Type I/A (rated, non-combustible) / Podium: Type I/A (rated, non-combustible) protected CIP concrete podium  
 3hr horizontal separation between podium and 2nd floor  
 2nd and 3rd floors: Type V/A (rated, combustible) / 2nd and 3rd floors: Type V/A (rated, combustible) protected wood frame gravity

**FIRE PROTECTION**

Fire Alarm System and Fire Sprinkler System Throughout

**MECHANICAL SHAFTS and ELEVATOR SHAFT**

2hrs rated

**EXIT STAIRS**

Stair #1: interior enclosed, 2 HR enclosed (From 1F to 3F)  
 Stair #2: interior enclosed, 2 HR enclosed (From Basement to 3F)  
 Stair #3: interior enclosed, 2 HR enclosed (From Basement to 3F)  
 Stair #4: interior enclosed, 2 HR enclosed (From 1F to 3F)  
 Stair #5: interior enclosed, 2 HR enclosed (From Basement to 3F)  
 Stair #6: interior enclosed, 2 HR enclosed (From Basement to 3F)  
 Stair #7: interior enclosed, 2 HR enclosed (From 1F to 3F)

**BUILDING OCCUPANCY**

Separated mixed use A-2; R-1; F-1; S-1; S-2

**BUILDING HEIGHT**

Depth of Basement Parking Garage: 11' - 2"  
 Floor Level 1: 12' - 4"  
 Floor Level 2: 10' - 4"  
 Floor Level 3: 12' - 4"  
**Building TOTAL: 35'**  
 Mechanical System Screening & Chimneys +3' in Selected Areas

**NUMBER OF EXITS**

4 From Basement  
 10 From 1st Floor  
 4 From 2nd Floor  
 4 From 3rd Floor  
 2 From Each Floor of Residential Building

**EXIT SEPARATION**


min. 135'  
**MAXIMUM TRAVEL DISTANCE**  
 max. 240'

Area Schedule - Basement		
Name	Occupancy	Area
PARKING GARAGE	S-2, PARKING GARAGE, ENCLOSED	46356 SF
<b>Basement Building Area = 46356 SF</b>		


Area Schedule - 1st Floor		
Name	Occupancy	Area
COURTYARD	EXTERIOR	2,031 SF
EXIT CORRIDOR	R-1, RESIDENTIAL	856 SF
HOTEL	R-1, HOTEL, ROOMS, SPA AND SERVICES	9,691 SF
HOTEL PLAZA	EXTERIOR	9,233 SF
POOL DECK	EXTERIOR	4,580 SF
POOL EQ.	R-1, HOTEL, ROOMS, SPA AND SERVICES	295 SF
RAMP	EXTERIOR	2,285 SF
RAMP	S-2, PARKING GARAGE, ENCLOSED	1,282 SF
RESIDENTIAL PARKING	S-1, STORAGE	5,772 SF
RESTAURANT	A-2, RESTAURANT	6,899 SF
SOUTH GARDEN	EXTERIOR	1,579 SF
SPA	R-1, HOTEL, ROOMS, SPA AND SERVICES	4,975 SF
SPA PLAZA	EXTERIOR	1,282 SF
WALKWAY	EXTERIOR	986 SF
<b>1st Floor Site Features &amp; Building Total Area = 51,745 SF</b>		
<b>1st Floor Building Area = 29,770 SF</b>		

Area Schedule - 2nd floor		
Name	Occupancy	Area
GARDEN TERRACE	EXTERIOR	622 SF
HOTEL A	R-1, HOTEL, ROOMS AND SERVICES	7,313 SF
HOTEL B	R-1, HOTEL, ROOMS AND SERVICES	14,951 SF
RESIDENTIAL BUILDING	R-1, RESIDENTIAL	6,786 SF
<b>2nd Floor Total Area = 29,672 SF</b>		
<b>2nd Floor Building Area = 29,050 SF</b>		


Area Schedule - 3rd floor		
Name	Occupancy	Area
HOTEL A	R-1, HOTEL, ROOMS AND SERVICES	6,887 SF
HOTEL B	R-1, HOTEL, ROOMS AND SERVICES	14,625 SF
RESIDENTIAL BUILDING	R-1, RESIDENTIAL	6,177 SF
<b>3rd Floor Building Area = 27,689 SF</b>		

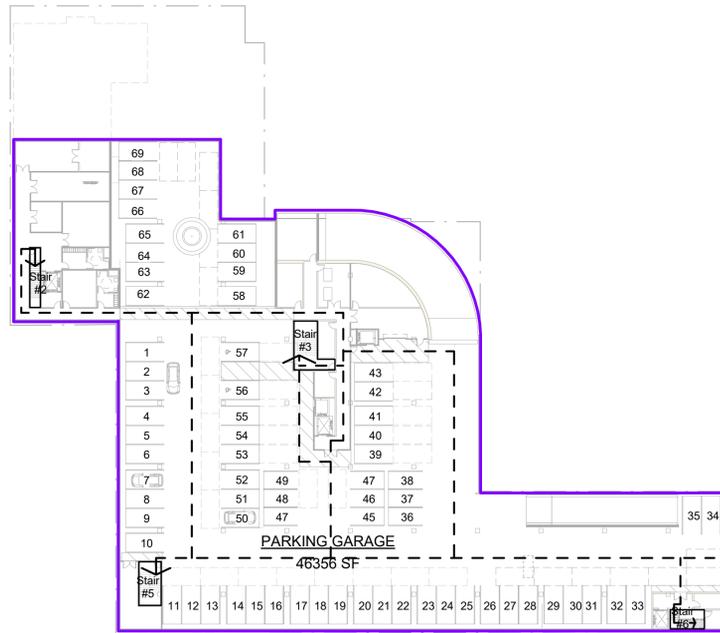


**BASEMENT**

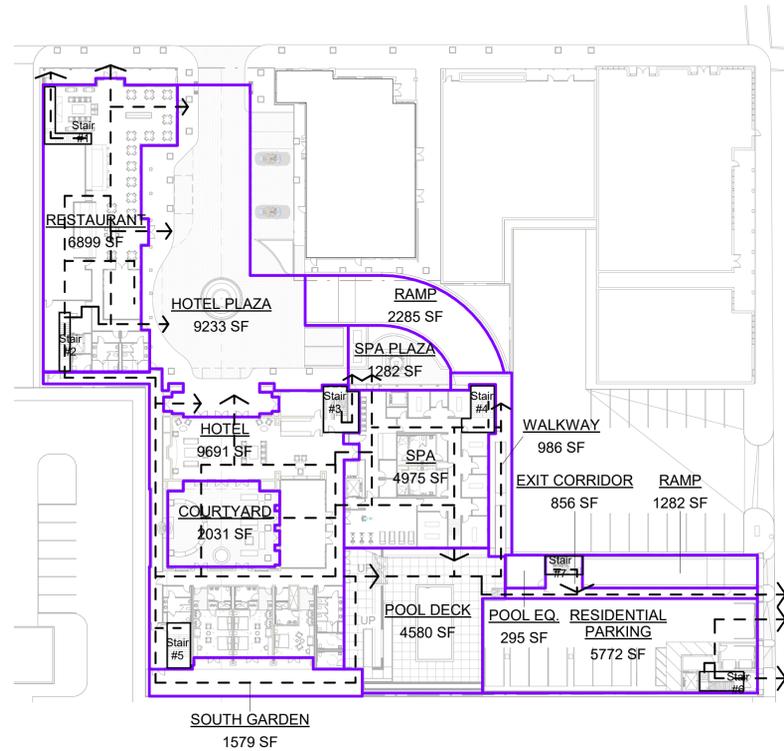


**FIRST FLOOR**

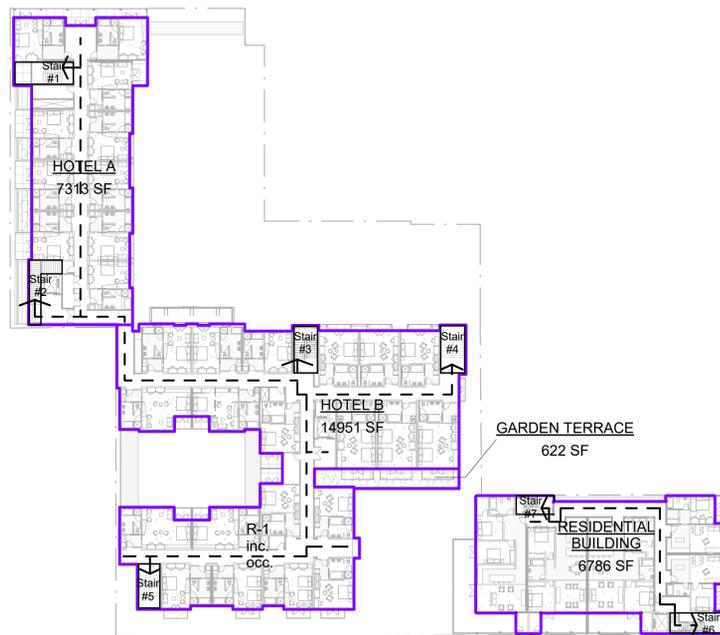

**SECOND FLOOR**

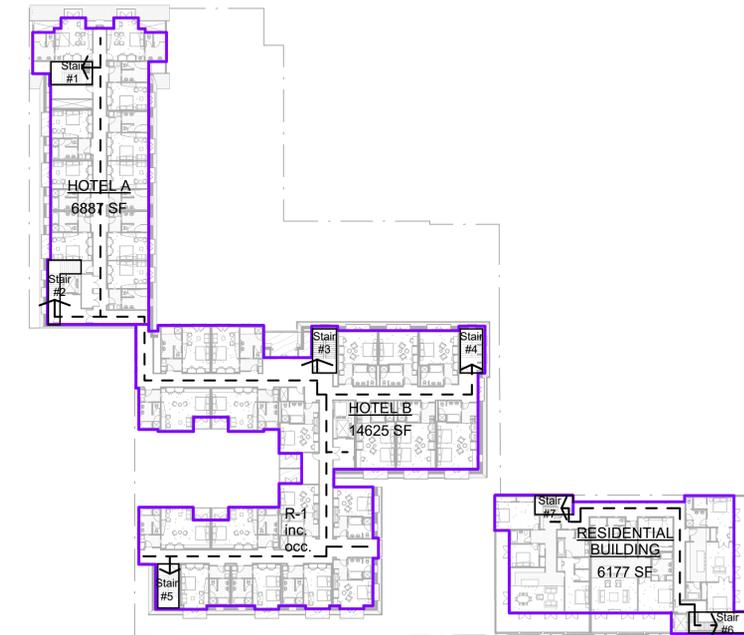

**THIRD FLOOR**

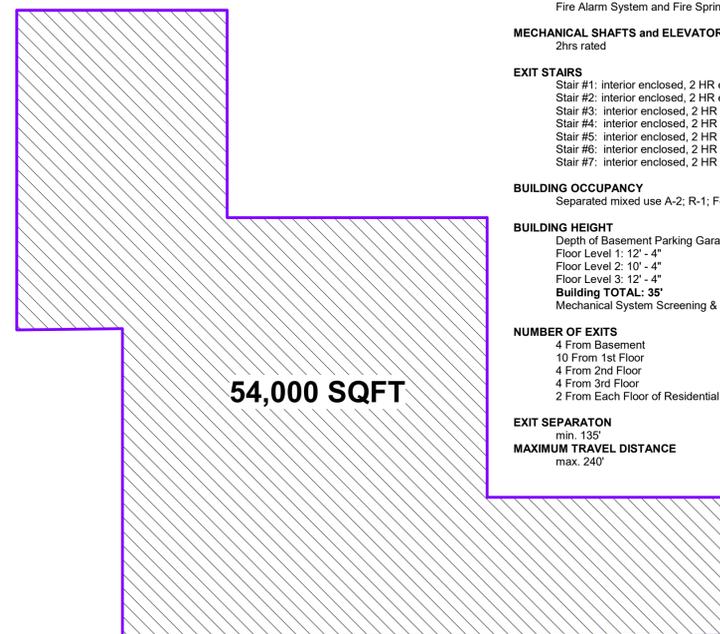

**LOT AREA**



Not For Construction



**HOTEL PROJECT  
SONOMA**  
Sonoma, CA  
**Kenwood  
Investments LLC**

 
REVISIONS

No.	Description	Date

**USE PERMIT AUGUST  
2021**

Sheet Title  
**PROJECT SITE  
LOCATION**

Drawn By Author      Checked By Checker  
Scale:  
Date:  
08/05/2021  
Project No.    Project Number



PROJECT SITE LOCATION

**A1.00**  
Drawing No.

Not For Construction

If this drawing is not 24" x 36", it is a reduced print - scale accordingly. All rights reserved. Material may not be reproduced in any form without permission from RossDrulisCusenbery Architecture, Inc.



**HOTEL PROJECT  
SONOMA**

Sonoma, CA

**Kenwood  
Investments LLC**

REVISIONS

No.	Description	Date

**USE PERMIT AUGUST  
2021**

Sheet Title  
**EXISTING SITE PLAN**

Drawn By Author Checked By Checker

Scale:  
1/16" = 1'-0"

Date:  
08/05/2021

Project No. Project Number

**A1.02**  
Drawing No.

 
If this drawing is not 24" x 36", it is a reduced print - scale accordingly. All rights reserved. Material may not be reproduced in any form without permission from RossDrulisCusenbery Architecture, Inc.

Not For Construction



--- PROPOSED SITE BOUNDARY LINE

1 EXISTING SITE PLAN  
1/16" = 1'-0"



**HOTEL PROJECT  
SONOMA**

Sonoma, CA

**Kenwood  
Investments LLC**

REVISIONS		
No.	Description	Date

**USE PERMIT AUGUST  
2021**

Sheet Title

**GROSS BUILDING AREA  
SUMMARY**

Drawn By Author      Checked By Checker

Scale:  
**As indicated**


Date:  
**08/05/2021**

Project No.    Project Number


**A1.03**  
Drawing No.

If this drawing is not 24" x 36", it is a reduced print - scale accordingly. All rights reserved. Material may not be reproduced in any form without permission from RossDrulisCusenbery Architecture, Inc.


Not For Construction

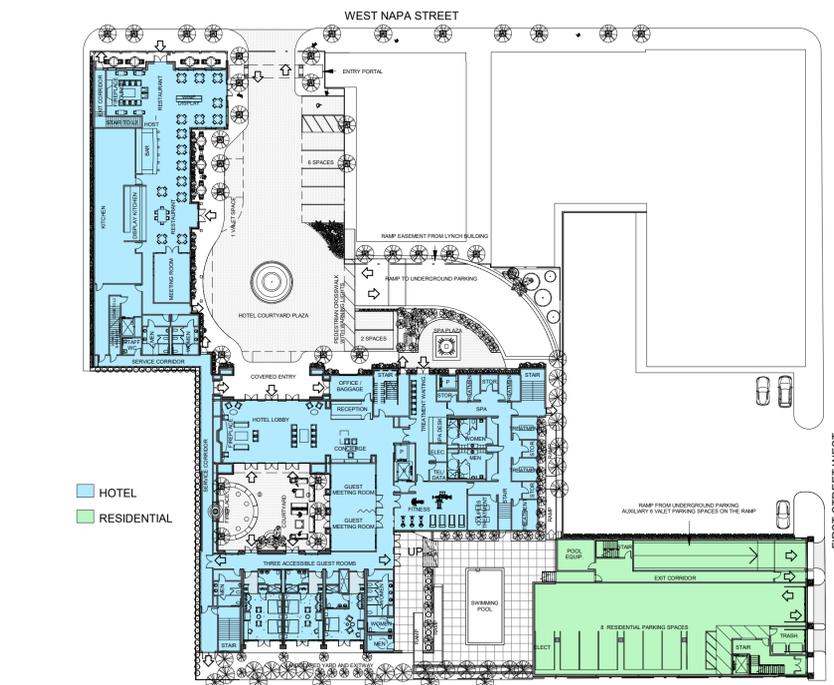


3 FIRST FLOOR - HOTEL / RESIDENTIAL  
1" = 40'-0"

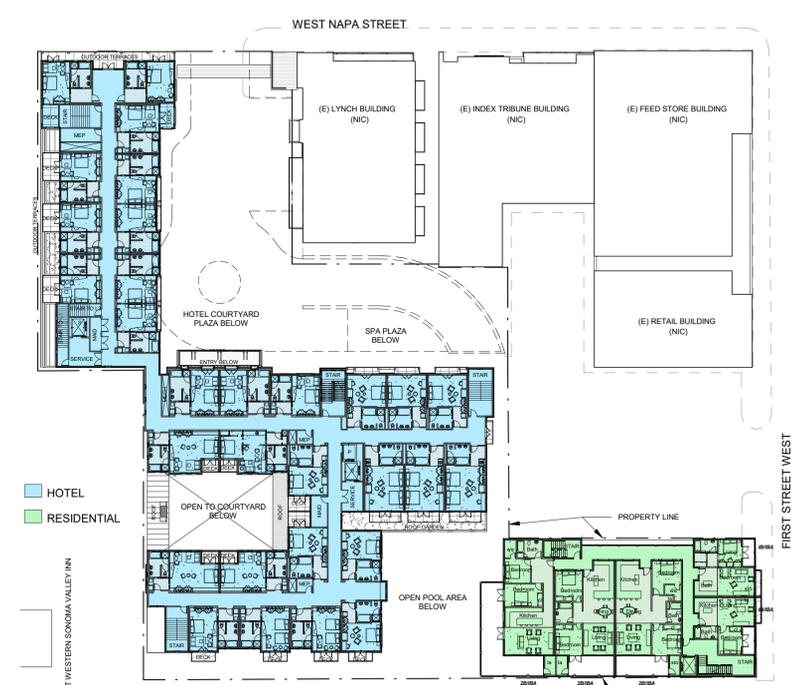


4 SECOND FLOOR - HOTEL / RESIDENTIAL  
1" = 40'-0"

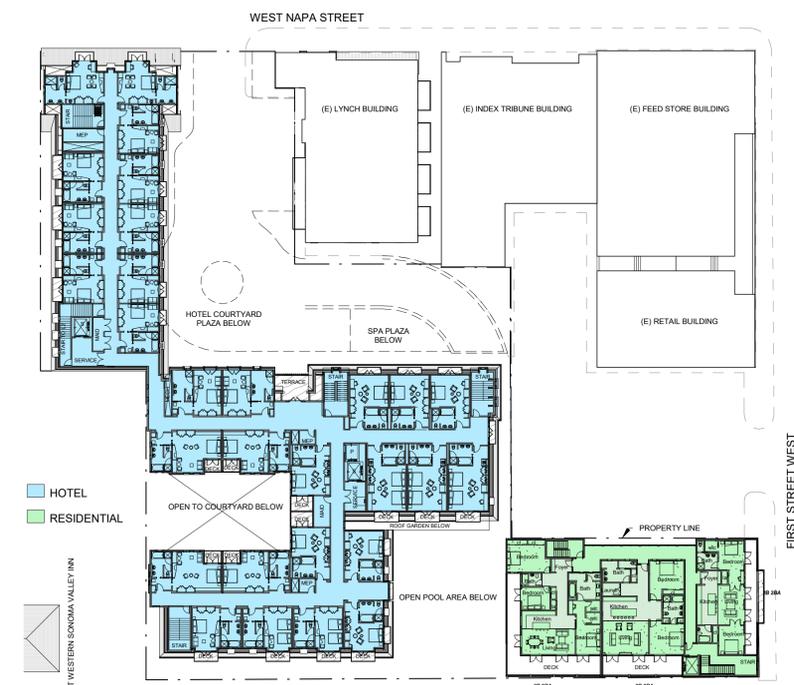

5 THIRD FLOOR - HOTEL / RESIDENTIAL  
1" = 40'-0"

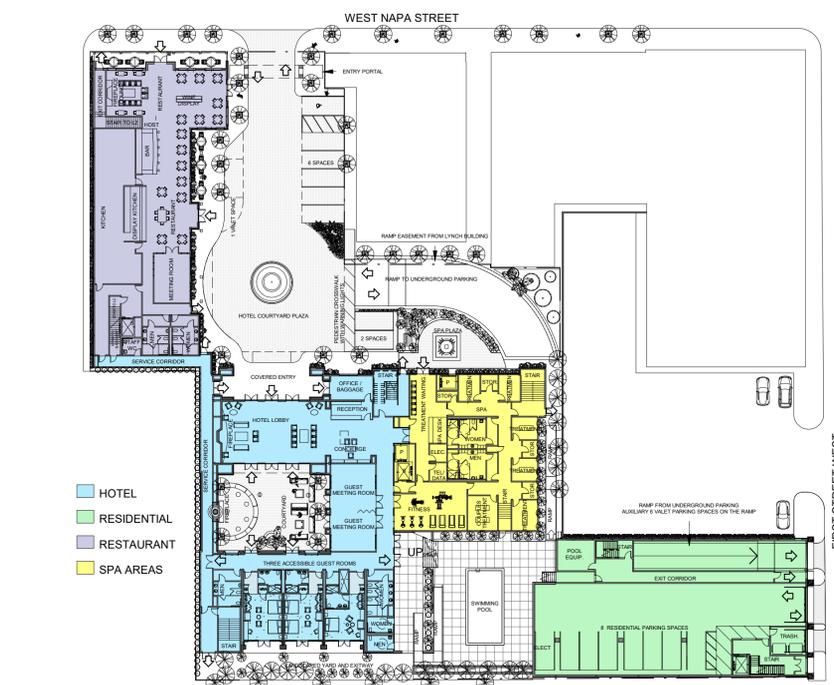

2 RESTAURANT / SPA AREAS  
1" = 40'-0"

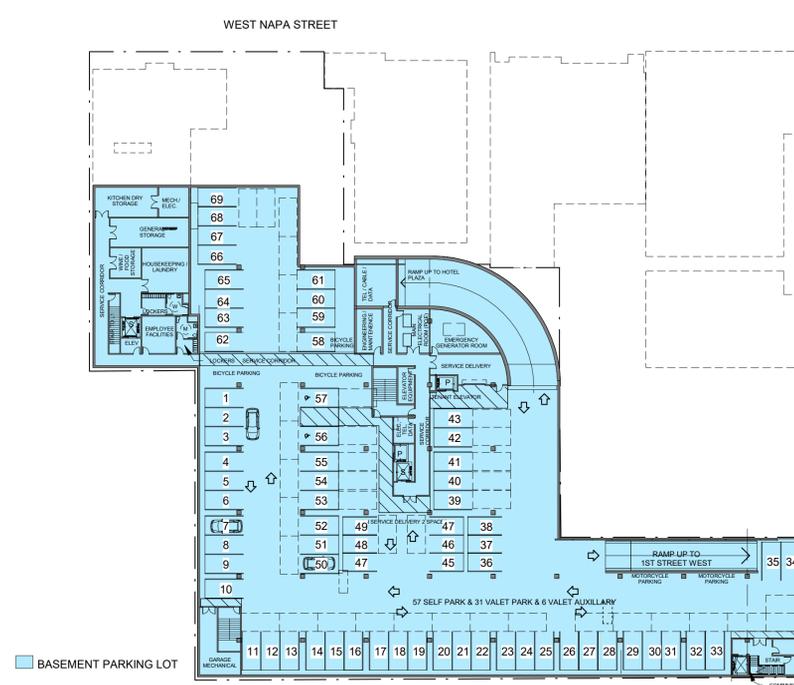

1 BASEMENT COVERAGE  
1" = 40'-0"

**GROSS BUILDING AREA SUMMARY (BY USE)**

Hotel	Area	SF
Basement:	46,356	SF
First Floor:	21,565	SF
Second Floor:	22,264	SF
Third Floor:	21,512	SF
<b>Sub Total</b>	<b>111,697</b>	<b>SF</b>

Residential	Area	SF
First Floor Parking:	8,205	SF
Second Floor:	6,786	SF
Third Floor:	6,177	SF
<b>Sub Total</b>	<b>21,168</b>	<b>SF</b>

Restaurant / SPA (Areas Included In Hotel First Floor Above)	Area	SF
Restaurant:	6,899	SF
SPA:	4,975	SF

**TOTAL AREA 132,865 SF**

**GROSS BUILDING AREA SUMMARY (BY LEVEL)**

Level	Area	SF
Basement:	46,356	SF
First Floor:	29,770	SF
Second Floor:	29,050	SF
Third Floor:	27,689	SF

**TOTAL AREA 132,865 SF**

**PARKING CALCULATION**

Basement	Count
Standard Spaces:	69
Valet Spaces:	36
Van Spaces:	2
Auxiliary Spaces:	6
<b>Sub Total</b>	<b>113</b>

1st Floor Surface Parking	Count
Residential Spaces:	8
Staff Spaces:	1
Lynch Valet Spaces:	8
<b>Sub Total</b>	<b>17</b>

**TOTAL PARKING 130**

 
**GUESTROOM CALCULATION**

1st Floor	Count
ADA Guest Rooms:	3
<b>Sub Total</b>	<b>3</b>

2nd Floor	Count
Standard Guest Rooms:	23
Suites:	4
Double Queen:	3
<b>Sub Total</b>	<b>30</b>

3rd Floor	Count
Standard Guest Rooms:	22
Suites:	4
Double Queen:	3
<b>Sub Total</b>	<b>29</b>

**TOTAL GUESTROOMS 62**



**HOTEL PROJECT  
SONOMA**  
Sonoma, CA  
**Kenwood  
Investments LLC**

REVISIONS

No.	Description	Date

**USE PERMIT AUGUST  
2021**

Sheet Title

**SITE COVERAGE  
CALCULATION**

Drawn By Author      Checked By Checker


Scale:  
**As indicated**

Date:  
**08/05/2021**

Project No.    Project Number

**A1.04**  
Drawing No.

If this drawing is not 24" x 36", it is a reduced print - scale accordingly. All rights reserved. Material may not be reproduced in any form without permission from RossDrulisCusenbery Architecture, Inc.

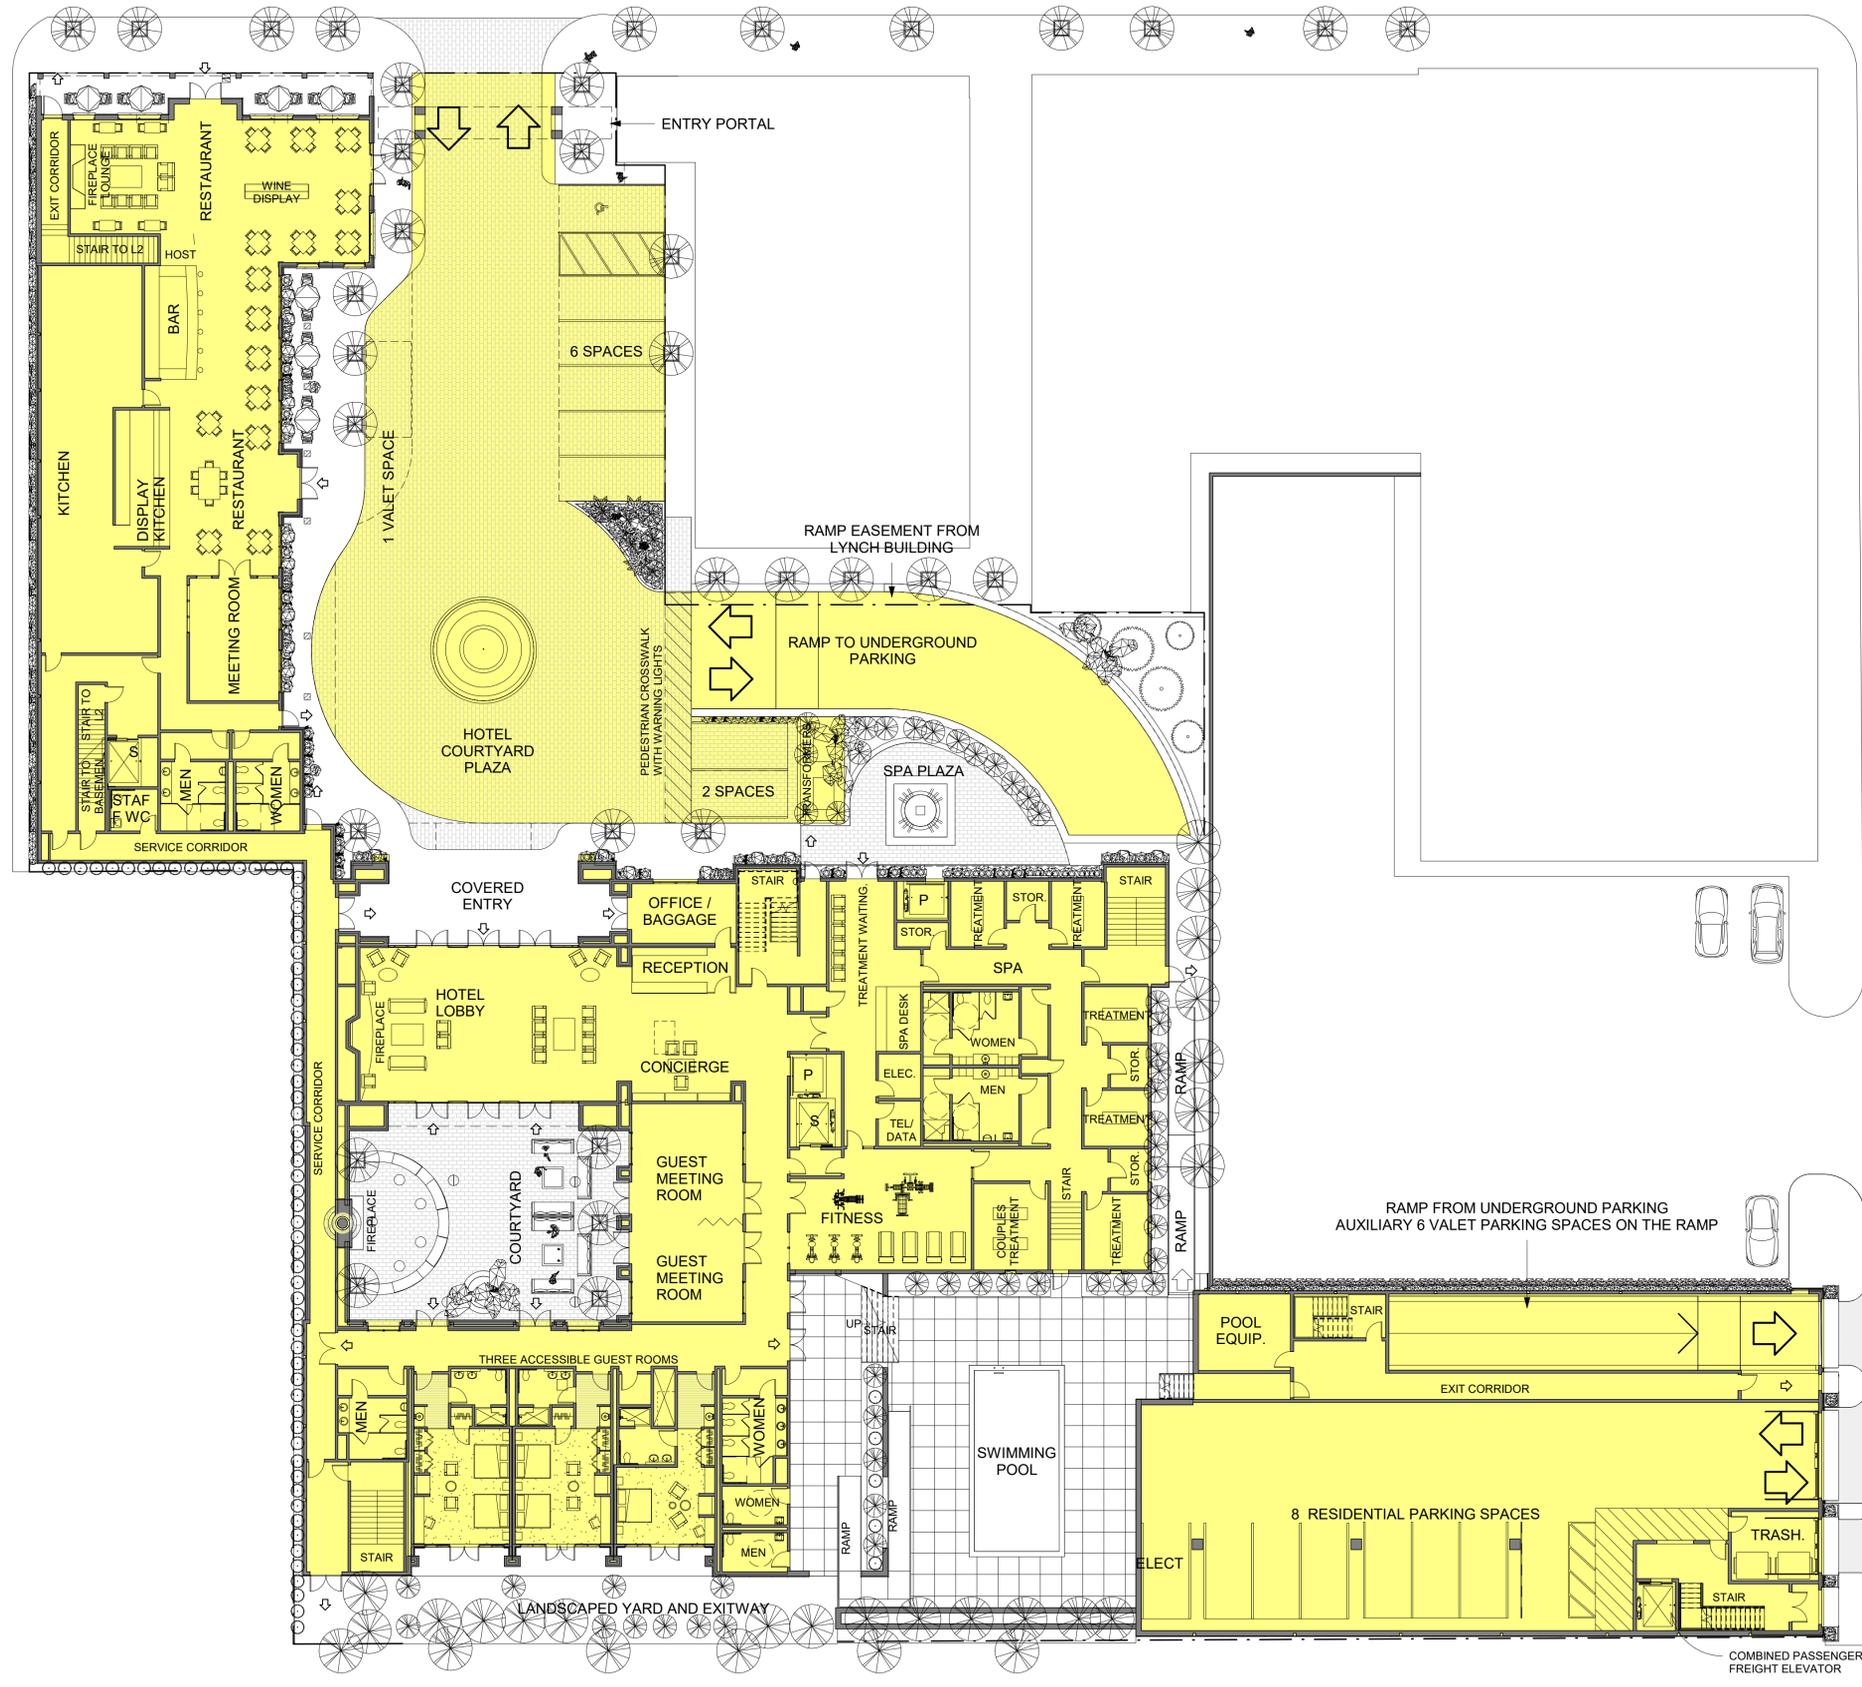

**TOTAL SITE COVERAGE**

The total site area is 54,000 SF. The area in yellow represents the percentage of total site area occupied by structures, and areas necessary for the ingress, egress, outdoor parking, and circulation of motor vehicles = 40,031 SF or 74.1% of total site area.

**PARKING CALCULATION**

Floor	Standard Spaces	Valet Spaces	Van Spaces	Auxiliary Spaces	Sub Total
<b>Basement</b>	69	36	2	6	113
<b>1st Floor Surface Parking</b>	8	1	8	0	17
<b>TOTAL PARKING</b>					130

**GUESTROOM CALCULATION**

Floor	Standard Guest Rooms	Suites	Double Queen	Sub Total
<b>1st Floor</b>	3	0	0	3
<b>2nd Floor</b>	23	4	3	30
<b>3rd Floor</b>	22	4	3	29
<b>TOTAL GUESTROOMS</b>				62

1 SITE COVERAGE CALCULATION  
1/16" = 1'-0"

Not For Construction

REVISIONS

No.	Description	Date

**USE PERMIT AUGUST  
2021**

Sheet Title  
**PROPOSED SITE ROOF  
PLAN**

Drawn By Author      Checked By Checker

Scale:  
1/16" = 1'-0"

 

Date:  
08/05/2021

Project No.    Project Number

**A1.05**  
Drawing No.

If this drawing is not 24" x 36", it is a reduced print - scale accordingly. All rights reserved. Material may not be reproduced in any form without permission from RossDrulisCusenbery Architecture, Inc.

Not For Construction

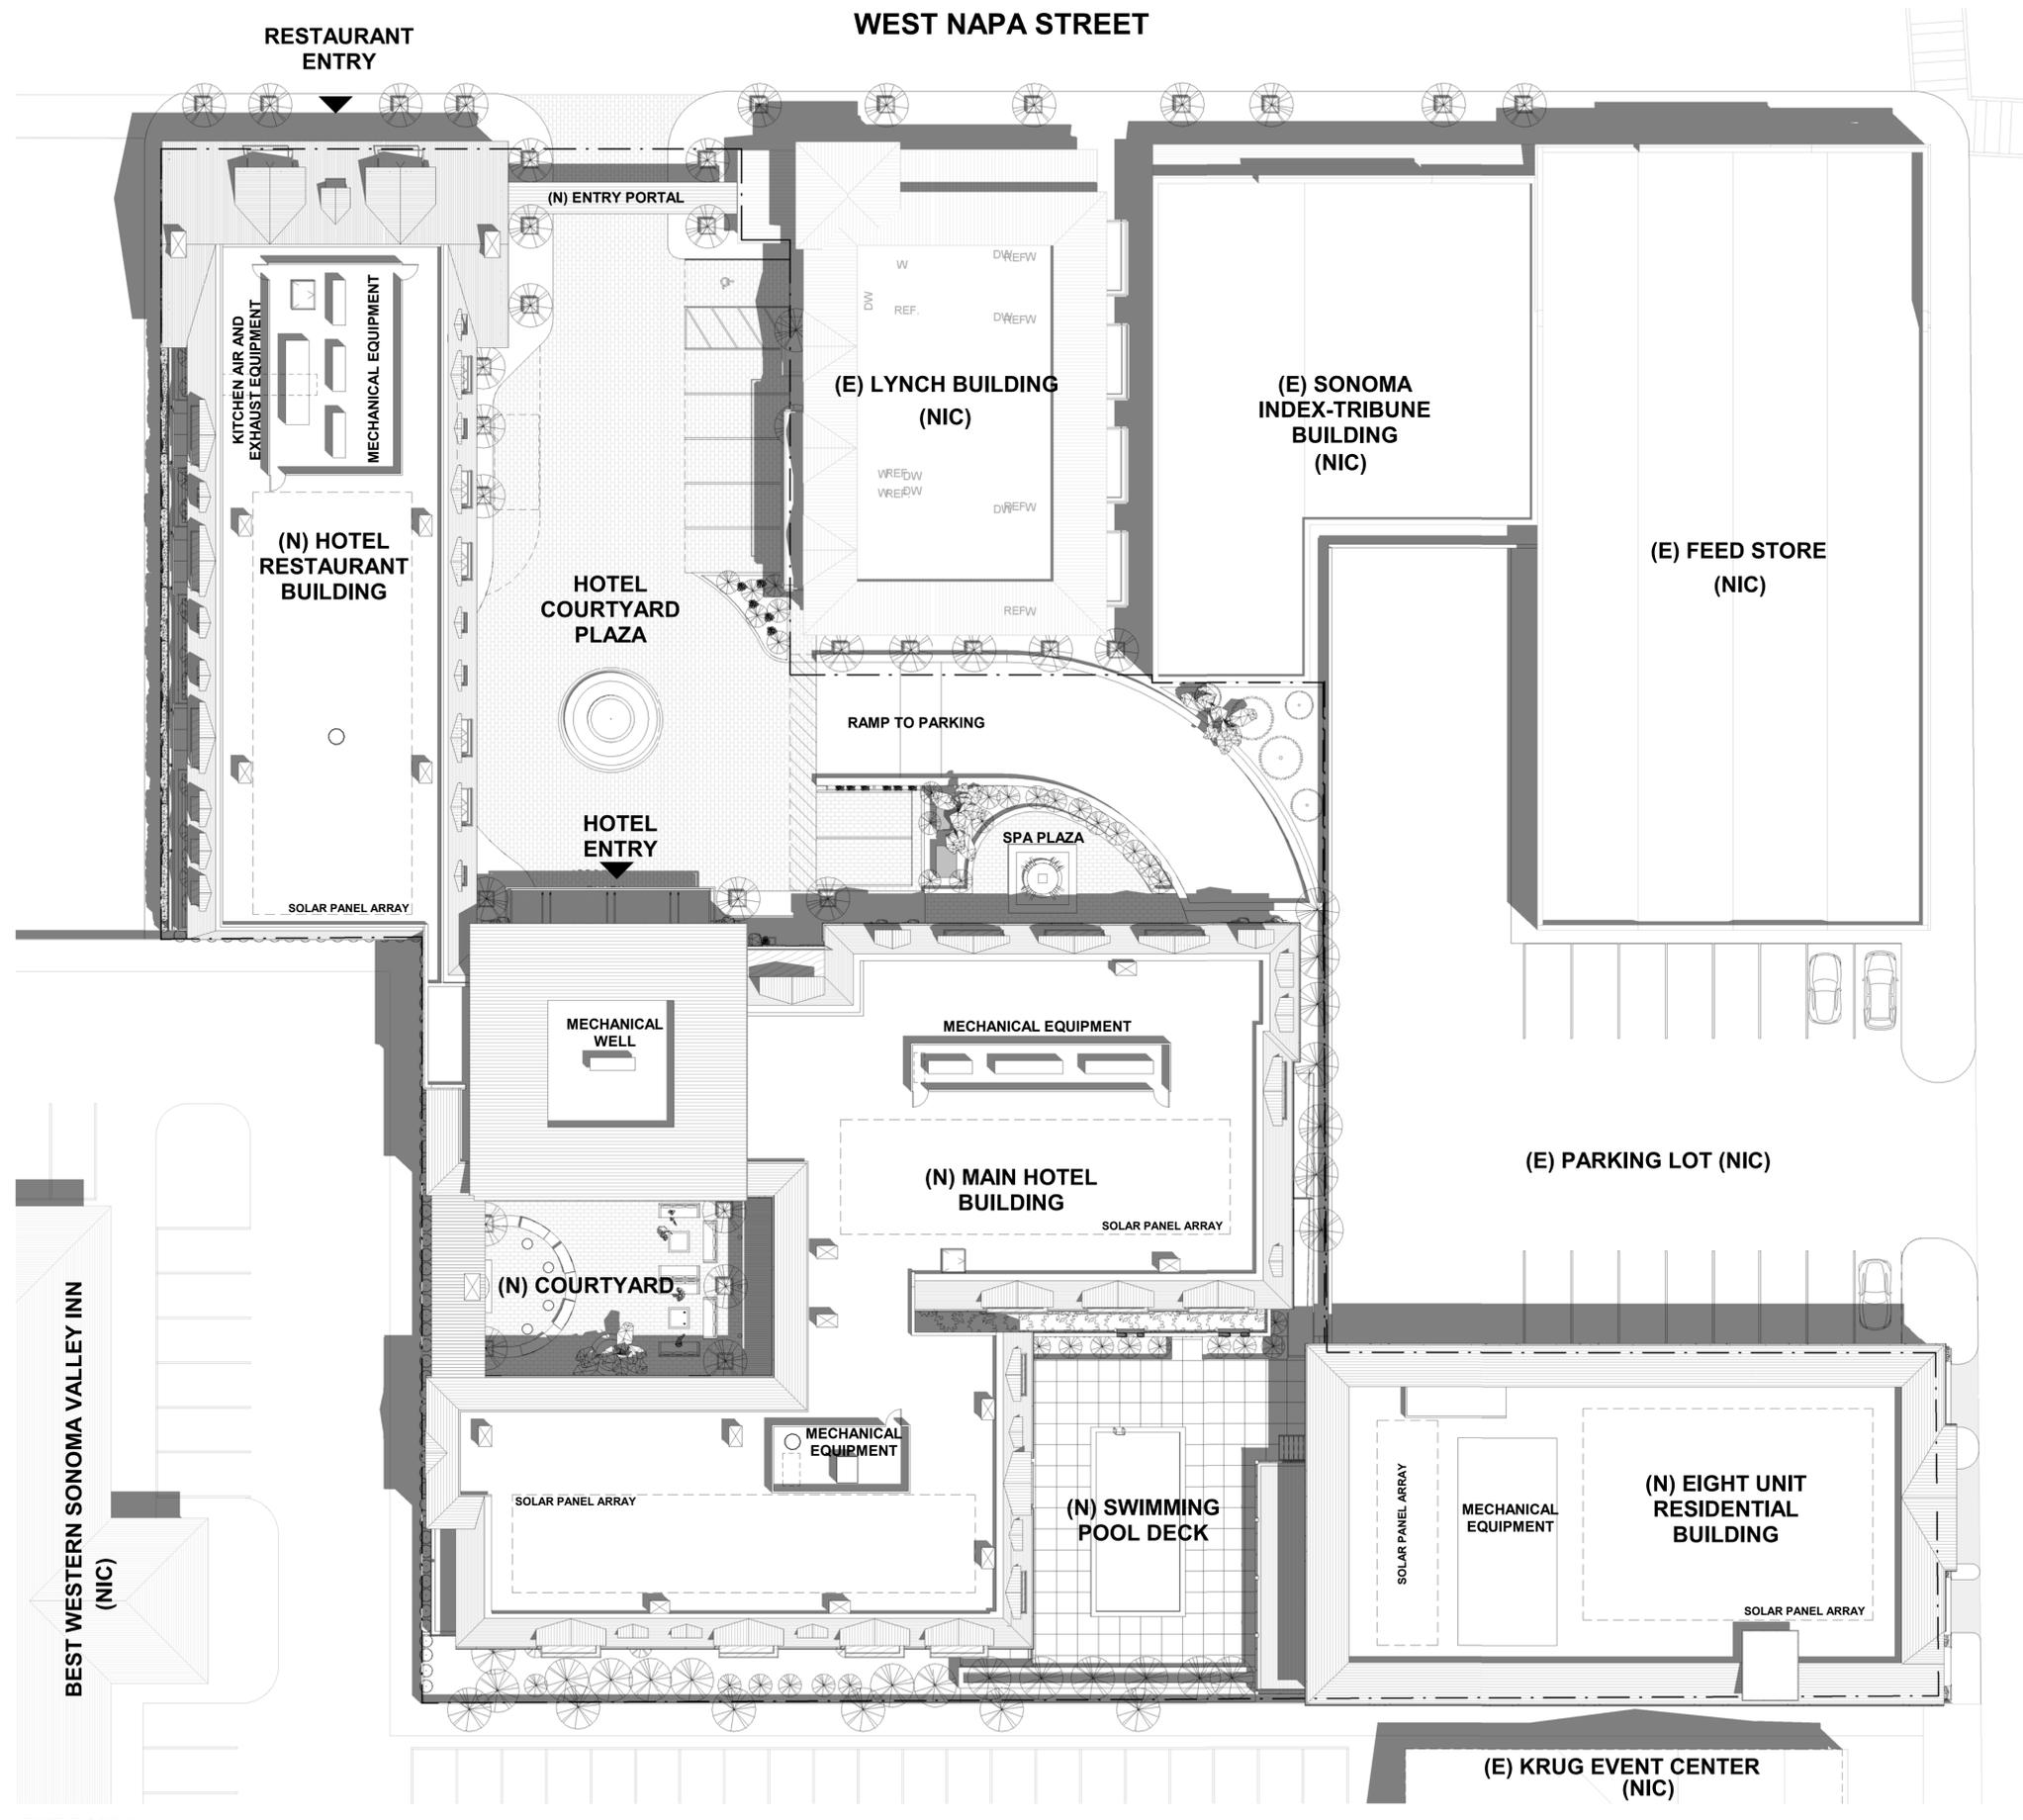

② FIRST FLOOR PLAN  
1/16" = 1'-0"

**HOTEL PROJECT  
SONOMA**  
Sonoma, CA  
**Kenwood  
Investments LLC**

REVISIONS


No.	Description	Date

**USE PERMIT AUGUST  
2021**

Sheet Title  
**BASEMENT PLAN**

**PARKING CALCULATION**

 Category	Standard Spaces	Valet Spaces	Van Spaces	Auxiliary Spaces	Sub Total
<b>Basement</b>	69	36	2	6	113
<b>1st Floor Surface Parking</b>	8	1	8	17	34
<b>TOTAL PARKING</b>	77	37	10	23	137



Drawn By Author Checked By Checker  
Scale:  
**As indicated**  
Date:  
**08/05/2021**  
Project No. Project Number

**A2.00**  
Drawing No.

Not For Construction

1 FP- 00- BASEMENT - USE PERMIT 2021  
1/16" = 1'-0"

8/5/2021 12:08:07 PM C:\Users\Stacey\Documents\Sonoma Hotel\_Central File 2020\_xgao3T13V.rvt

**HOTEL PROJECT  
SONOMA**  
Sonoma, CA  
**Kenwood  
Investments LLC**

REVISIONS

No.	Description	Date

**USE PERMIT AUGUST  
2021**

Sheet Title  
**FIRST FLOOR PLAN**

Drawn By Author      Checked By Checker  
Scale:  
**As indicated**  
Date:  
**08/05/2021**  
Project No.    Project Number

**A2.01**  
Drawing No.

**RESTAURANT SEATS COUNT**


 
INDOOR SEATS	80
OUTDOOR SEATS	20
<b>TOTAL SEATS COUNT</b>	<b>100</b>

**PARKING CALCULATION**

Basement	
Standard Spaces:	69
Valet Spaces:	36
Van Spaces:	2
Auxiliary Spaces:	6
<b>Sub Total</b>	<b>113</b>
1st Floor Surface Parking	
Residential Spaces:	8
Staff Spaces:	1
Lynch Valet Spaces:	8
<b>Sub Total</b>	<b>17</b>
<b>TOTAL PARKING</b>	<b>130</b>

**GUESTROOM CALCULATION**

1st Floor	
ADA Guest Rooms:	3
<b>Sub Total</b>	<b>3</b>
2nd Floor	
Standard Guest Rooms:	23
Suites:	4
Double Queen:	3
<b>Sub Total</b>	<b>30</b>
3rd Floor	
Standard Guest Rooms:	22
Suites:	4
Double Queen:	3
<b>Sub Total</b>	<b>29</b>
<b>TOTAL GUESTROOMS</b>	<b>62</b>

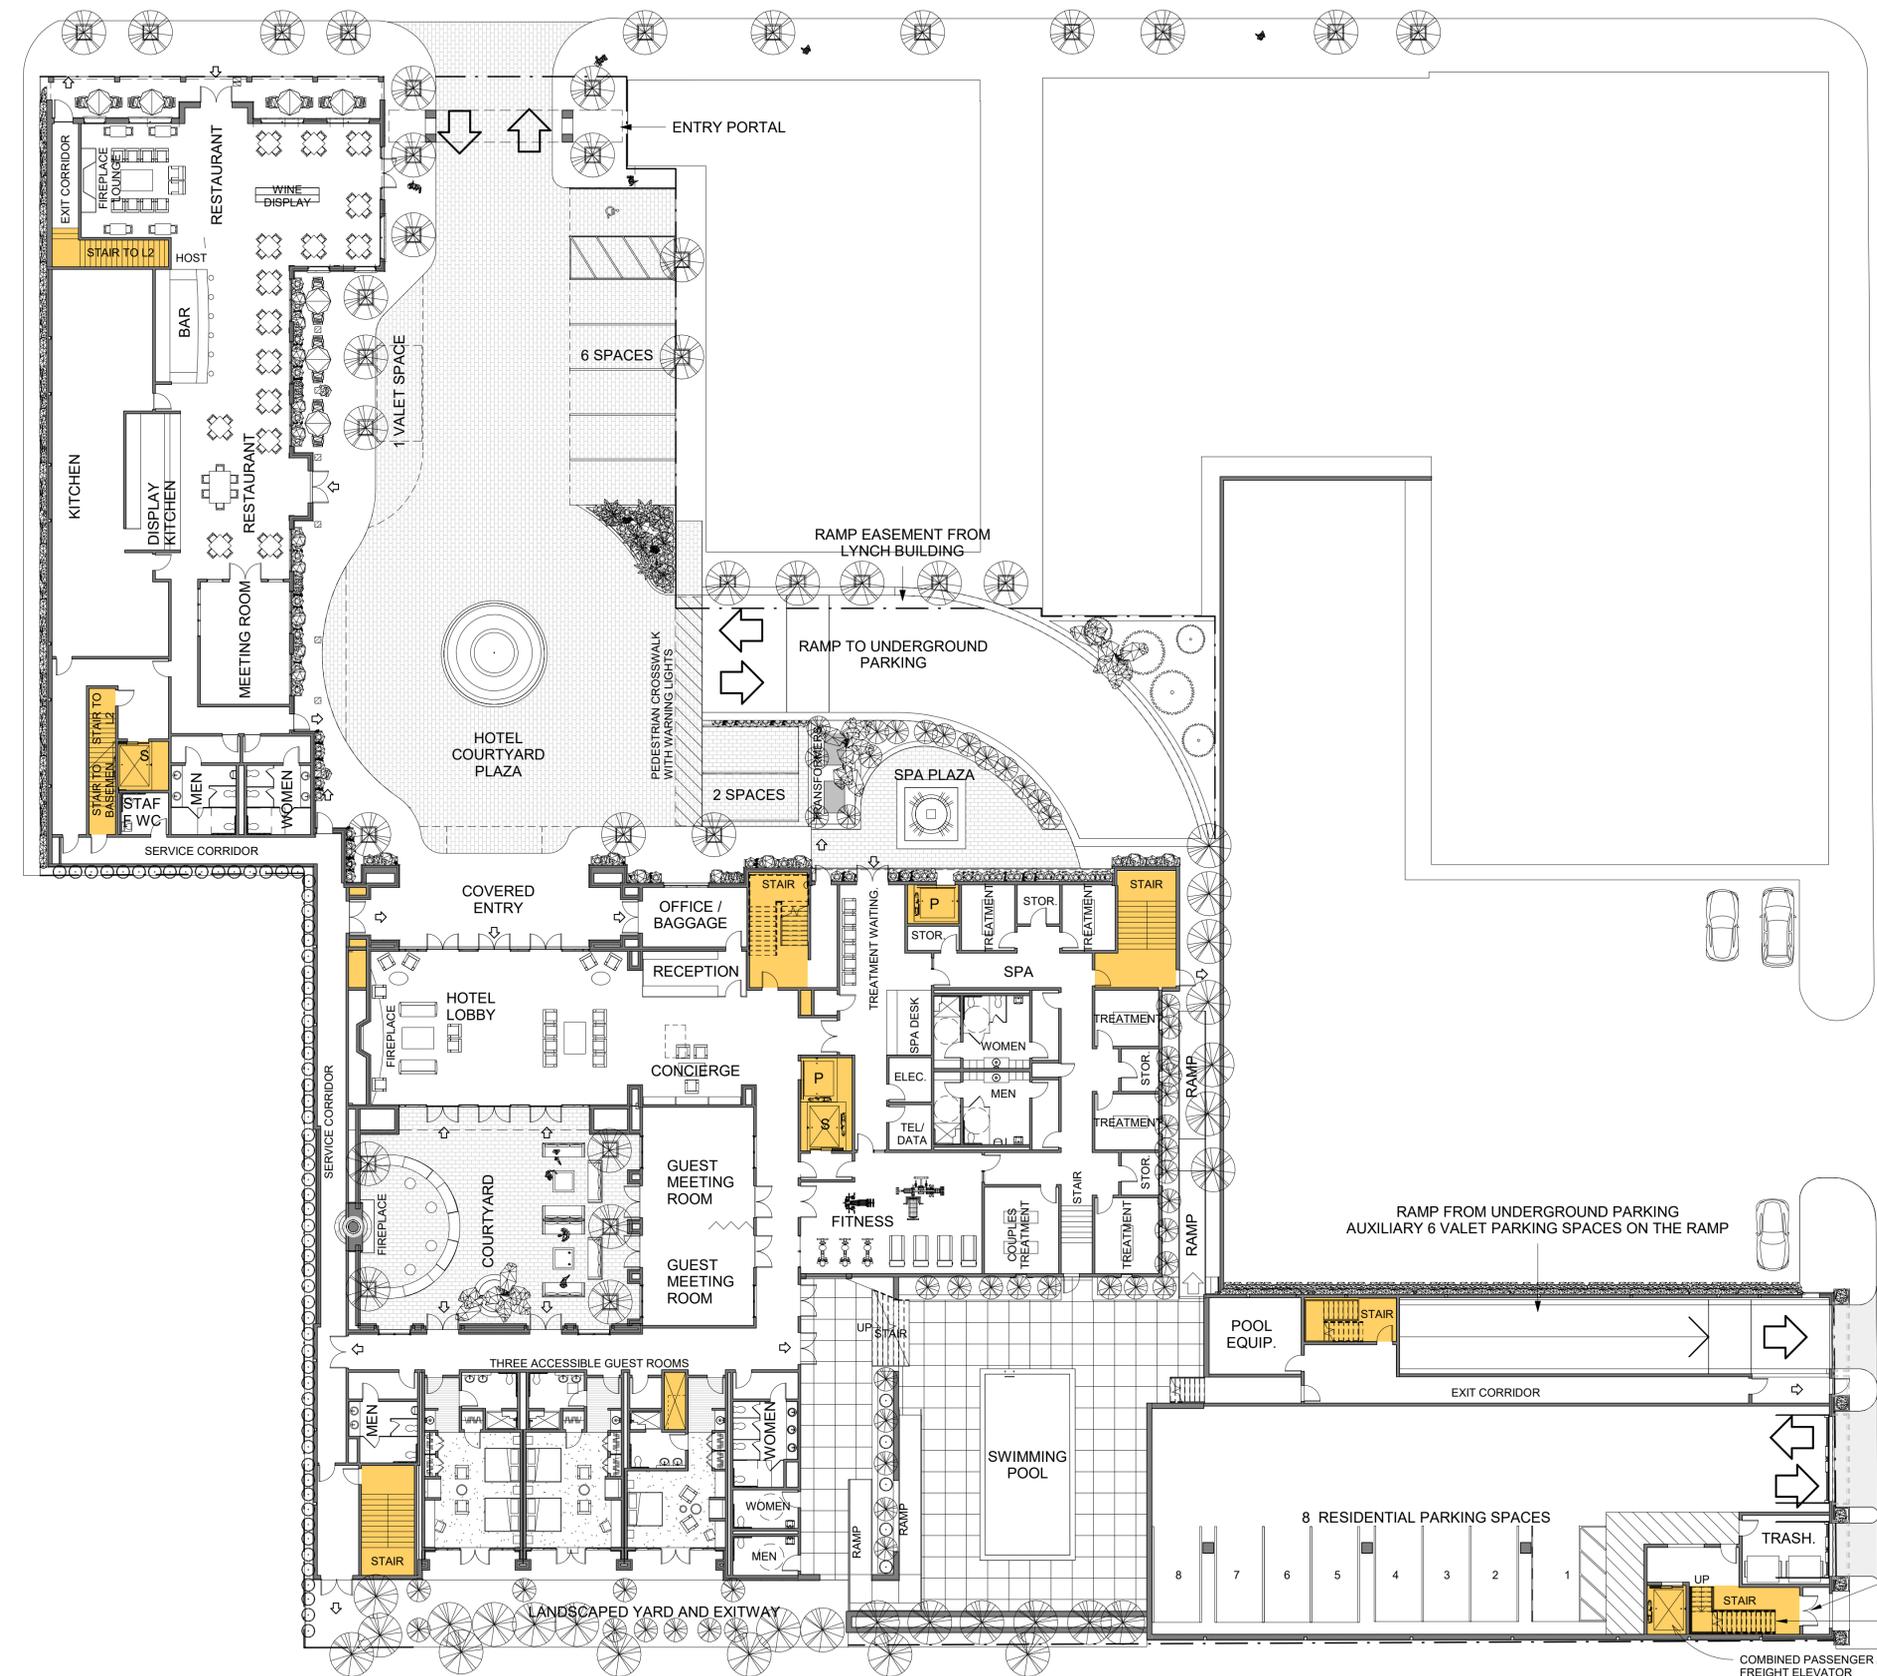

1 FIRST FLOOR PLAN  
1/16" = 1'-0"

Not For Construction

If this drawing is not 24" x 36", it is a reduced print - scale accordingly. All rights reserved. Material may not be reproduced in any form without permission from RossDrulisCusenbery Architecture, Inc.

8/5/2021 12:08:20 PM C:\Users\Stacey\Documents\Sonoma Hotel\_Central File 2020\_agas3T3V.rvt

**HOTEL PROJECT  
SONOMA**

Sonoma, CA

**Kenwood  
Investments LLC**

REVISIONS

No.	Description	Date

**USE PERMIT AUGUST  
2021**

Sheet Title

**SECOND FLOOR PLAN**

**GUESTROOM CALCULATION**

 
<b>1st Floor</b>	ADA Guest Rooms:	3
	Sub Total	3
<b>2nd Floor</b>	Standard Guest Rooms:	23
	Suites:	4
	Double Queen:	3
	Sub Total	30
<b>3rd Floor</b>	Standard Guest Rooms:	22
	Suites:	4
	Double Queen:	3
	Sub Total	29
<b>TOTAL GUESTROOMS</b>		<b>62</b>

Drawn By Author Checked By Checker

Scale:  
**As indicated**

Date:  
**08/05/2021**

Project No. Project Number



**A2.02**

Drawing No.

Not For Construction

If this drawing is not 24" x 36", it is a reduced print - scale accordingly. All rights reserved. Material may not be reproduced in any form without permission from RossDrulisCusenbery Architecture, Inc.



1 SECOND FLOOR PLAN  
1/16" = 1'-0"

**HOTEL PROJECT  
SONOMA**  
Sonoma, CA  
**Kenwood  
Investments LLC**

REVISIONS

No.	Description	Date

 
**USE PERMIT AUGUST  
2021**

Sheet Title  
**THIRD FLOOR PLAN**

**GUESTROOM CALCULATION**

<b>1st Floor</b>	ADA Guest Rooms:	3
	<b>Sub Total</b>	<b>3</b>
<b>2nd Floor</b>	Standard Guest Rooms:	23
	Suites:	4
	Double Queen:	3
	<b>Sub Total</b>	<b>30</b>
<b>3rd Floor</b>	Standard Guest Rooms:	22
	Suites:	4
	Double Queen:	3
	<b>Sub Total</b>	<b>29</b>
<b>TOTAL GUESTROOMS</b>		<b>62</b>

Drawn By Author  
Checked By Checker  
Scale:  
**As indicated**  
Date:  
**08/05/2021**  
Project No. Project Number



**A2.03**  
Drawing No.

Not For Construction



FIRST STREET WEST

① THIRD FLOOR  
1/16" = 1'-0"



HOTEL PLAZA COURTYARD - VIEW FROM WEST NAPA STREET



HOTEL RESTAURANT BUILDING - VIEW FROM HOTEL PLAZA COURTYARD



HOTEL EXTERIOR COURTYARD - NIGHT VIEW

**HOTEL PROJECT  
SONOMA**

Sonoma, CA

**Kenwood  
Investments LLC**

REVISIONS

No.	Description	Date

**USE PERMIT AUGUST  
2021**

Sheet Title

**CONCEPTUAL  
RENDERINGS**

Drawn By Author

Checked By Checker

Scale:

Date:  
08/05/2021

Project No. Project Number

**A3.00**  
Drawing No.

Not For Construction

If this drawing is not 24" x 36", it is a reduced print - scale accordingly. All rights reserved. Material may not be reproduced in any form without permission from RossDrulisCusenbery Architecture, Inc.

**HOTEL PROJECT  
SONOMA**

Sonoma, CA

**Kenwood  
Investments LLC**

REVISIONS

No.	Description	Date

**USE PERMIT AUGUST  
2021**

Sheet Title

**EXTERIOR ELEVATIONS -  
NORTH / EAST**

Drawn By Author Checked By Checker

Scale:

Date:  
08/05/2021

Project No. Project Number

**A3.01**

Drawing No.

If this drawing is not 24" x 36", it is a reduced print - scale accordingly. All rights reserved. Material may not be reproduced in any form without permission from RossDrulisCusenbery Architecture, Inc.



① NORTH ELEVATION



② EAST ELEVATION

**HOTEL PROJECT  
SONOMA**

Sonoma, CA

**Kenwood  
Investments LLC**

REVISIONS

No.	Description	Date

**USE PERMIT AUGUST  
2021**

Sheet Title

**EXTERIOR ELEVATIONS -  
SOUTH / WEST**

Drawn By Author Checked By Checker

Scale:

Date:  
08/05/2021

Project No. Project Number

**A3.02**  
Drawing No.

If this drawing is not 24" x 36", it is a reduced print - scale accordingly. All rights reserved. Material may not be reproduced in any form without permission from RossDrulisCusenbery Architecture, Inc.



① SOUTH ELEVATION



② WEST ELEVATION

Not For Construction

**HOTEL PROJECT  
SONOMA**  
Sonoma, CA  
**Kenwood  
Investments LLC**

REVISIONS

No.	Description	Date

**USE PERMIT AUGUST  
2021**

Sheet Title  
**VISUAL SIMULATIONS**


Drawn By Author      Checked By Checker  
Scale:  
Date:  
**08/05/2021**  
Project No.    Project Number

**A3.03**  
Drawing No.

If this drawing is not 24" x 36", it is a reduced print - scale accordingly. All rights reserved. Material may not be reproduced in any form without permission from RossDrulisCusenbery Architecture, Inc.



CONTEXT - WEST NAPA STREET BETWEEN 1st ST WEST and 2nd ST WEST

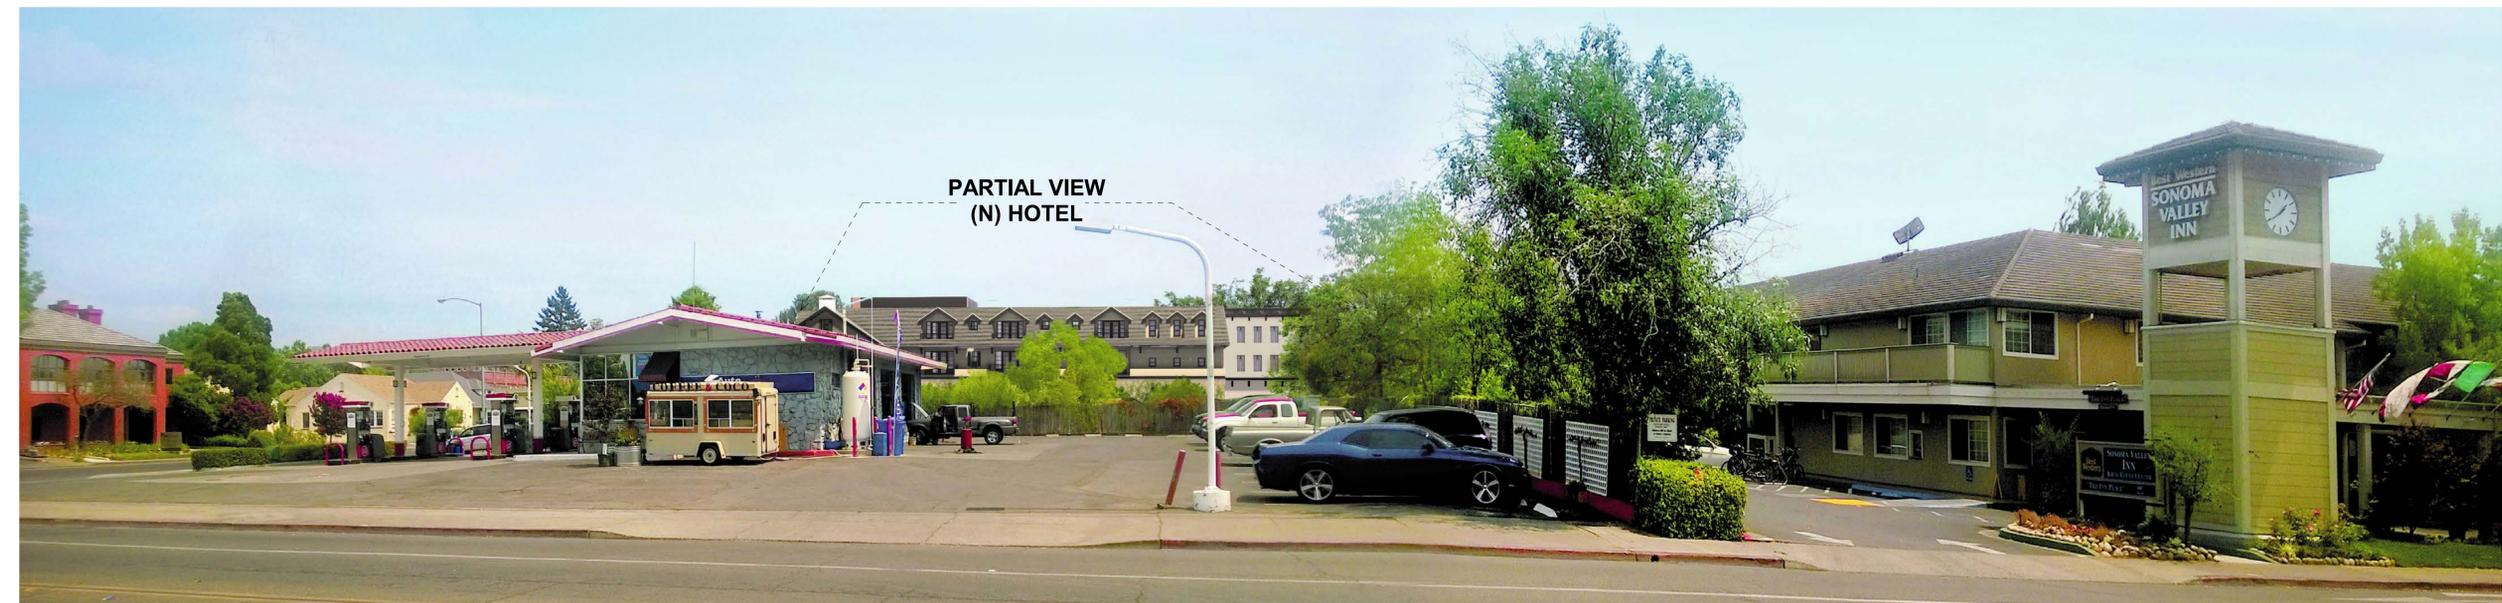

VIEW EAST - SECOND STREET WEST



VIEW EAST - WEST NAPA STREET

8/5/2021 12:08:57 PM C:\Users\Stacie\Documents\Sonoma Hotel\_Central File 2020\_agas3T3V.rvt

Not For Construction



VIEW EAST - WEST NAPA STREET



VIEW SOUTH - WEST NAPA STREET



VIEW WEST - WEST NAPA STREET



VIEW WEST - FIRST STREET

**HOTEL PROJECT  
SONOMA**

Sonoma, CA

**Kenwood  
Investments LLC**

REVISIONS

No.	Description	Date

**USE PERMIT AUGUST  
2021**

Sheet Title  
**VISUAL SIMULATIONS**

Drawn By Author      Checked By Checker

Scale:

Date:  
08/05/2021

Project No.    Project Number

**A3.04**  
Drawing No.

**HOTEL PROJECT  
SONOMA**

Sonoma, CA

**Kenwood  
Investments LLC**

REVISIONS

No.	Description	Date

**USE PERMIT AUGUST  
2021**

Sheet Title

**BUILDING SECTIONS**

Drawn By Author      Checked By Checker


Scale:  
3/32" = 1'-0"

Date:  
08/05/2021


Project No.    Project Number

**A3.51**  
Drawing No.


If this drawing is not 24" x 36", it is a reduced print - scale accordingly. All rights reserved. Material may not be reproduced in any form without permission from RossDrulisCusenbery Architecture, Inc.

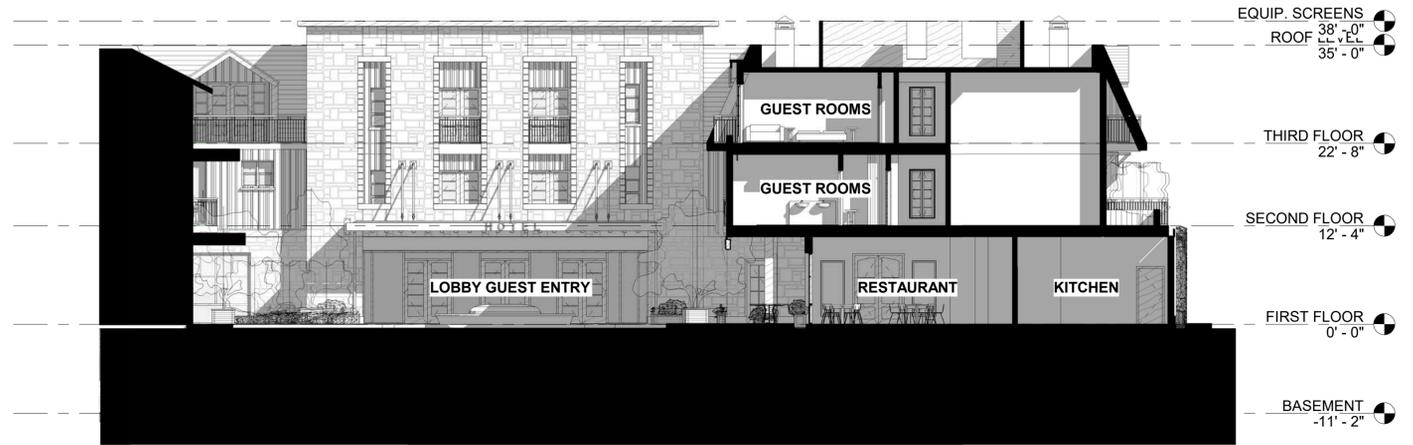

③ BUILDING SECTION- EW- RESTAURANT  
3/32" = 1'-0"

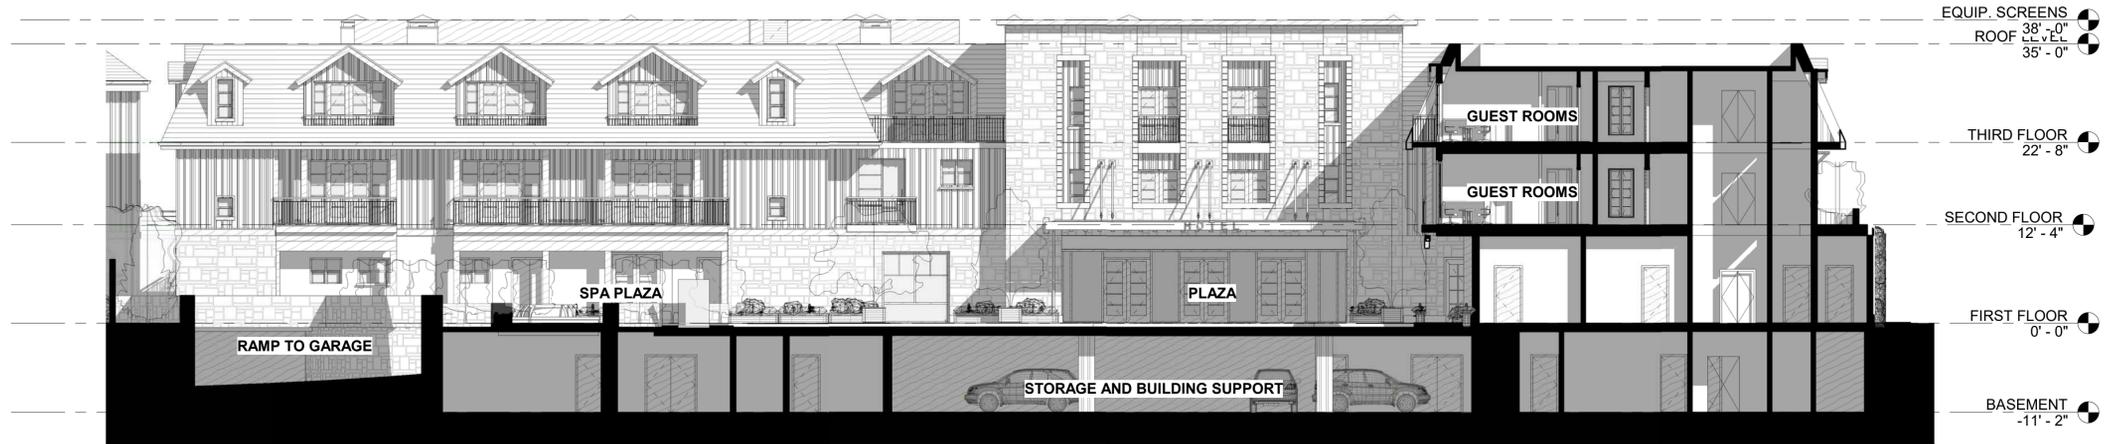

① BUILDING SECTION- EW- HOTEL PLAZA  
3/32" = 1'-0"

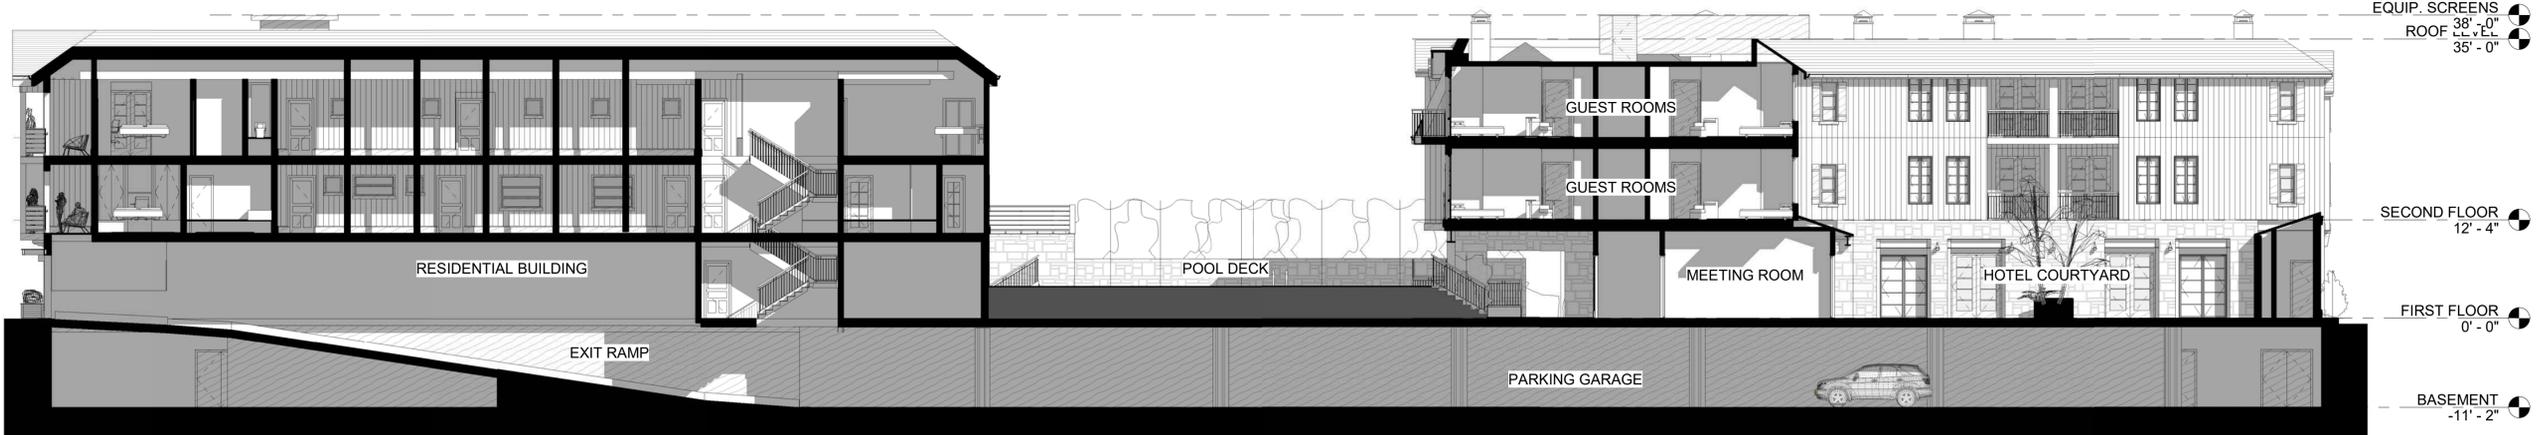

② BUILDING SECTION- EW- COURTYARD AND POOL DECK  
3/32" = 1'-0"

Not For Construction

**HOTEL PROJECT  
SONOMA**

Sonoma, CA

**Kenwood  
Investments LLC**

REVISIONS

No.	Description	Date

**USE PERMIT AUGUST  
2021**

Sheet Title

**BUILDING SECTIONS**

Drawn By Author      Checked By Checker

Scale:  
3/32" = 1'-0"


Date:  
08/05/2021

Project No.    Project Number


**A3.52**

Drawing No.

If this drawing is not 24" x 36", it is a reduced print - scale accordingly. All rights reserved. Material may not be reproduced in any form without permission from RossDrulisCusenbery Architecture, Inc.

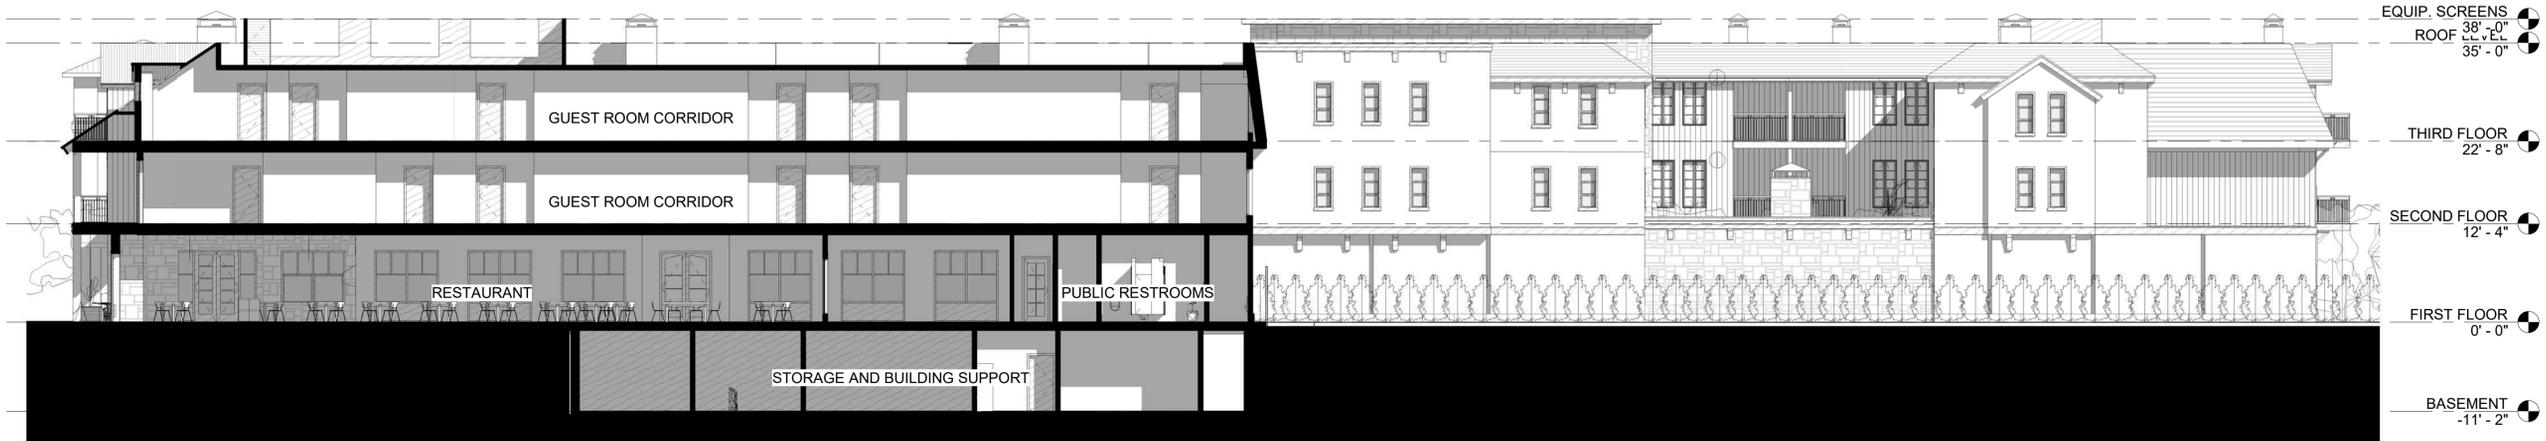

② BUILDING SECTION- NS- BUILDING A  
3/32" = 1'-0"

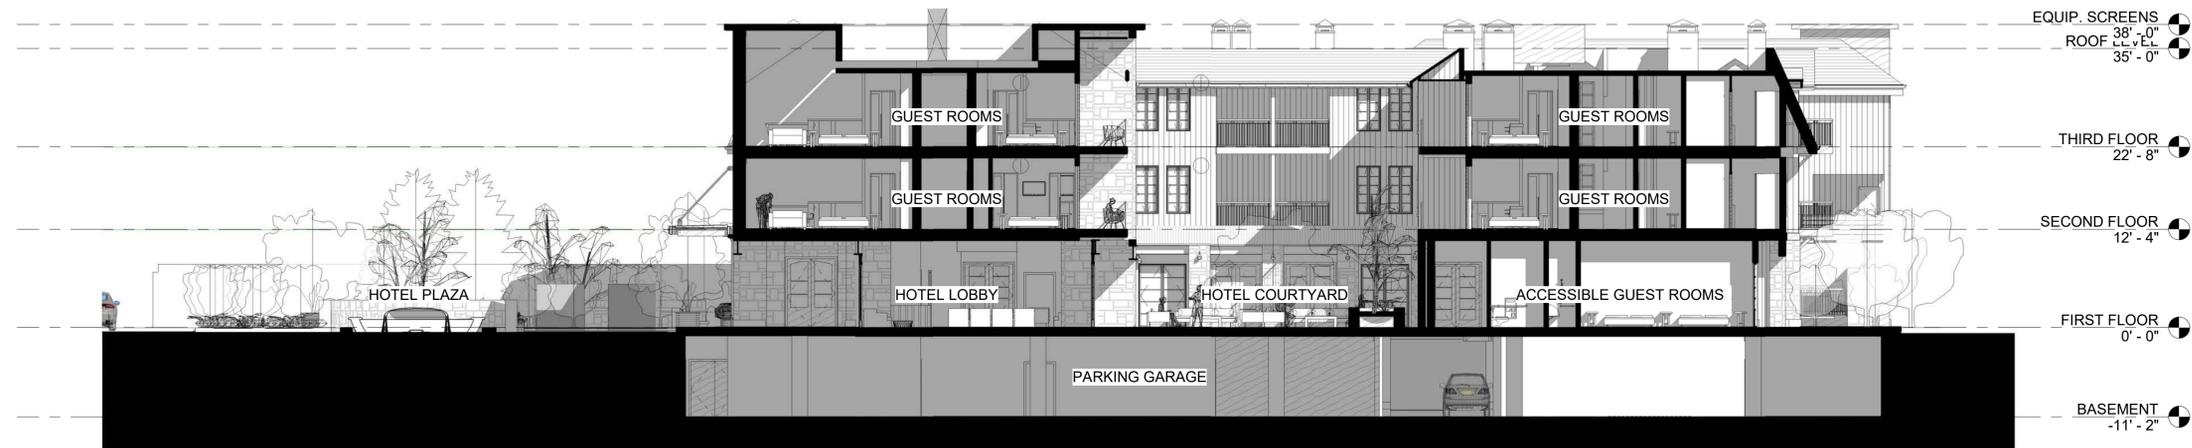

① BUILDING SECTION- NS- BUILDING B COURTYARD  
3/32" = 1'-0"



③ BUILDING SECTION- NS- POOL DECK  
3/32" = 1'-0"

Not For Construction