


**Food Service
Consultants**
JRA FOODSERVICE CONSULTANTS, LLC
400 E. HILL STREET, SUITE 200
GRAND RAPIDS, MI 49503
PH: (617) 454-4433
FAX: (616) 454-4433
E: JRA@JRA-FOODSERVICEDESIGN.COM

EQUIPMENT SCHEDULE

Item	Qty	Equipment Category
101	1	WALK-IN COOLER/BEER COOLER
101A	2	COOLER COIL
101B	2	COOLER COMPRESSOR
102	1	SPARE NUMBER
103	11	SHELVING
104	1	MOP SINK WITH SERVICE FAUCET
105	2	PAN RACK
106	1	SPARE NUMBER
107	1	FIRE PROTECTION SYSTEM
108	1	SPARE NUMBER
109	1	ICE MAKER - 1020 LBS
109A	1	ICEMAKER FILTER SYSTEM
109B	1	ICE BIN
109C	1	REMOTE CONDENSER
201	2	TRASH BIN - BY OWNER
202	1	WORK TABLE
203	1	FOOD PROCESSOR
204	1	MIXER - 20 QUART
204A	1	MIXER STAND
301	1	HOOD
301A	1	EXHAUST FAN & CURB
301B	1	MAKE UP AIR UNIT
302	1	RANGE - SIX BURNER
303	1	CONVECTION OVEN - DOUBLE DECK
304	1	GRIDDLE
304A	1	GRIDDLE STAND
305	1	CHARBROILER
305A	1	CHARBROILER STAND
306	2	FRYER
307	1	FREEZER
401A	1	HOT FOOD TABLE
401B	1	PIZZA TOP REFRIGERATOR
401C	1	UTILITY COUNTER
401D	1	DISH STORAGE CABINET
401E	1	DOUBLE OVERSHELF & HEAT LAMP
402	1	SPARE NUMBER
403	1	SLIP PRINTER - BY OWNER
404	1	SPARE NUMBER
405	1	COFFEE MAKER SATELLITE - BY PURVEYOR
406	1	SODA RACK & CARBONATOR - BY PURVEYOR
407	3	CASH REGISTER/POS - BY OWNER
501	1	SPARE NUMBER
502	1	HAND SINK
503	1	POT SINK
504	1	CLEAN DISHABLE
504A	1	SOILED DISHABLE
505	1	SPARE NUMBER
506	1	DISHWASHER & BOOSTER HEATER
506A	1	DRYIN WATER TEMPERING KIT
507	1	DISPOSAL
508	1	DISHWASHER HOOD
508A	1	EXHAUST FAN
601	1	FRONT BAR TOP & DIE WALL - BY MILL WORK
602	1	REAR BAR TOP & DIE WALL - BY MILL WORK
603	1	BAR SERVICE STATION & ICE BIN
604	1	BLENDER
605	2	TRASH BIN - BY OWNER
606	2	REFRIGERATED BACK BAR
607	3	UNDERBAR DRAINBOARD
608	1	UNDERBAR ICE BIN
609	3	SODA HOSE DISPENSERS - BY PURVEYOR
610	1	CASH REGISTER STAND
611	1	UNDERBAR SINK W/BOTTLE RAIL
612	1	DRY BACKBAR
613	1	UNDER BAR BEER TAPS - 6 FAUCETS
613A	1	UNDERBAR BEER DRAINER
614	1	DRIFT BEER POWERPACK
615	1	CASH REGISTER/POS - BY OWNER
615A	1	CASH REGISTER/POS - BY OWNER
616	4	KEG RACK
617	1	SLIP PRINTER - BY OWNER
617A	1	SLIP PRINTER - BY OWNER
618	1	UNDERBAR LIQUOR DISPLAY
619	1	UNDERBAR HAND SINK
620	1	UNDERBAR DUMP SINK

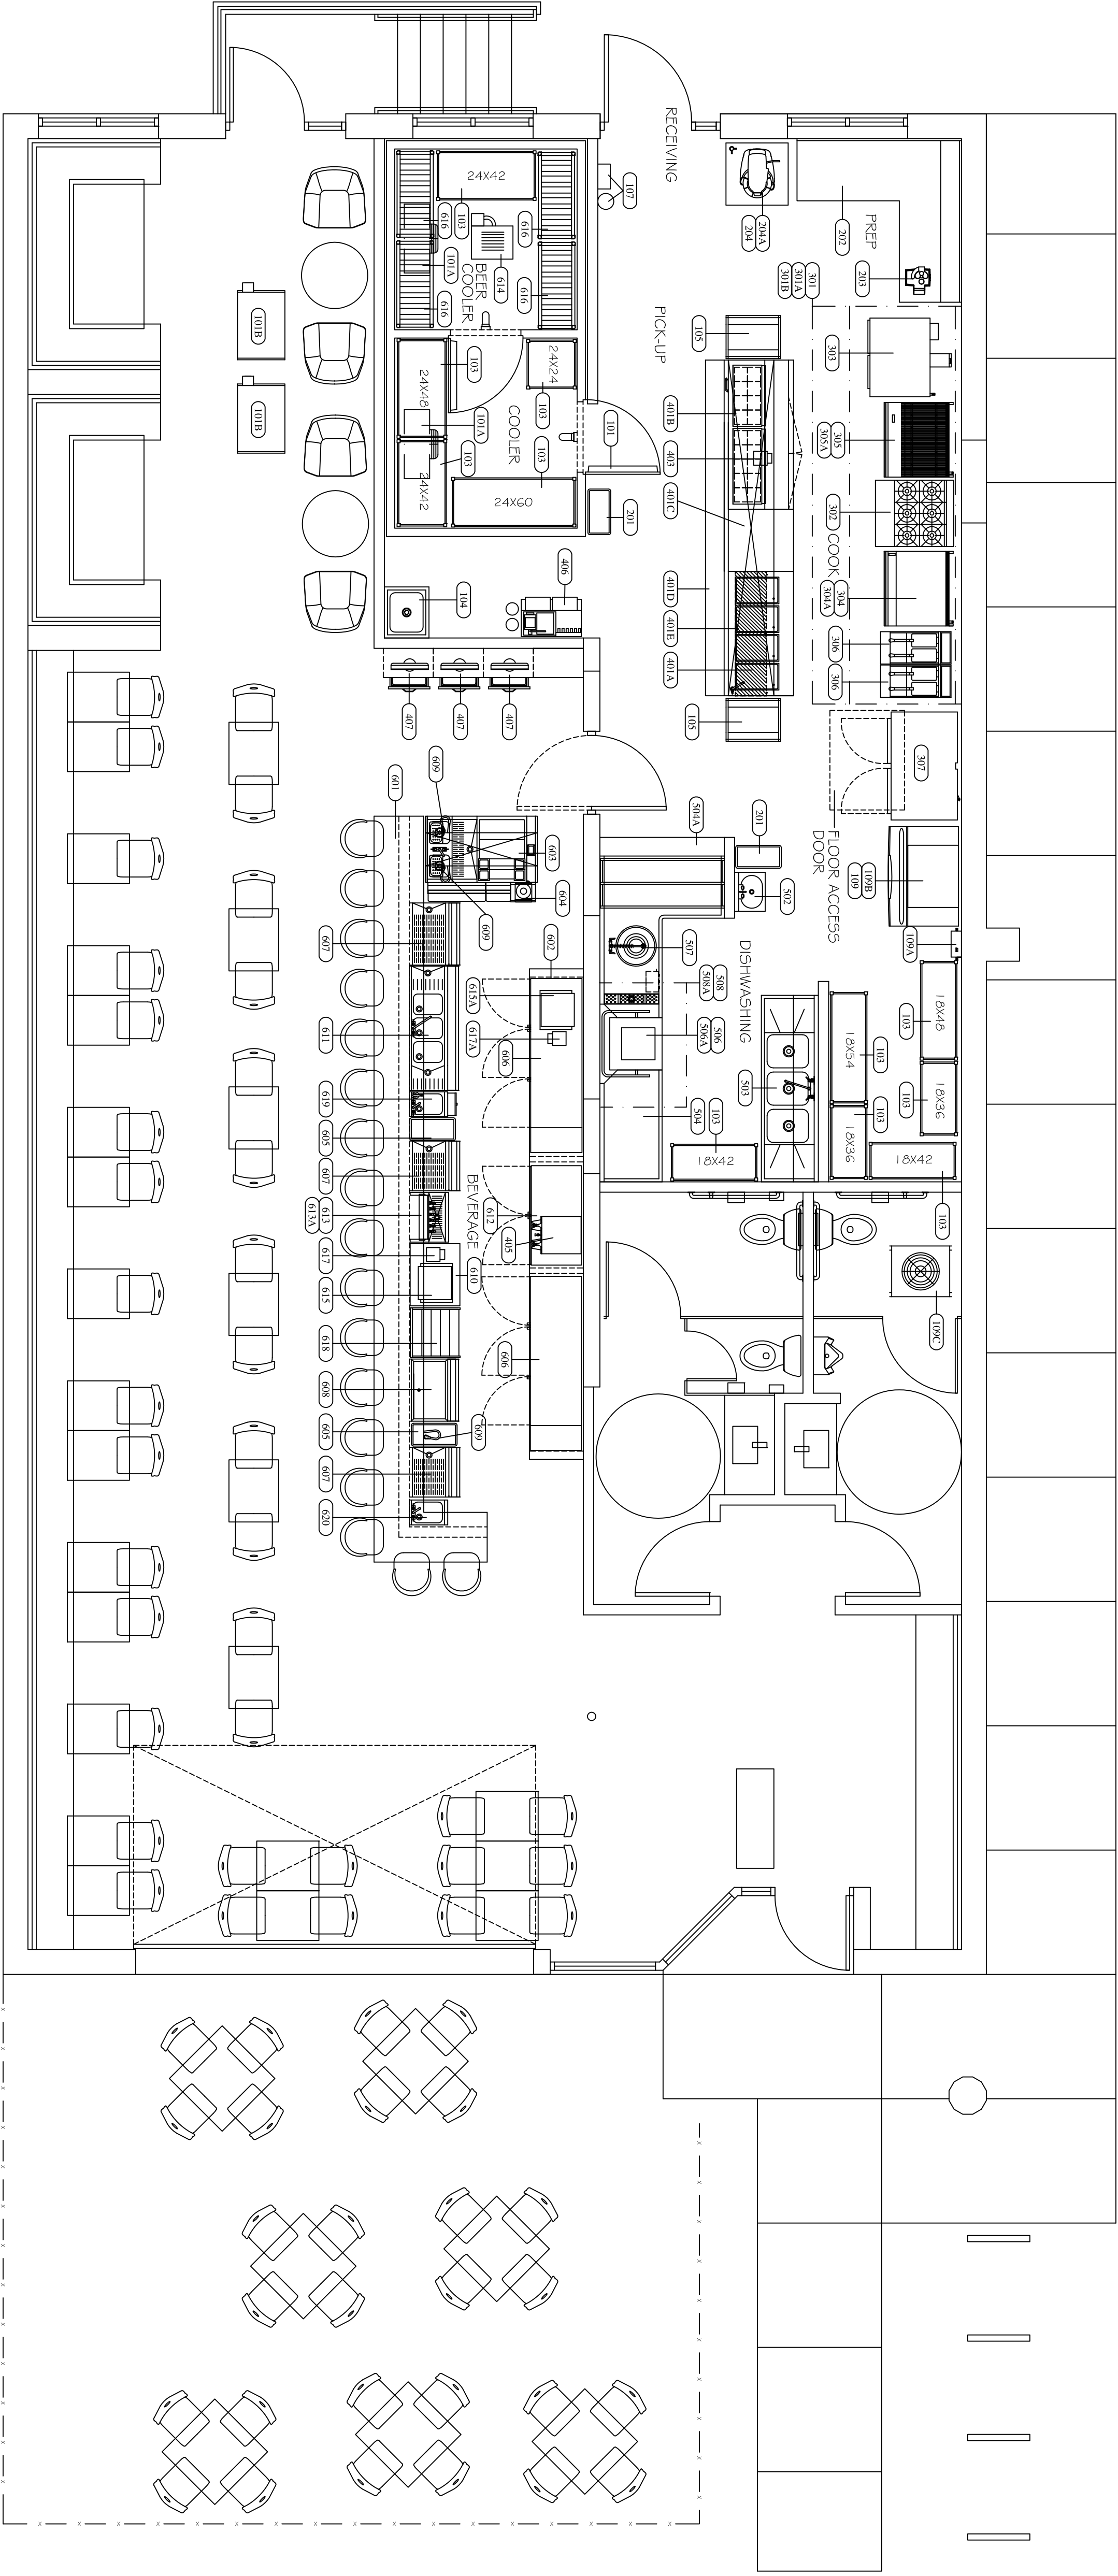

ARCHITECT:
LOTT3METZ ARCHITECTURE
645 CHERRY SE
GRAND RAPIDS, MI 49503

PROJECT:
CITIZEN RESTAURANT
GRAND RAPIDS, MICHIGAN

SHEET TITLE:
FOODSERVICE
EQUIPMENT
FLOOR PLAN
SCALE 1/4" = 1'-0"

DATE	PROJECT
CODE	PHASE
10/27/16	SCHEMATIC
CRHP	DESIGN
11/07/16	SCHEMATIC
CKEP	DESIGN
11/18/16	SCHEMATIC
CRFP	DESIGN

THIS DRAWING IS THE PROPERTY
OF JRA FOODSERVICE CONSULTANTS, LLC
AND IS NOT TO BE
REPRODUCED, OR REUSED WITHOUT
WRITTEN PERMISSION
COPYRIGHT 2016

SHEET NUMBER:

FSE-1