

Kentwood Family Pharmacy

706 Avenue G (Hwy 38)
Kentwood, LA

project number
pa 2218
date of issue
07.13.2022
project phase
Construction Documents
revision no. revision date


drawn by
TP
THIS DRAWING IS AN INSTRUMENT OF SERVICE &
THE PROPERTY OF PISTORIUSASSOCIATES, LLC




drawing title
FLOOR PLAN
drawing no.

A-101

REFLECTED CEILING PLAN LEGEND

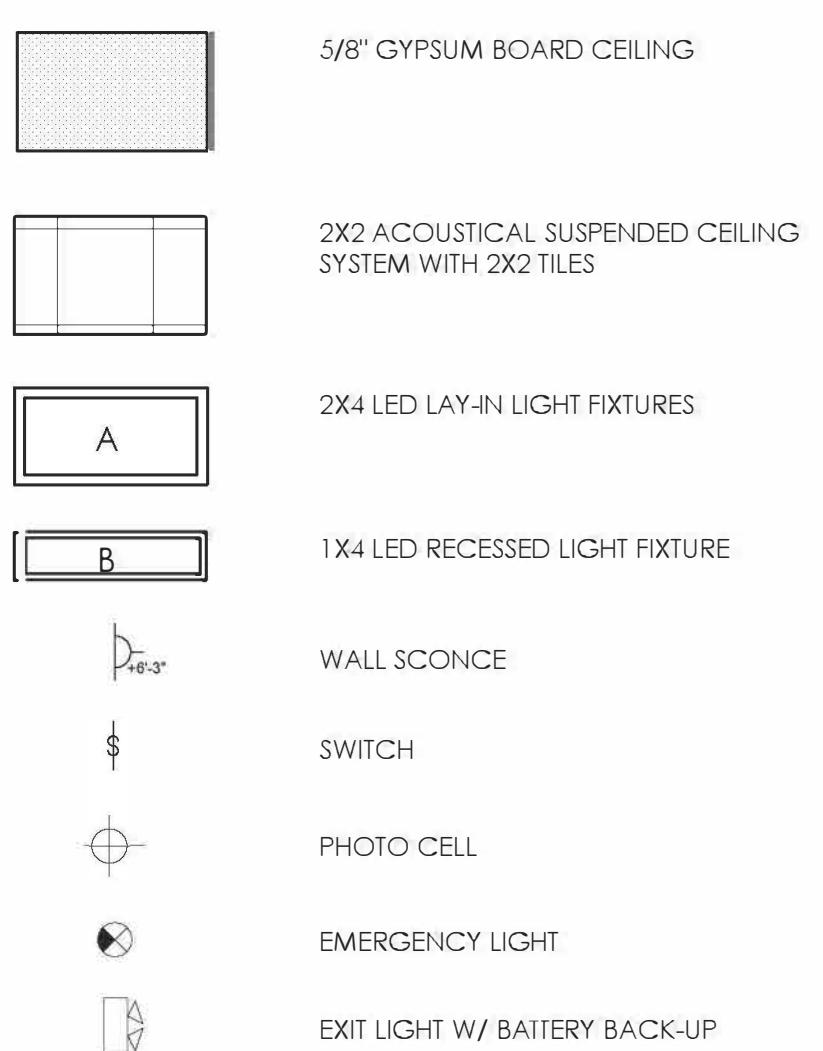


FLOOR PLAN LEGEND

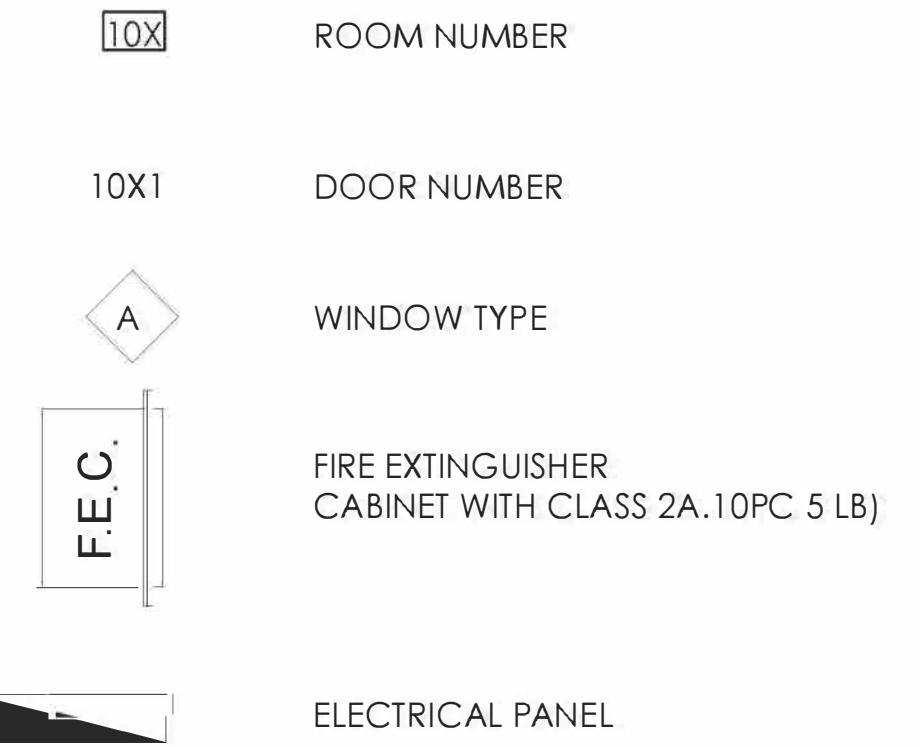

ELECTRICAL INFORMATION

SERVICE: 120/240V, 1 PH., 3 W
MAIN: 200 AMP
ELECTRICAL CONTROLLER TO VERIFY
PANEL: FLUSH MOUNT, 42 CIRCUITS
CIRCUITRY SHALL BE AS SHOWN, AND VERIFIED BY ELECTRICAL CONTROLLER
NOTE: ALL SWITCHES SHALL BE LOCATED WITHIN 6' OF DOOR FRAME OR CORNER OF WALL. VERIFY ALL LOCATIONS WITH OWNER PRIOR TO INSTALLATION.
ALL SMOKE DETECTORS SHALL BE INTERCONNECTED WITH BATTERY BACK-UP AND CARBON MONOXIDE DETECTION
ALL EMERGENCY AND EXIT LIGHTING SHALL HAVE BATTERY BACK-UP - PER IBC 1006.3
ALL SWITCHES, CONTROLS, OUTLETS, ETC. SHALL BE MOUNTED PER ADA GUIDELINES.
PROVIDE FIRE-RATED BOXES AND SEAL AS REQ'D AT ALL RATED WALLS, TYPICAL
PROVIDE A 125V IPH 15 OR 20A RECEPTACLE IN ACCESSIBLE LOCATION FOR HVAC SERVICE - LOCATE WITHIN 25' OF EQUIPMENT - CONNECT TO THE LOAD SIDE OF THE EQUIPMENT MEANS OF DISCONNECT

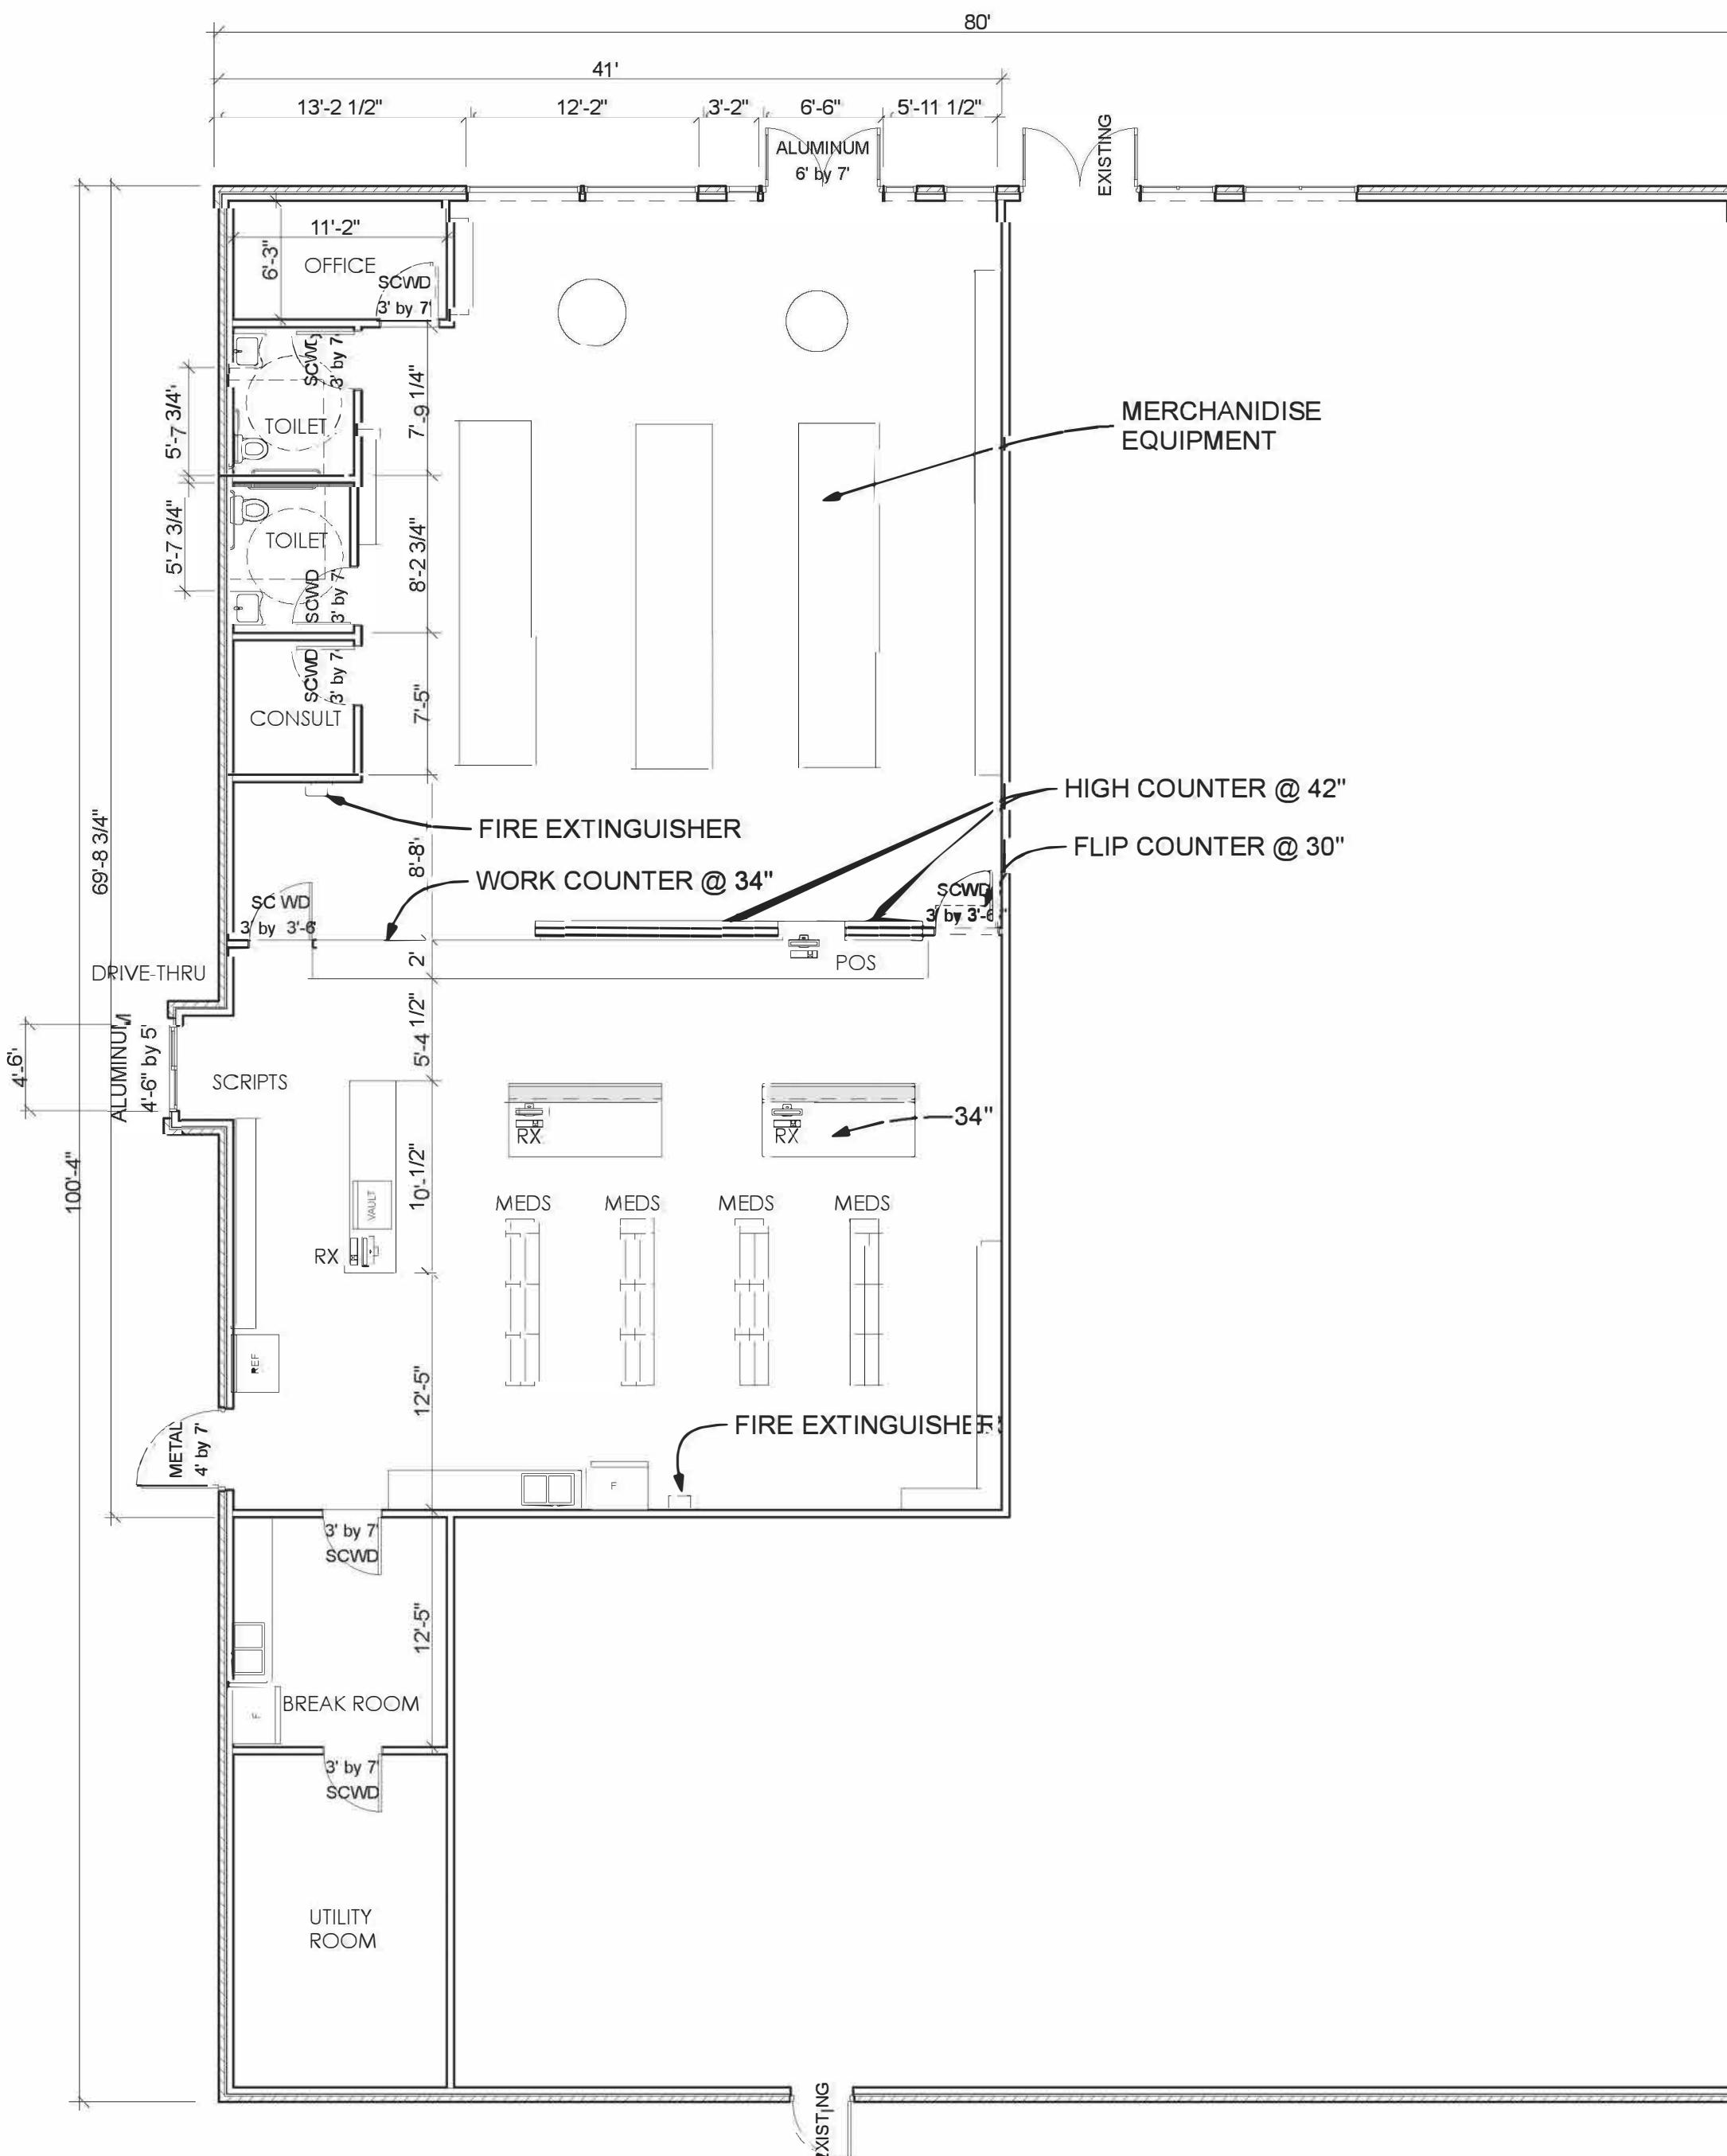

CEILING PLAN

SCALE: 1/8" = 1'-0"

0 4' 8' 12' 16'

FLOOR PLAN

SCALE: 1/8" = 1'-0"


0 4' 8' 12'

AVAILABLE SPACE

CEILING PLAN

SCALE: 1/8" = 1'-0"

0 4' 8' 12' 16'

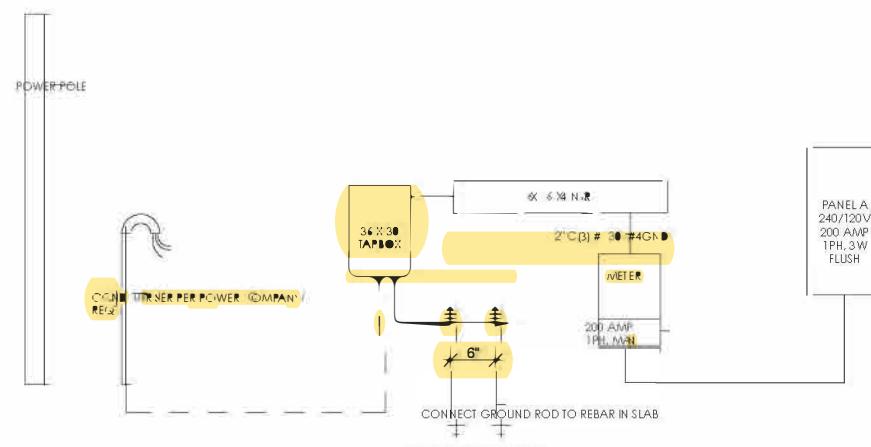

360 Therapy

