



BROUSSARD PEÇOT ARCHITECTS

SCALE 1/8"=1'-0"


SQUARE FOOTAGE
5600 SQ. FT.

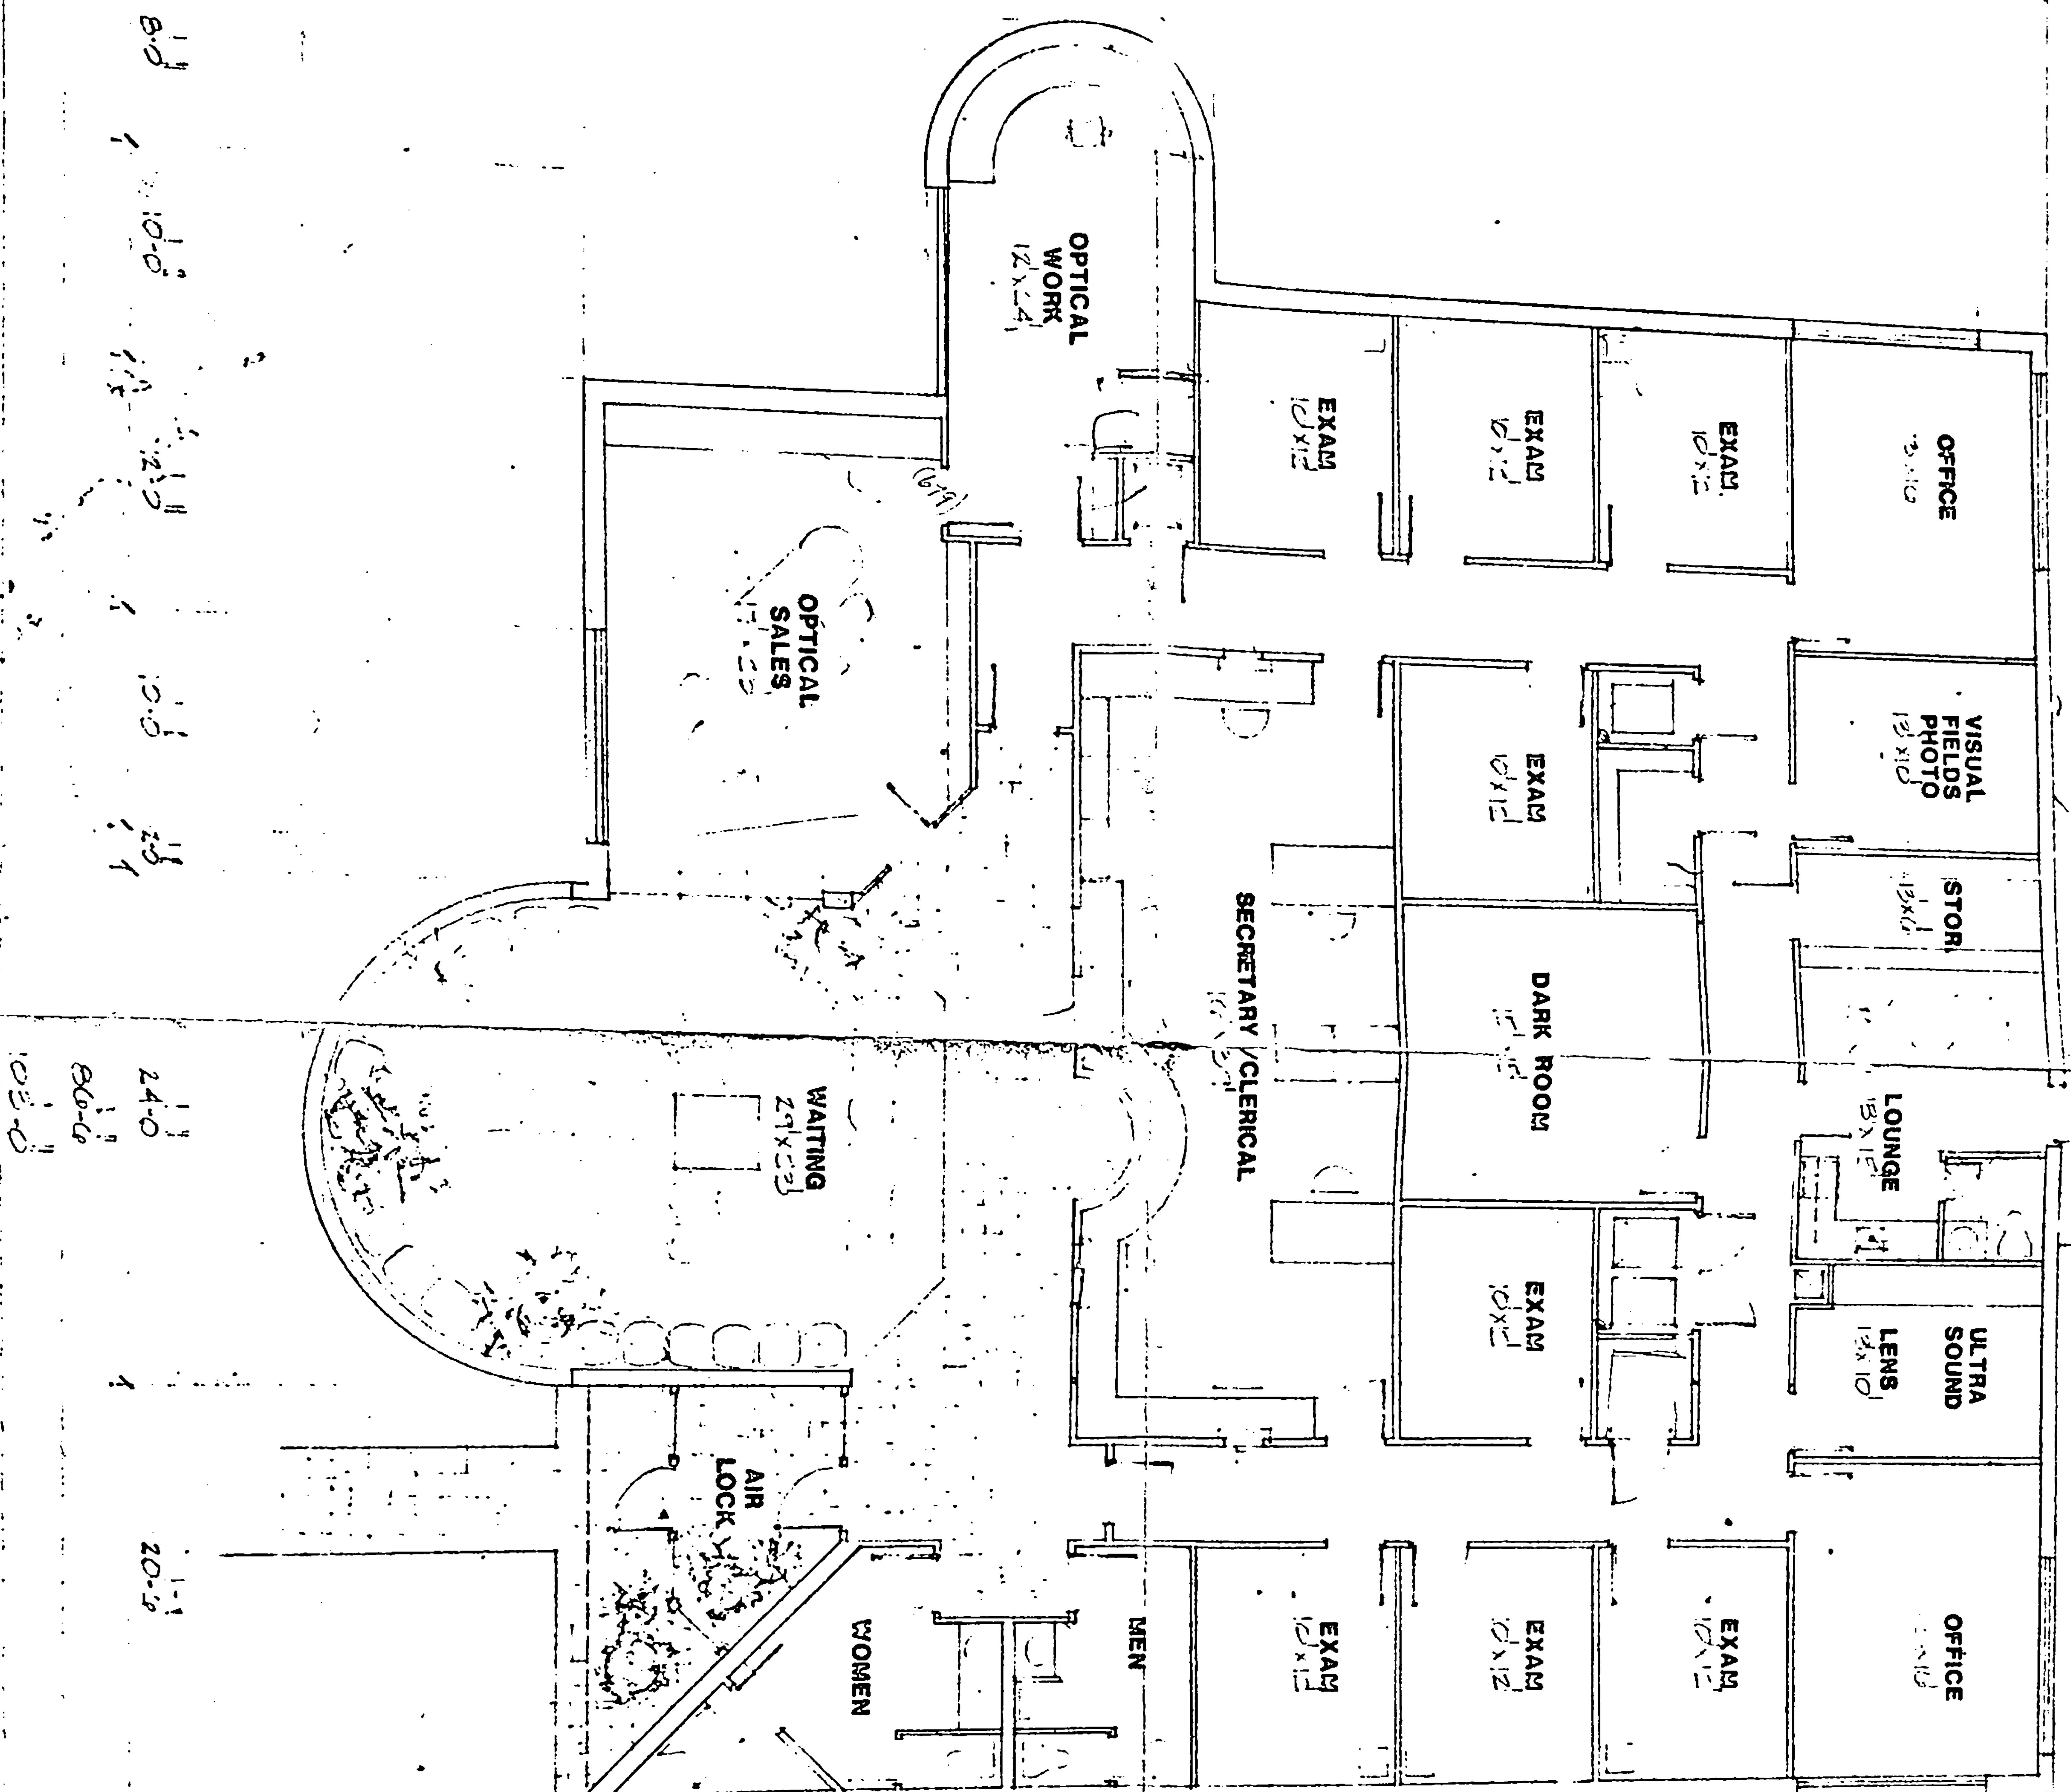

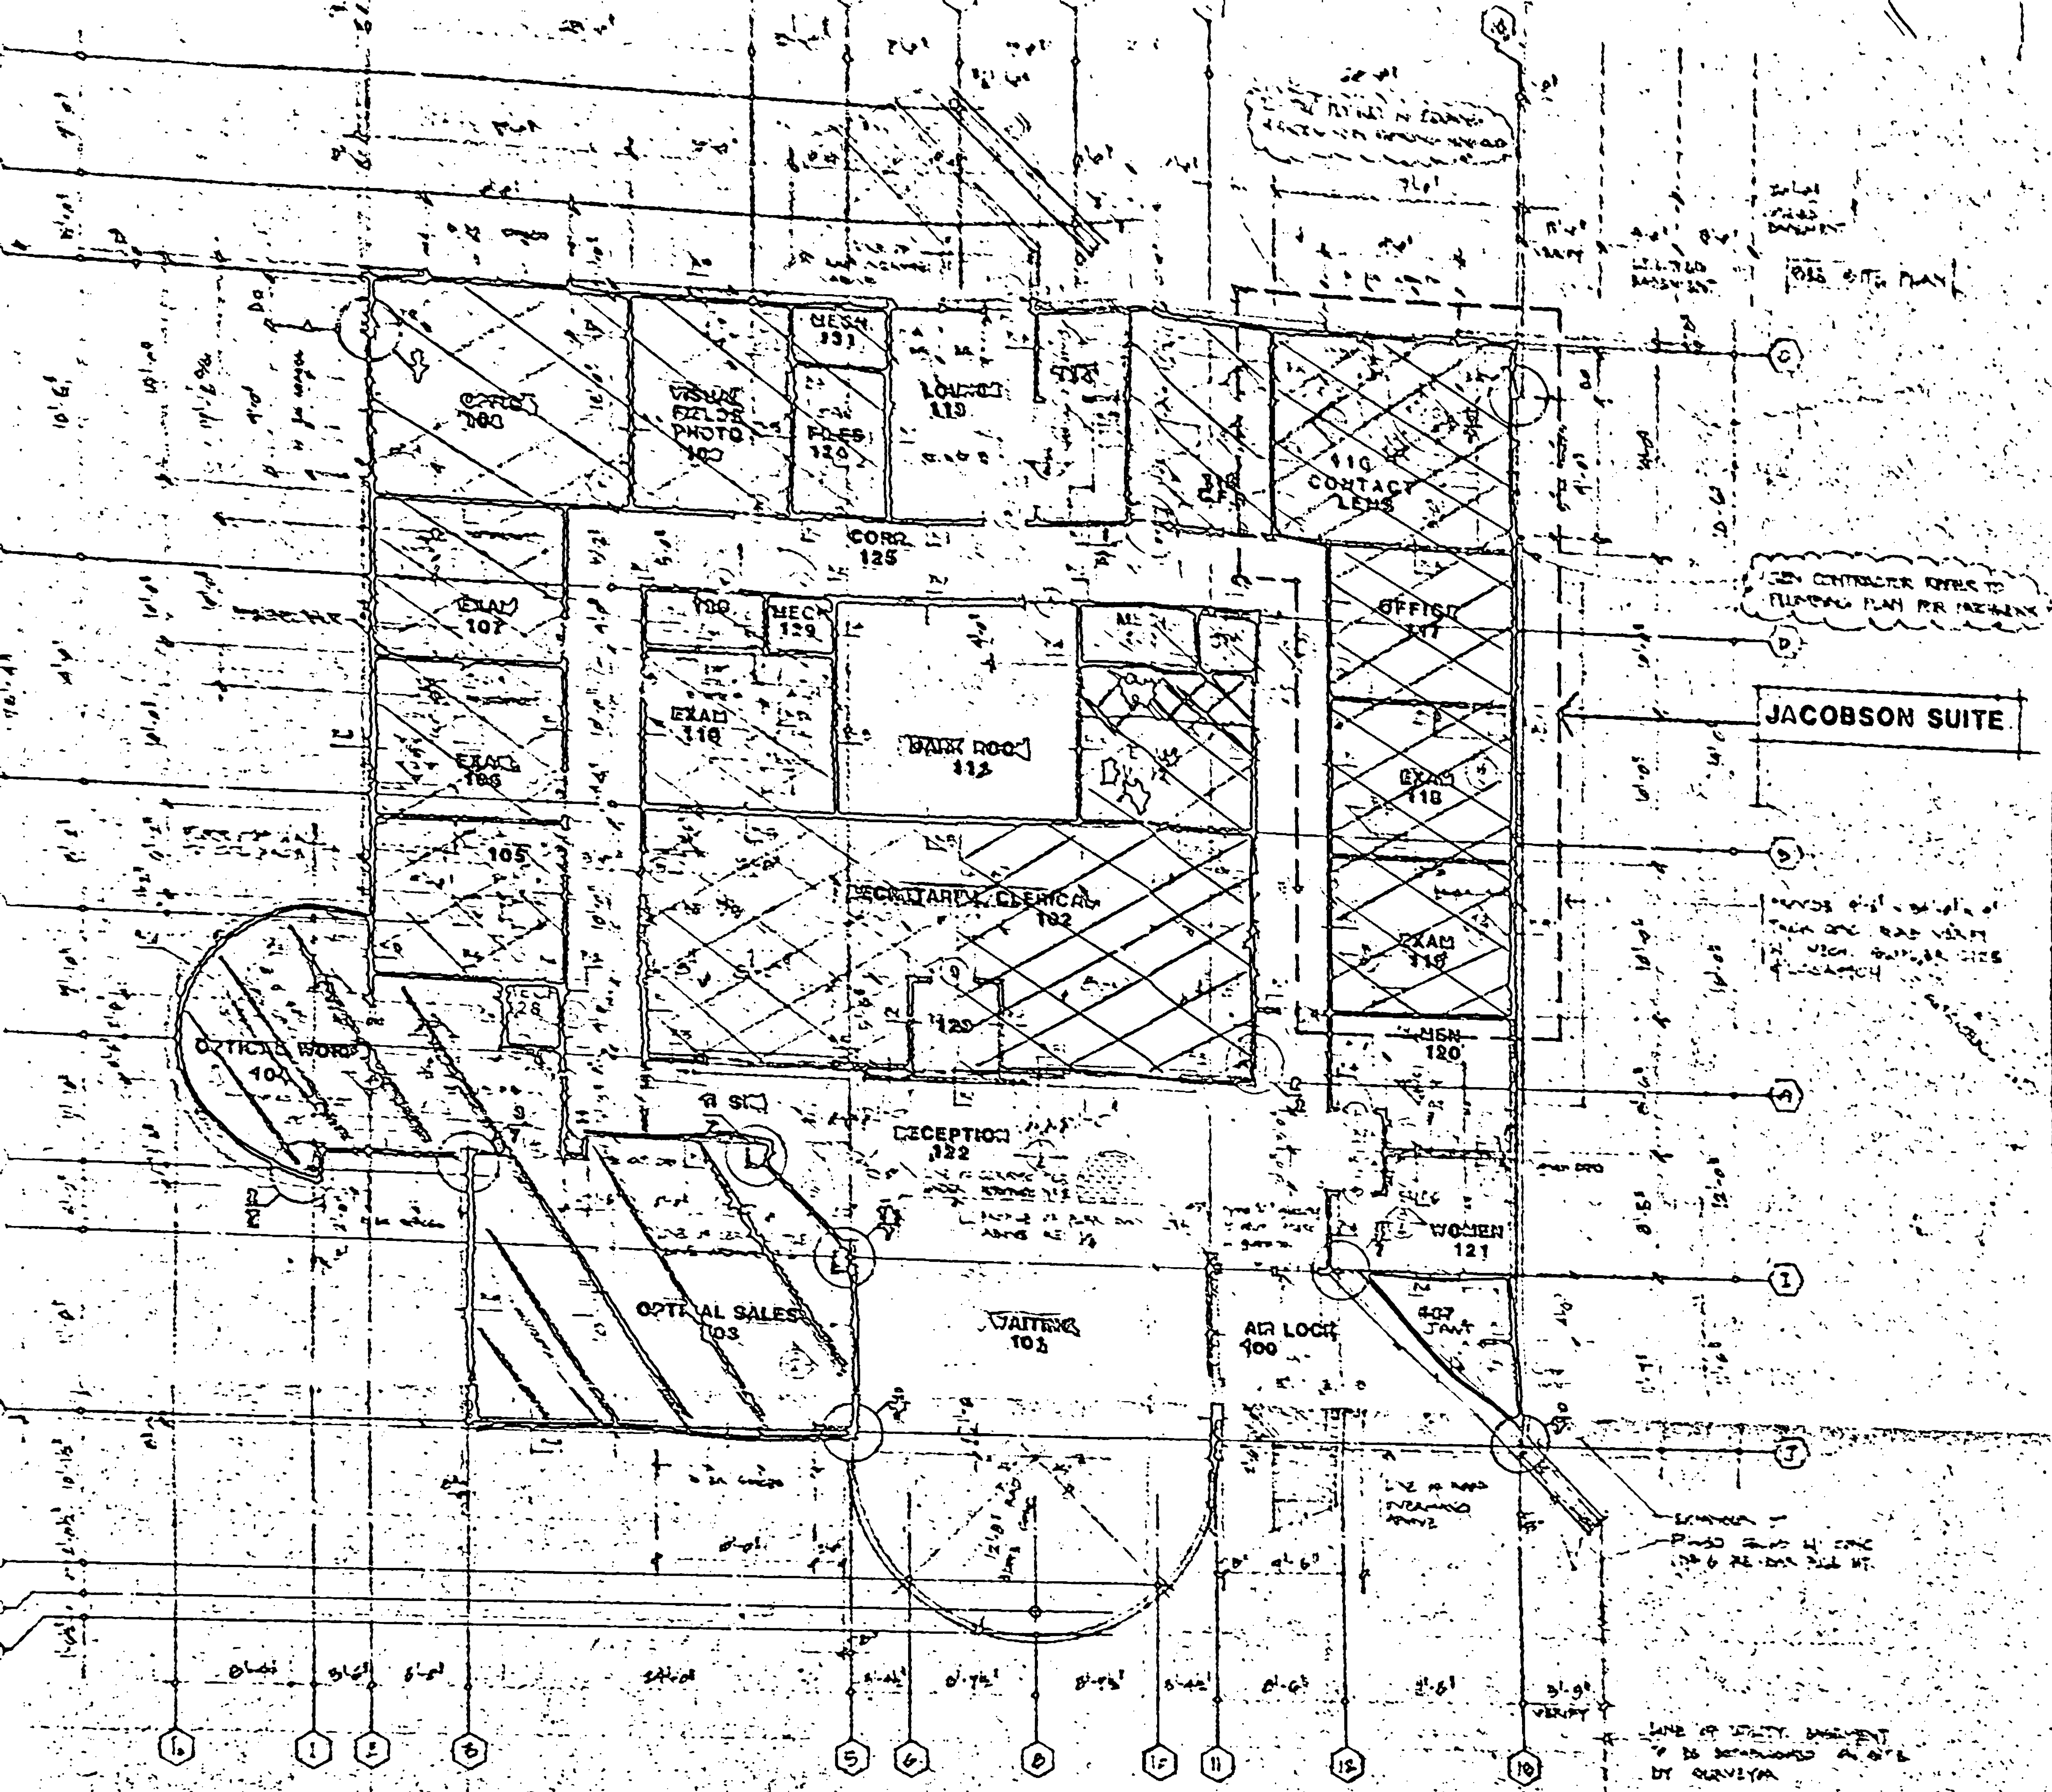


FLOOR PLAN

SCALE: 1/4" = 1'-0"

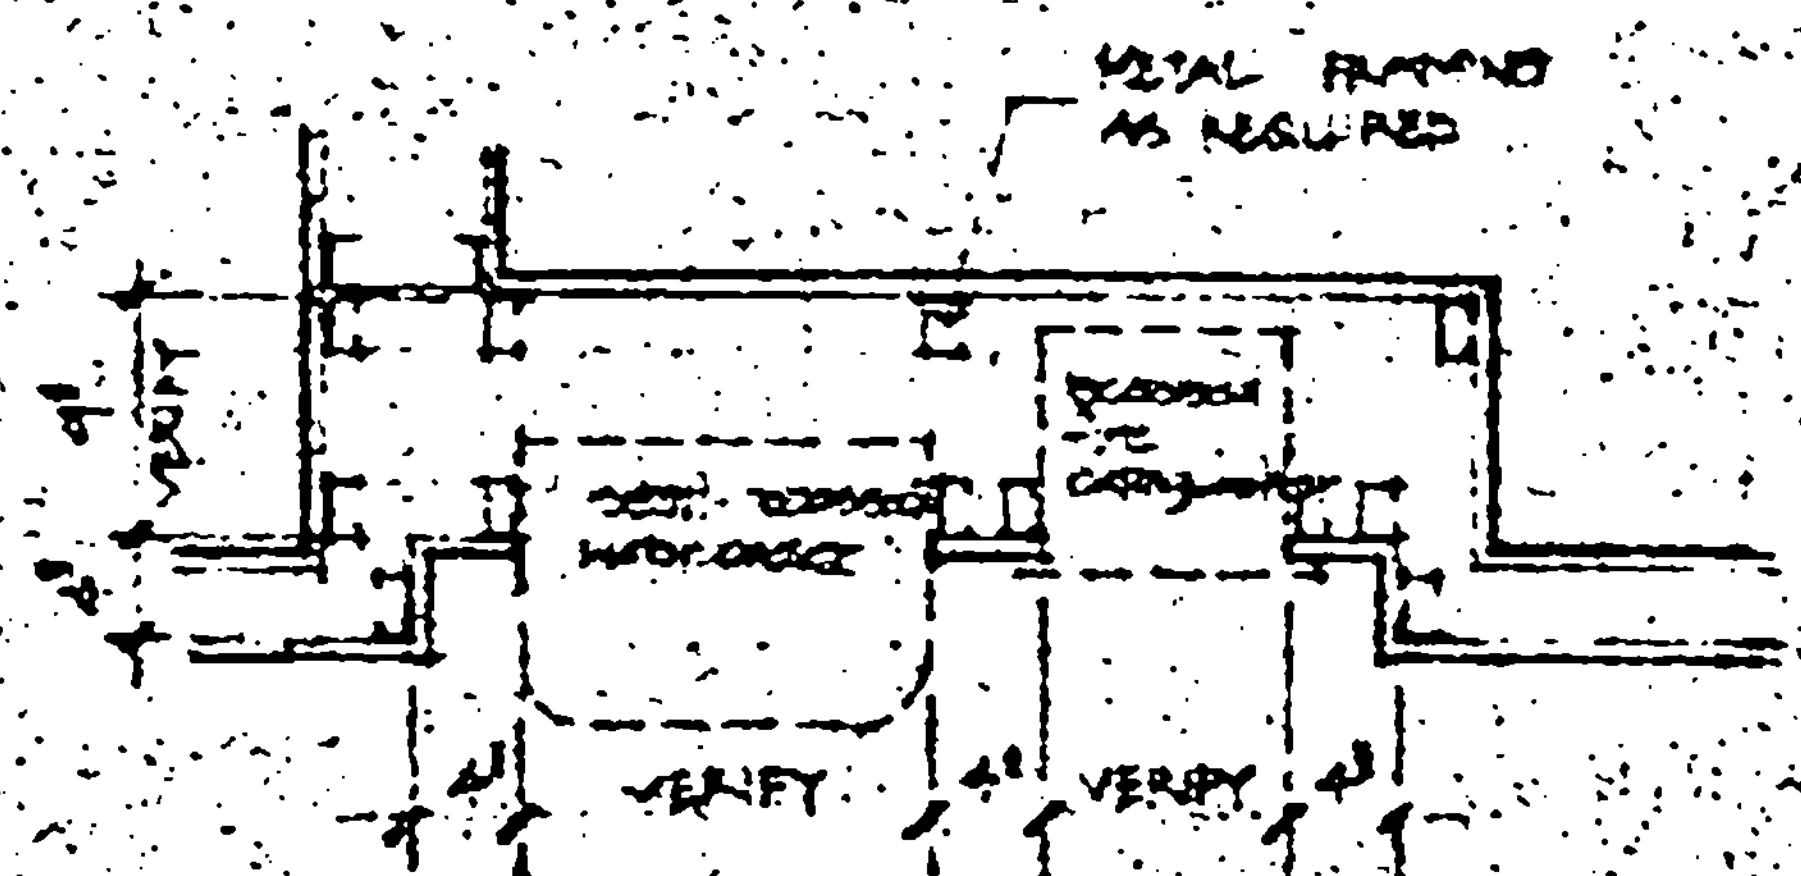

1 WATER COOLER AND FIRE EXTINGUISHER
SCALE: 3/4" = 1'-0"

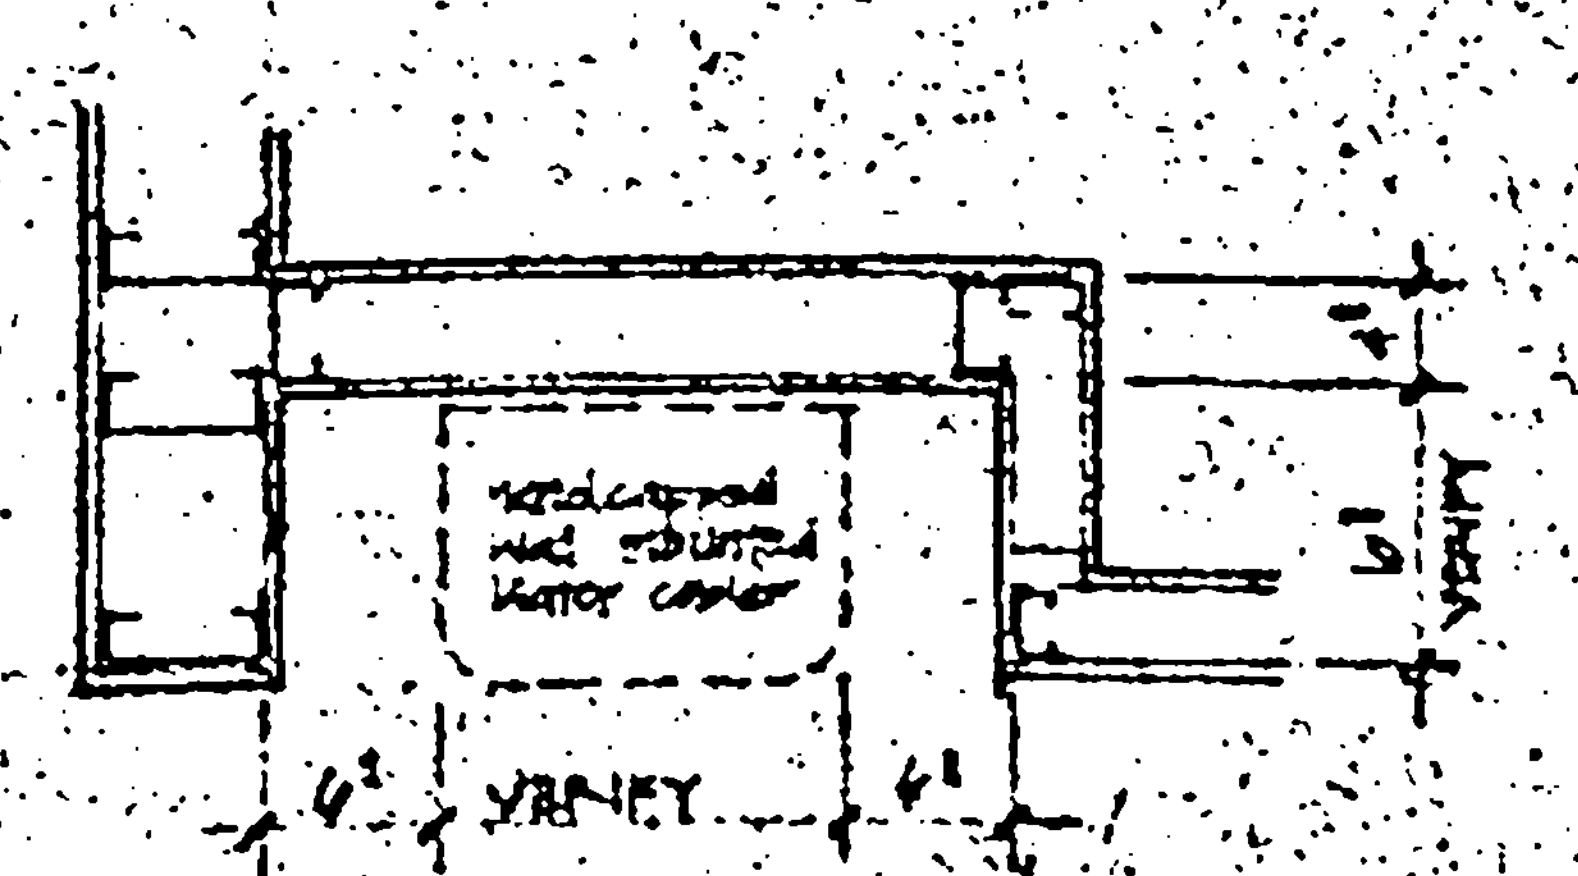

2 WATER COOLER
SCALE: 3/4" = 1'-0"

GENERAL NOTES

- 1) CONCEALED VENTILATION SHALL HAVE A PLUME AREA OF 6'-75" AND A PLUME DEVELOPED TO 6'-30".
- 2) EXPOSED VENTILATION SHALL HAVE A PLUME AREA OF 6'-30" AND A PLUME DEVELOPED TO 8'-30".
- 3) VERIFY FLOORING REQUIREMENTS FOR RECEPTION AND EXTINGUISHER CABINET RECOMMENDED BY IF.
- 4) PROVIDE 21" CLEAR CHAIRS FOR WAITING AREA WITH 2" HIGHER COUNTERS.
- 5) PROVIDE 4x2 92" HIGHER FLOOR EQUIPMENT DO. EQUIP. ELECTRICAL PLANS.

BOUSSARD PECOT AND ASSOCIATES, ARCHITECTS, INC.
105 WEST CONGRESS STREET,
LAFAYETTE LOUISIANA



BOHN OPTICAL CENTER
LOUISIANA
LAFAYETTE

ISS. NO.	102
DATE	11/1/78
REVISIONS	1
2	

